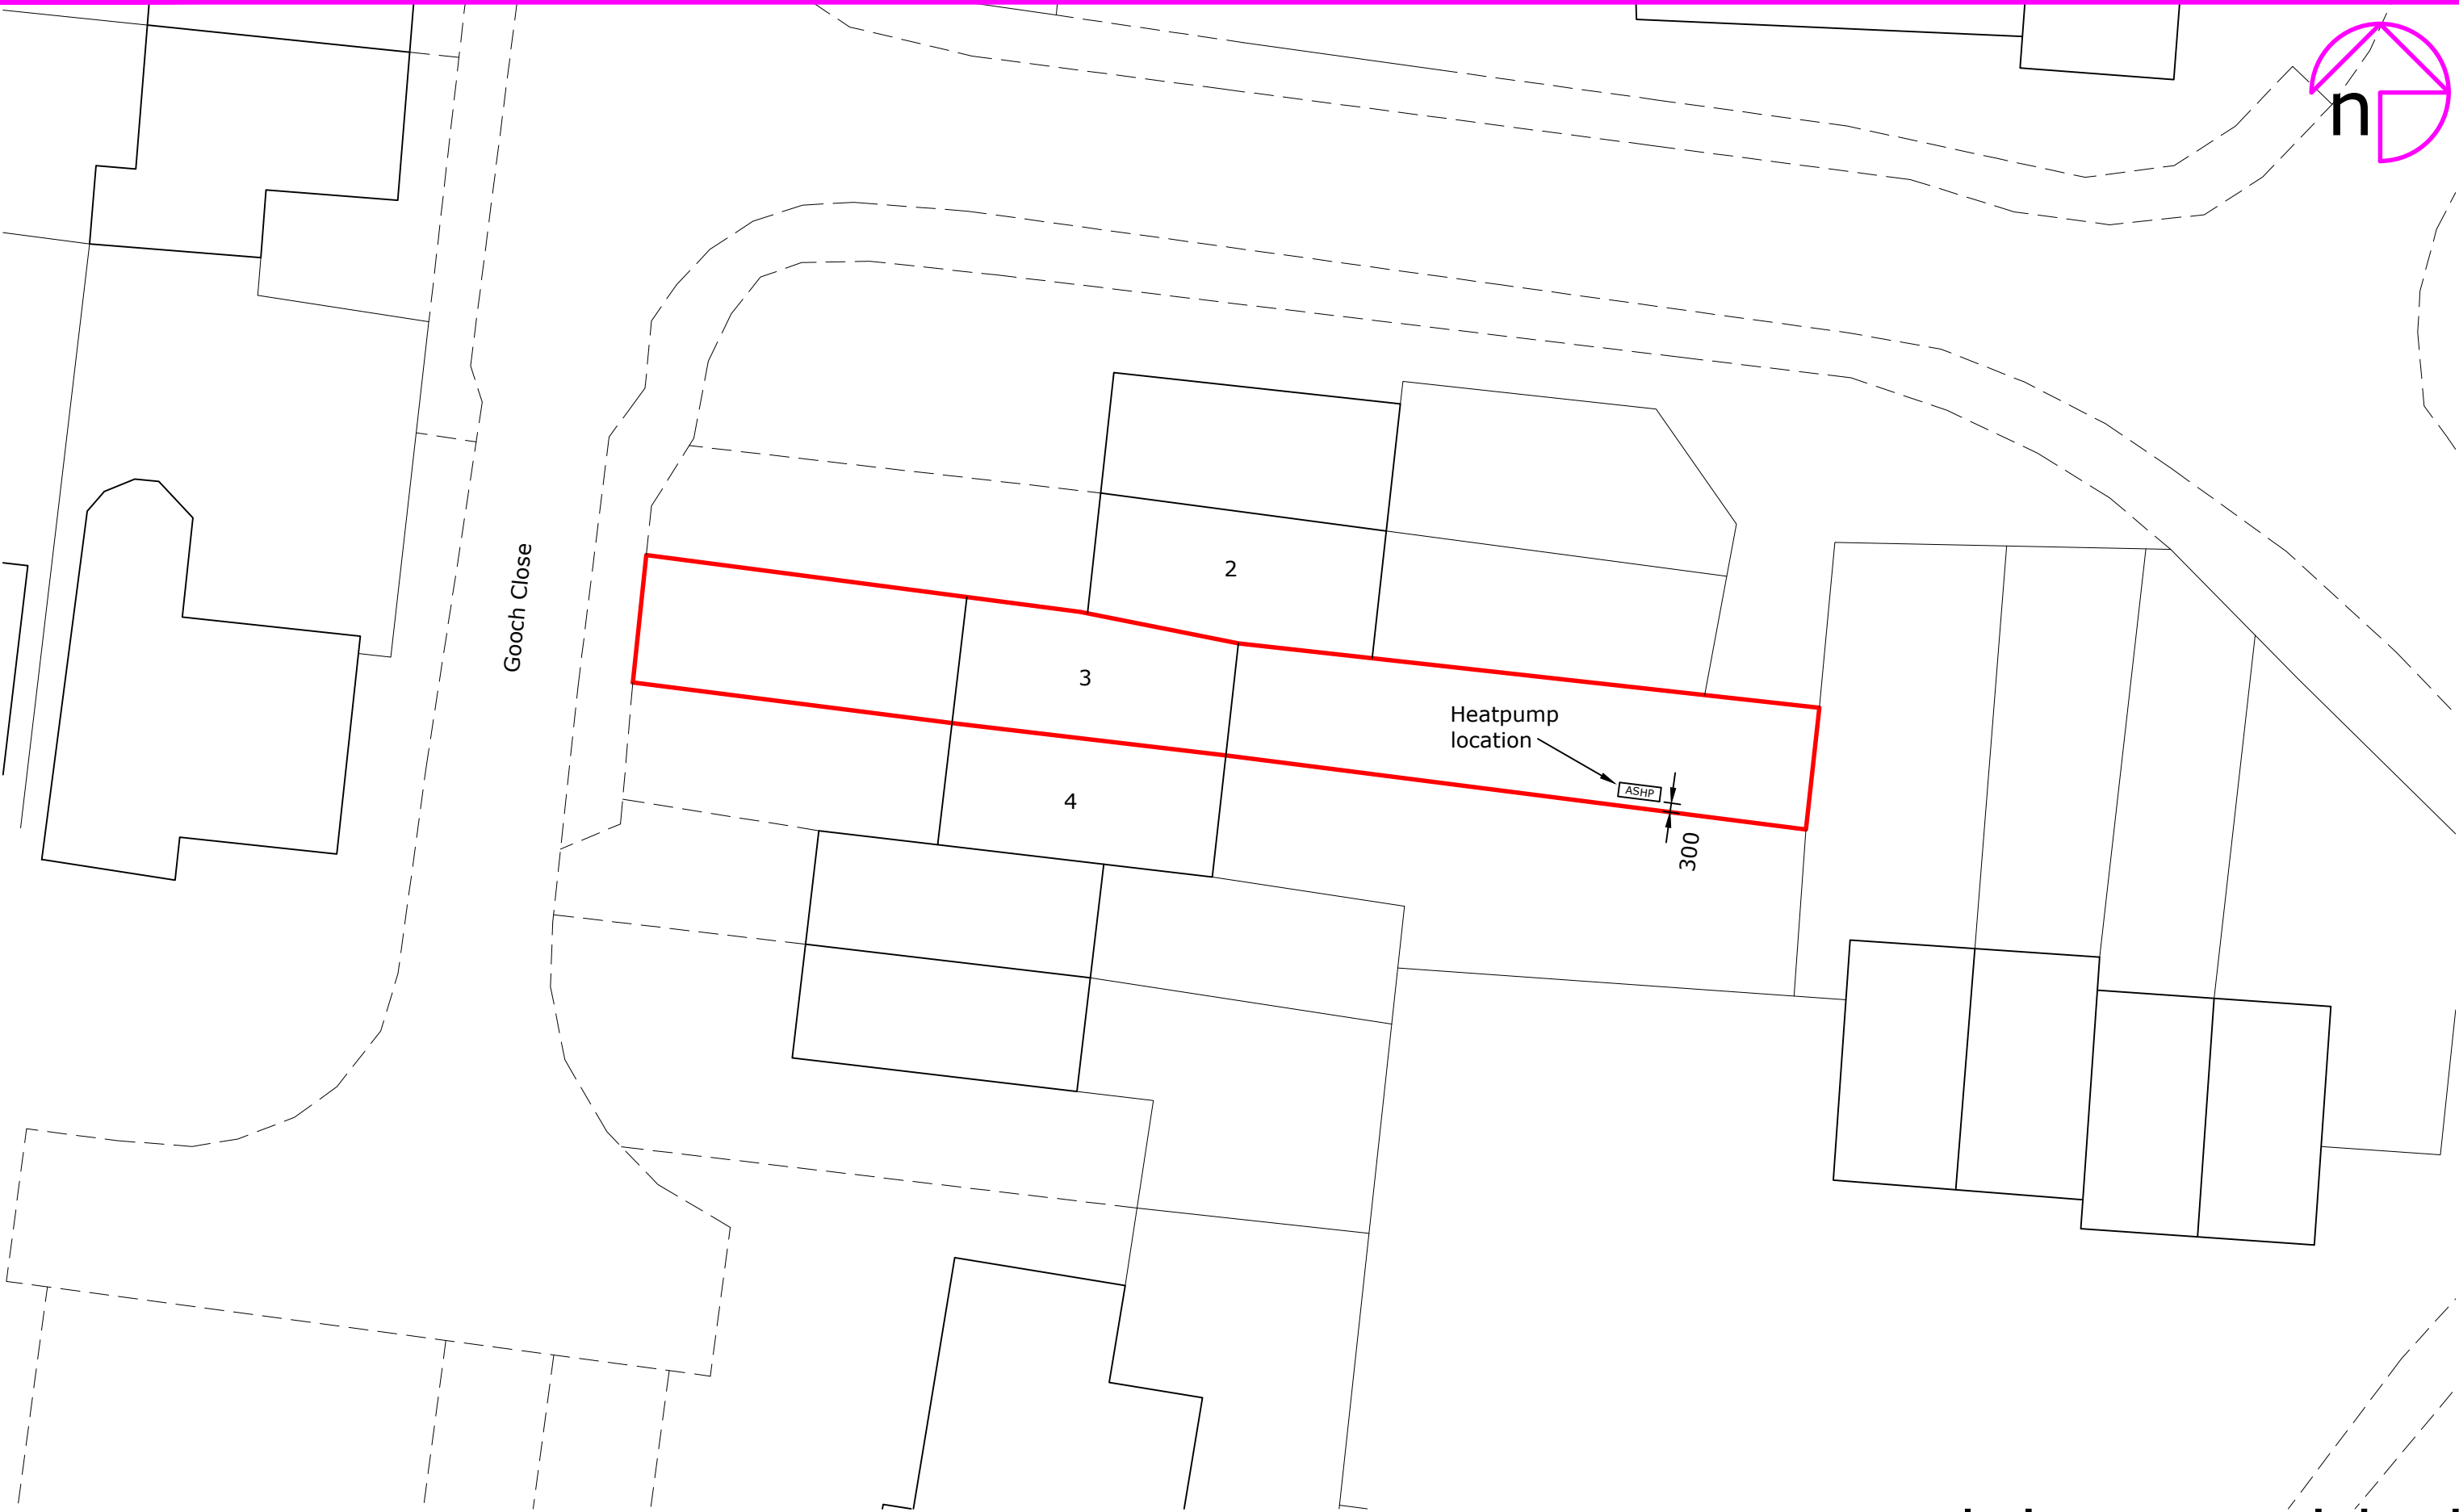
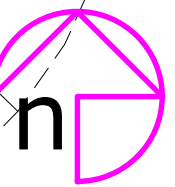


Rev:	Description:	By:	Date:
------	--------------	-----	-------

Client/Project:
Leila Naboulsi,
3 Gooch Close, Twyford,
Reading, RG10 0XS

Project status:
PLANNING
Drawing title: Site plan as proposed showing location
of air source heat pump

Scale: 1:200	Paper Size: A3	Drawn: A.Kenyon	Checked: O. Barnes
Project ID: J-217A604C	Drawing No: 02	Revision:	Date: Oct 2024