

LIGHTING PLAN KEY:



Dark Sky B PIR with Timers, 3000K, 8w - Zero upward light:

1 2 3 6 7 8 9 10

Warm Light Luminaries set to 1 minute timers


Please refer to Lighting Design Strategy (ARK Lighting) for detailed lighting specification information.

Drawing Key:

Dark Corridor Inner Buffer:

Dark Corridor Outer Buffer:

Please refer to Arbtch Dark Corridors Document

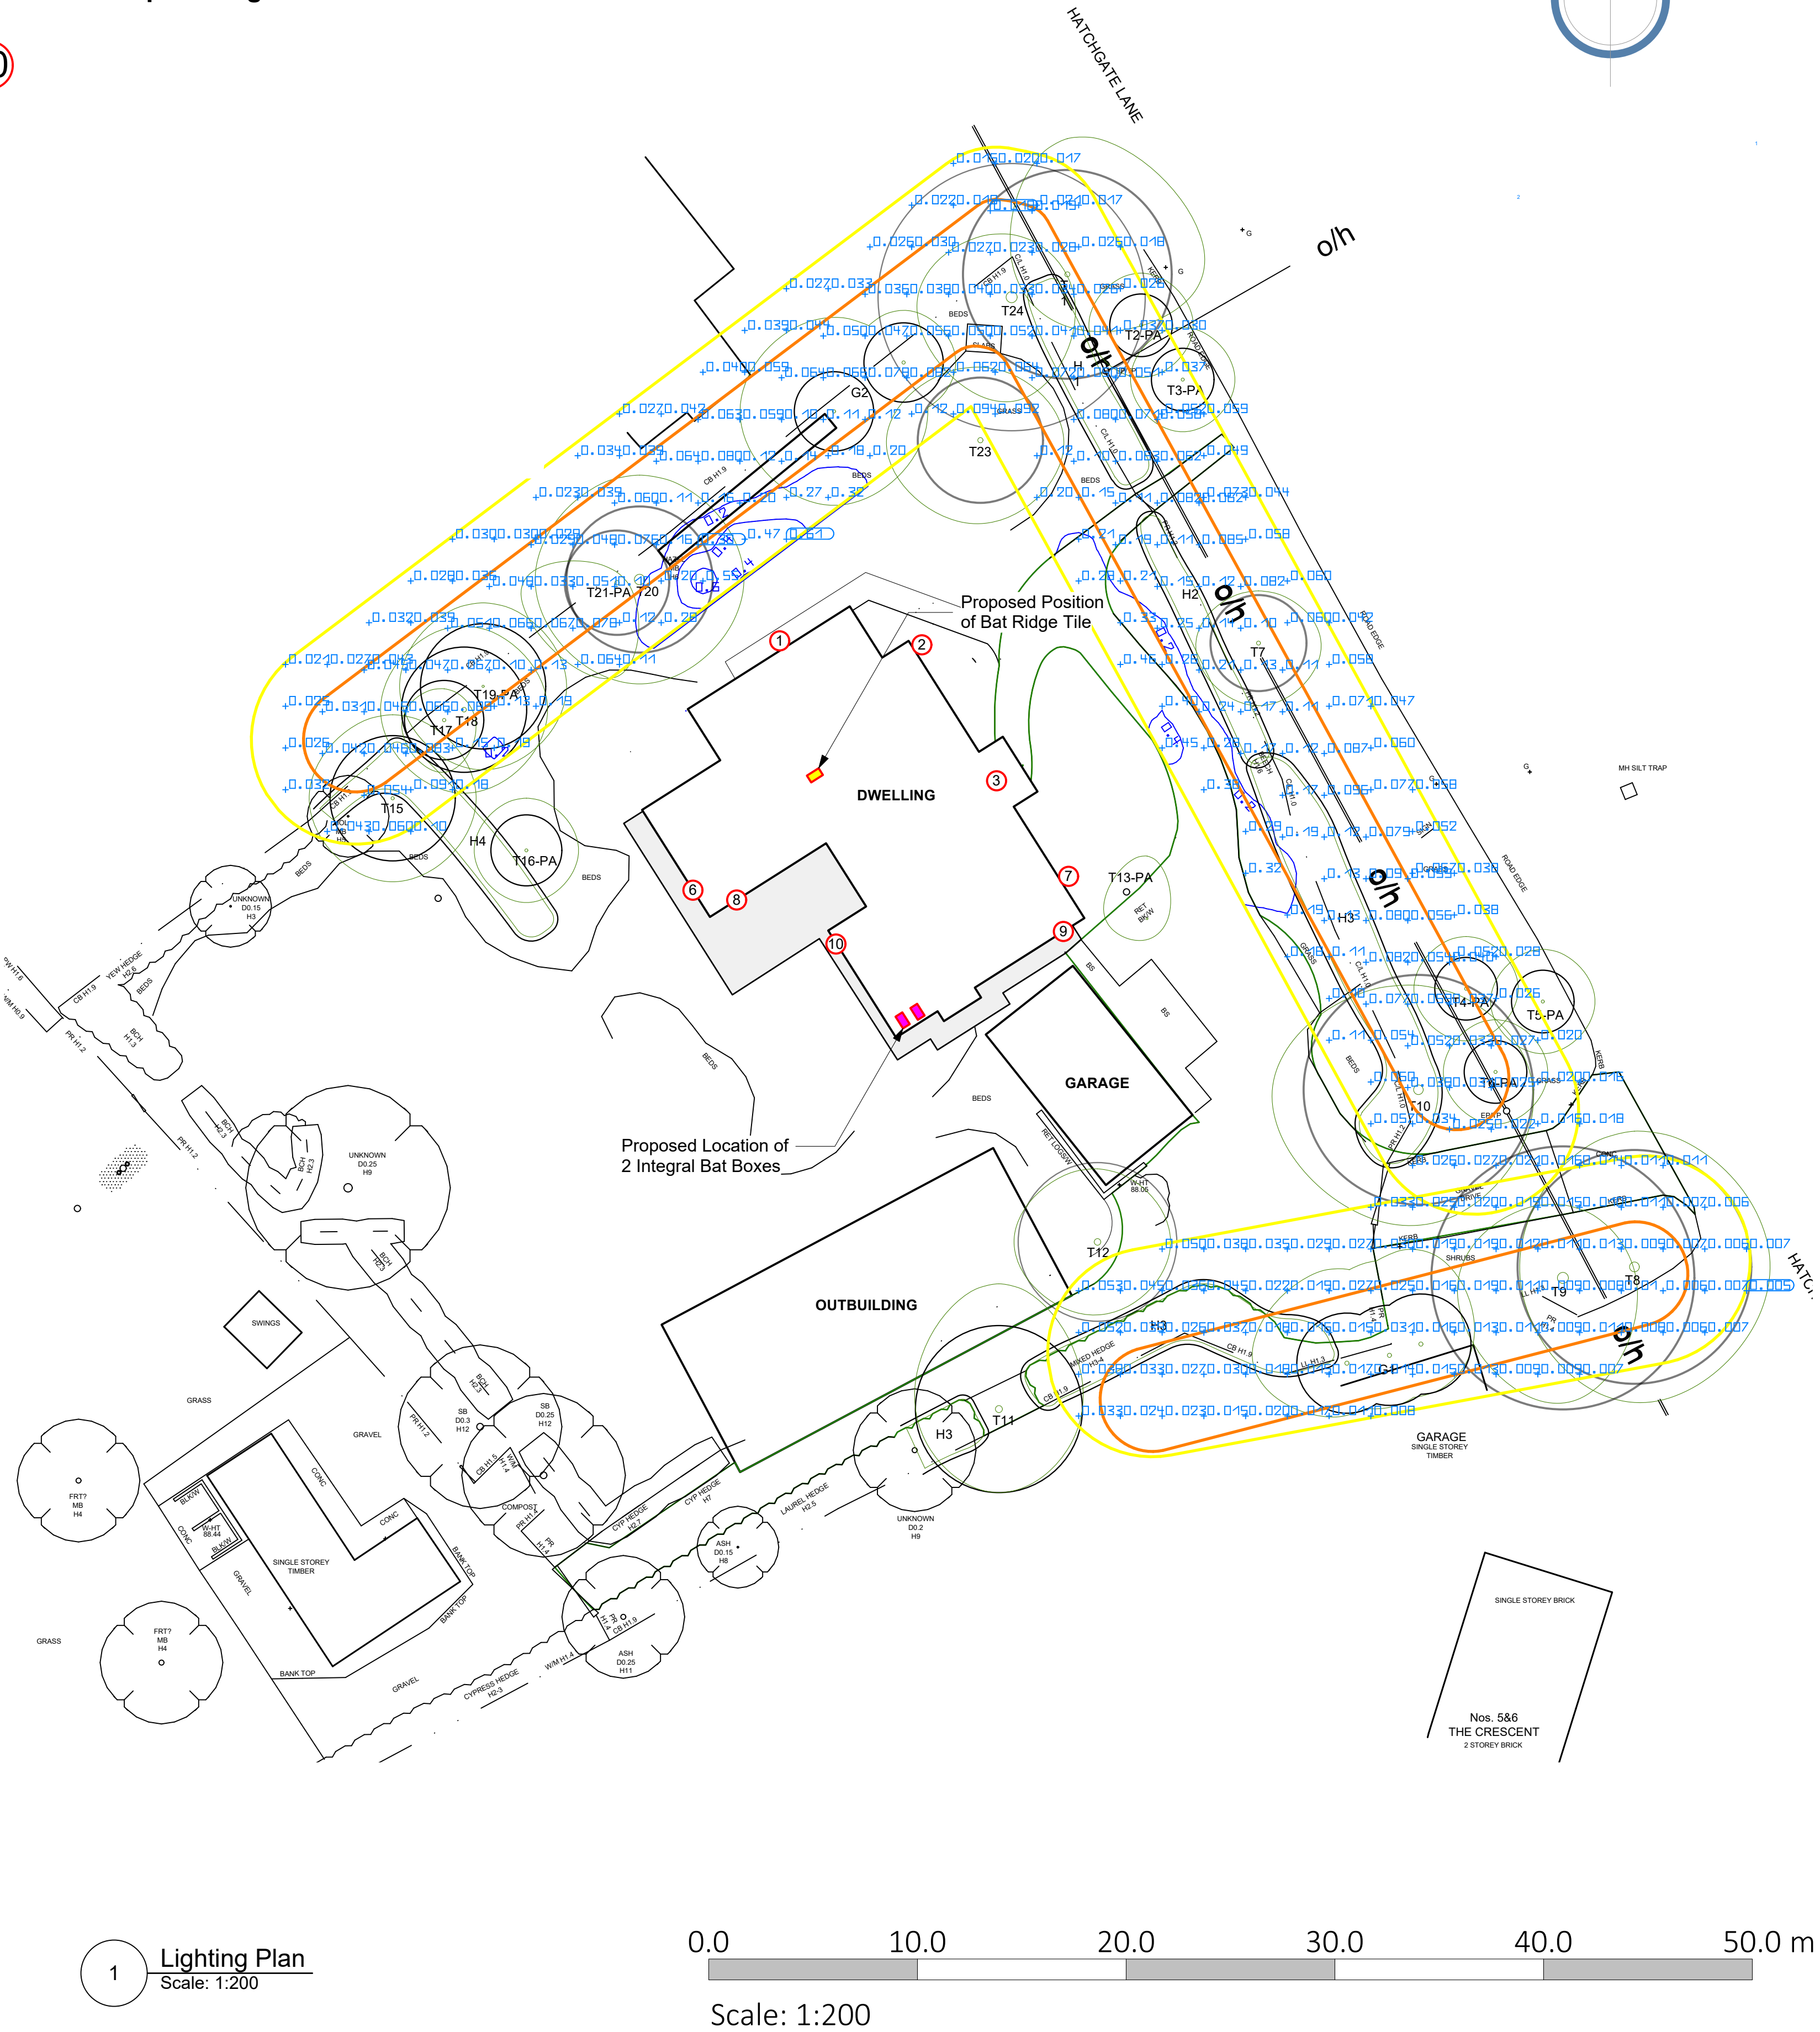

E	Amended Plans	27/04/2026	JL
D	Amended Plans	20/04/2026	JL
C	Amended Plans	30/03/2026	JL
-	Prelim Issue	20/11/2025	JL
Rev	Description	Date	Check

DRAWINGS PRODUCED BY

T.J. Crump Oakwrights Ltd
The Lakes, Swainshill,
Hereford, HR4 7PU
+44 (0)1432 353353
enquiries@oakwrights.co.uk

© This drawing, its contents, and all information contained therein is protected by Copyright. It may be used once only for its intended purpose under a contract with T.J. Crump Oakwrights Ltd, but not for any other use or purpose. This drawing is for Planning purposes and does not constitute a construction issue drawing. All setting out dimensions and levels are indicative and are subject to detailed site survey and site conditions. The Client and their agent are responsible for ensuring that Building Control and construction drawings are carried out following Planning approval. Scaling from this drawing is for Local Planning Authority information only.

CLIENT
Mr and Mrs Hart

SITE ADDRESS
Hatchgate End, Hatchgate Lane, RG10 8NE

PROJECT
Proposed Dwelling

DEPARTMENT
ARCHITECTURE

DRAWING
Lighting Plan

SCALE
1:200 @ A1

DATE DRAWN 18 / 03 / 2026	DATE ISSUED 27 / 04 / 2026
------------------------------	-------------------------------

DRAWN JL	CHECKED
-------------	---------

ISSUES STATUS

DRG. NO.
2748 - HAR - 20

REV.
E