



## **Appendix 1**    Tree Protection Plan



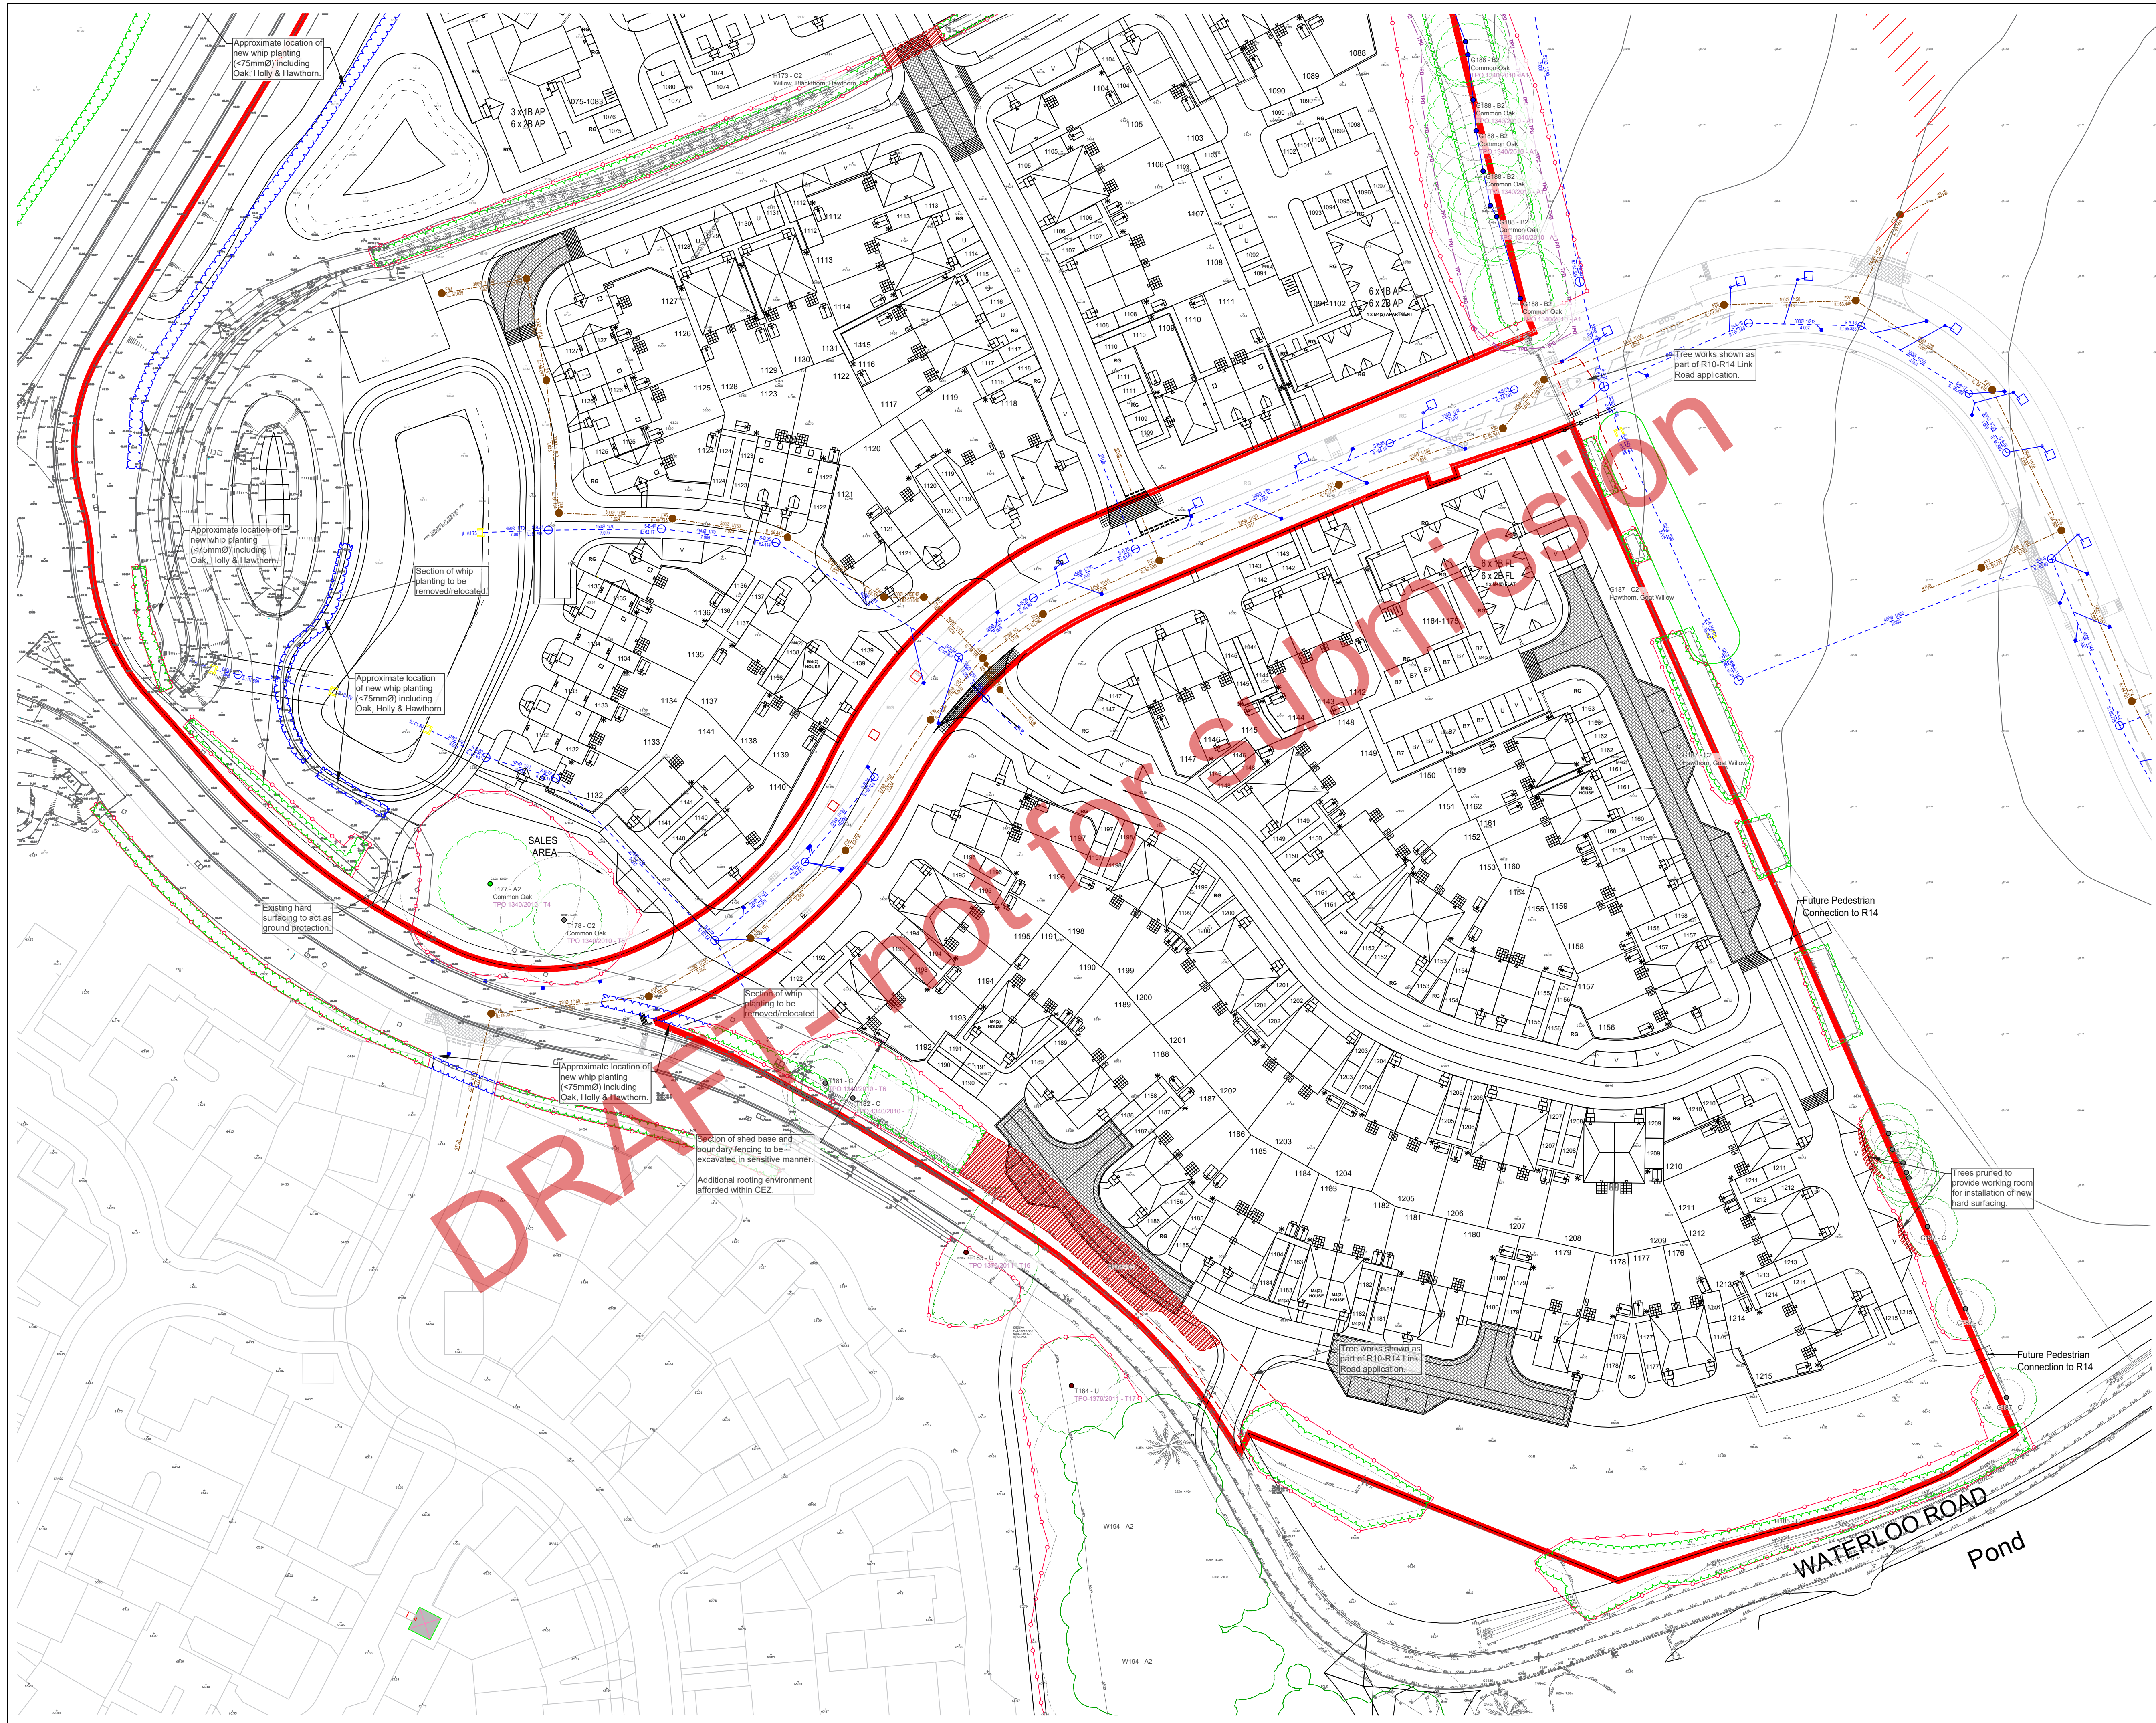

 
**LEGEND**  
**TREE PROTECTION FENCING & EXCLUSION ZONE**  
All Tree Protection Fence (TPF) shall be installed prior to any plant activity on the site, including excavation, utility installation, groundworks, and soil stripping. Once erected, all TPF will be regarded as permanent and will not be removed or altered without prior recommendation by the project arboriculturist and approval of the local planning authority.  
Tree Protection Fence shall comprise of these type panels on posts, well braced by adjustment to scaffold poles uprights driven firmly into the ground. Once the exclusion zone has been protected by barriers and/or ground protection, construction work can commence. All weather notices may be erected on the barriers.  
Tree works shown as part of R10-R14 Link Road application.

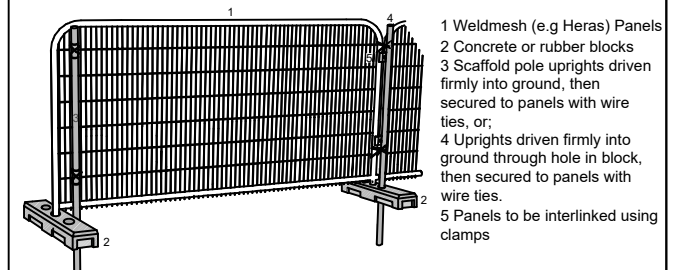

- TREE TO BE RETAINED**
- TREE TO BE REMOVED**
- HEDGE/GROUP CANOPY TO BE REDUCED - THIS APPLICATION**  
Hedge to be trimmed back from the red dashed line to the green line as indicated.
- HEDGE CANOPY TO BE REDUCED - FROM DIFFERENT APPLICATION**
- SECTION OF WHIP PLANTING TO BE TRANSLOCATED**
- A CATEGORY TREE**
- B CATEGORY TREE**
- C CATEGORY TREE**
- U CATEGORY TREE**
- ROOT PROTECTION AREA (RPA) FOR RETAINED TREES**
- TPD AREA**  
Area within this line indicates Group/Area

**SENSITIVE EXCAVATION**  
The required excavation is within retained RPA. To reduce impacts to underlying roots the excavation is to be conducted in a sensitive manner, either by use of hand tools and an spade where feasible or through use of an excavator with a toothless bucket and under direct supervision.

The original of this drawing was produced in colour - a monochrome copy should not be relied upon.



| Rev | Date | Details | Drawn |
|-----|------|---------|-------|
|-----|------|---------|-------|


**ACD ENVIRONMENTAL**  
HEAD OFFICE  
Rodbourne Rail Business Centre, Grange Lane,  
Malmesbury, SN16 0ES  
Tel: 01666 825646  
Unit 7, Godalming Business Centre, Woolsack Way  
Godalming, GU7 1XW  
Tel: 01483 425714  
Suite 6, Crescent House, Yonge Close,  
Eastleigh, SO50 9SX  
Tel: 02382 026300  
email: mail@acdenv.co.uk  
www.acdenvironmental.co.uk

Copyright of ACD. All rights described in Chapter IV of the Copyright, Designs and Patents Act 1988 have been generally asserted. 2015. Copyright of this plan remains with ACD until all fees have been paid in full.

**miller homes**

 scheme: South Wokingham  
Phase R10  
client: Miller Homes  
drawing: Tree Protection Plan  
date: 31/01/2025  
scale: 1:500@A1  
dwg no: MILL24614-03  
Sheet 2 of 2  
drawn: WTW checked: HEP

## **Appendix 2**    Lighting Plan



© ABLEY LETCHFORD PARTNERSHIP LTD.  
This drawing should not be reproduced without consent.

- STREET LIGHTING NOTES:**
1. Do not scale.
  2. This drawing is to be read in conjunction with and checked against all other drawings, Engineering details, Specification and any structural, Geotechnical or other specialist document provided.
  3. Any anomaly or contradiction between any of the above is to be reported to the Engineer.
  4. Lighting design to be in accordance with the Highway Authority and the Manufacturer's specification.

**STREET LIGHTING KEY:**

- ADOPTABLE LIGHTING:**
- Proposed 6m Aluminium lighting company conical tapered column with post top mounted Philips Lumina Gen 2 Micro RSP202, DM10 Optic with BL1 rear louvre, 10 LED, 2700K and 3200 lumen output. Lantern to be installed with 0 degree tilt.
  - (R&L Denotes Raise and Lower Columns)
  - Direction of fall for Raise and Lower columns
  - Proposed Link Road street lighting column. TBC.
  - Existing street lighting column. TBC.

**LIGHTING LUX KEY:**

- 0.6 Lux Contour (Min. for PS)
- Adaptable areas fit to Lighting Class PS in accordance with BS EN 13201:2015

**LIGHTING NOTES:**

1. Private lighting NOT controlled by WBC Telesma CMS System.
2. Control / Dimmer Unit to be Telesma 5-pin NEMA Telescut with integral Telesma Dimming Module (DALI standard) and GPS positioning
3. Cut-Out Type - Lucy MC040SLF with 6 amp R&L.C. fuse as standard. Fuse size may be increased as appropriate where feeds to other units are required - fuse size to conform to IEE regulations).
4. Isolator - Charles Manufacturing LSI-02/5F or Lucy Triplan Mini isolation unit with 6 amp

|     |       |                               |       |         |
|-----|-------|-------------------------------|-------|---------|
| B   | 46.25 | UPDATED TO SUIT LATEST LAYOUT | CL    | RF      |
| A   | 02.25 | FIRST ISSUE                   | AS    | RF      |
| Rev | Draw  | Description                   | Drawn | Checked |



Client  
**MILLER HOMES**

Project  
**SOUTH WOKINGHAM SDL  
PHASE 2B R10 RESERVED  
MATTERS APPLICATION**

File  
**STREET LIGHTING  
LUX PLAN**

|                 |          |       |         |
|-----------------|----------|-------|---------|
| Scale           | Date     | Drawn | Checked |
| 1:500 @ A0      | FEB 2025 | AS    | RF      |
| Drawing No      | Project  |       |         |
| A389-R10-RM-121 | B        |       |         |

Scale 1:500  
0 5 10 15 20 25m