
 


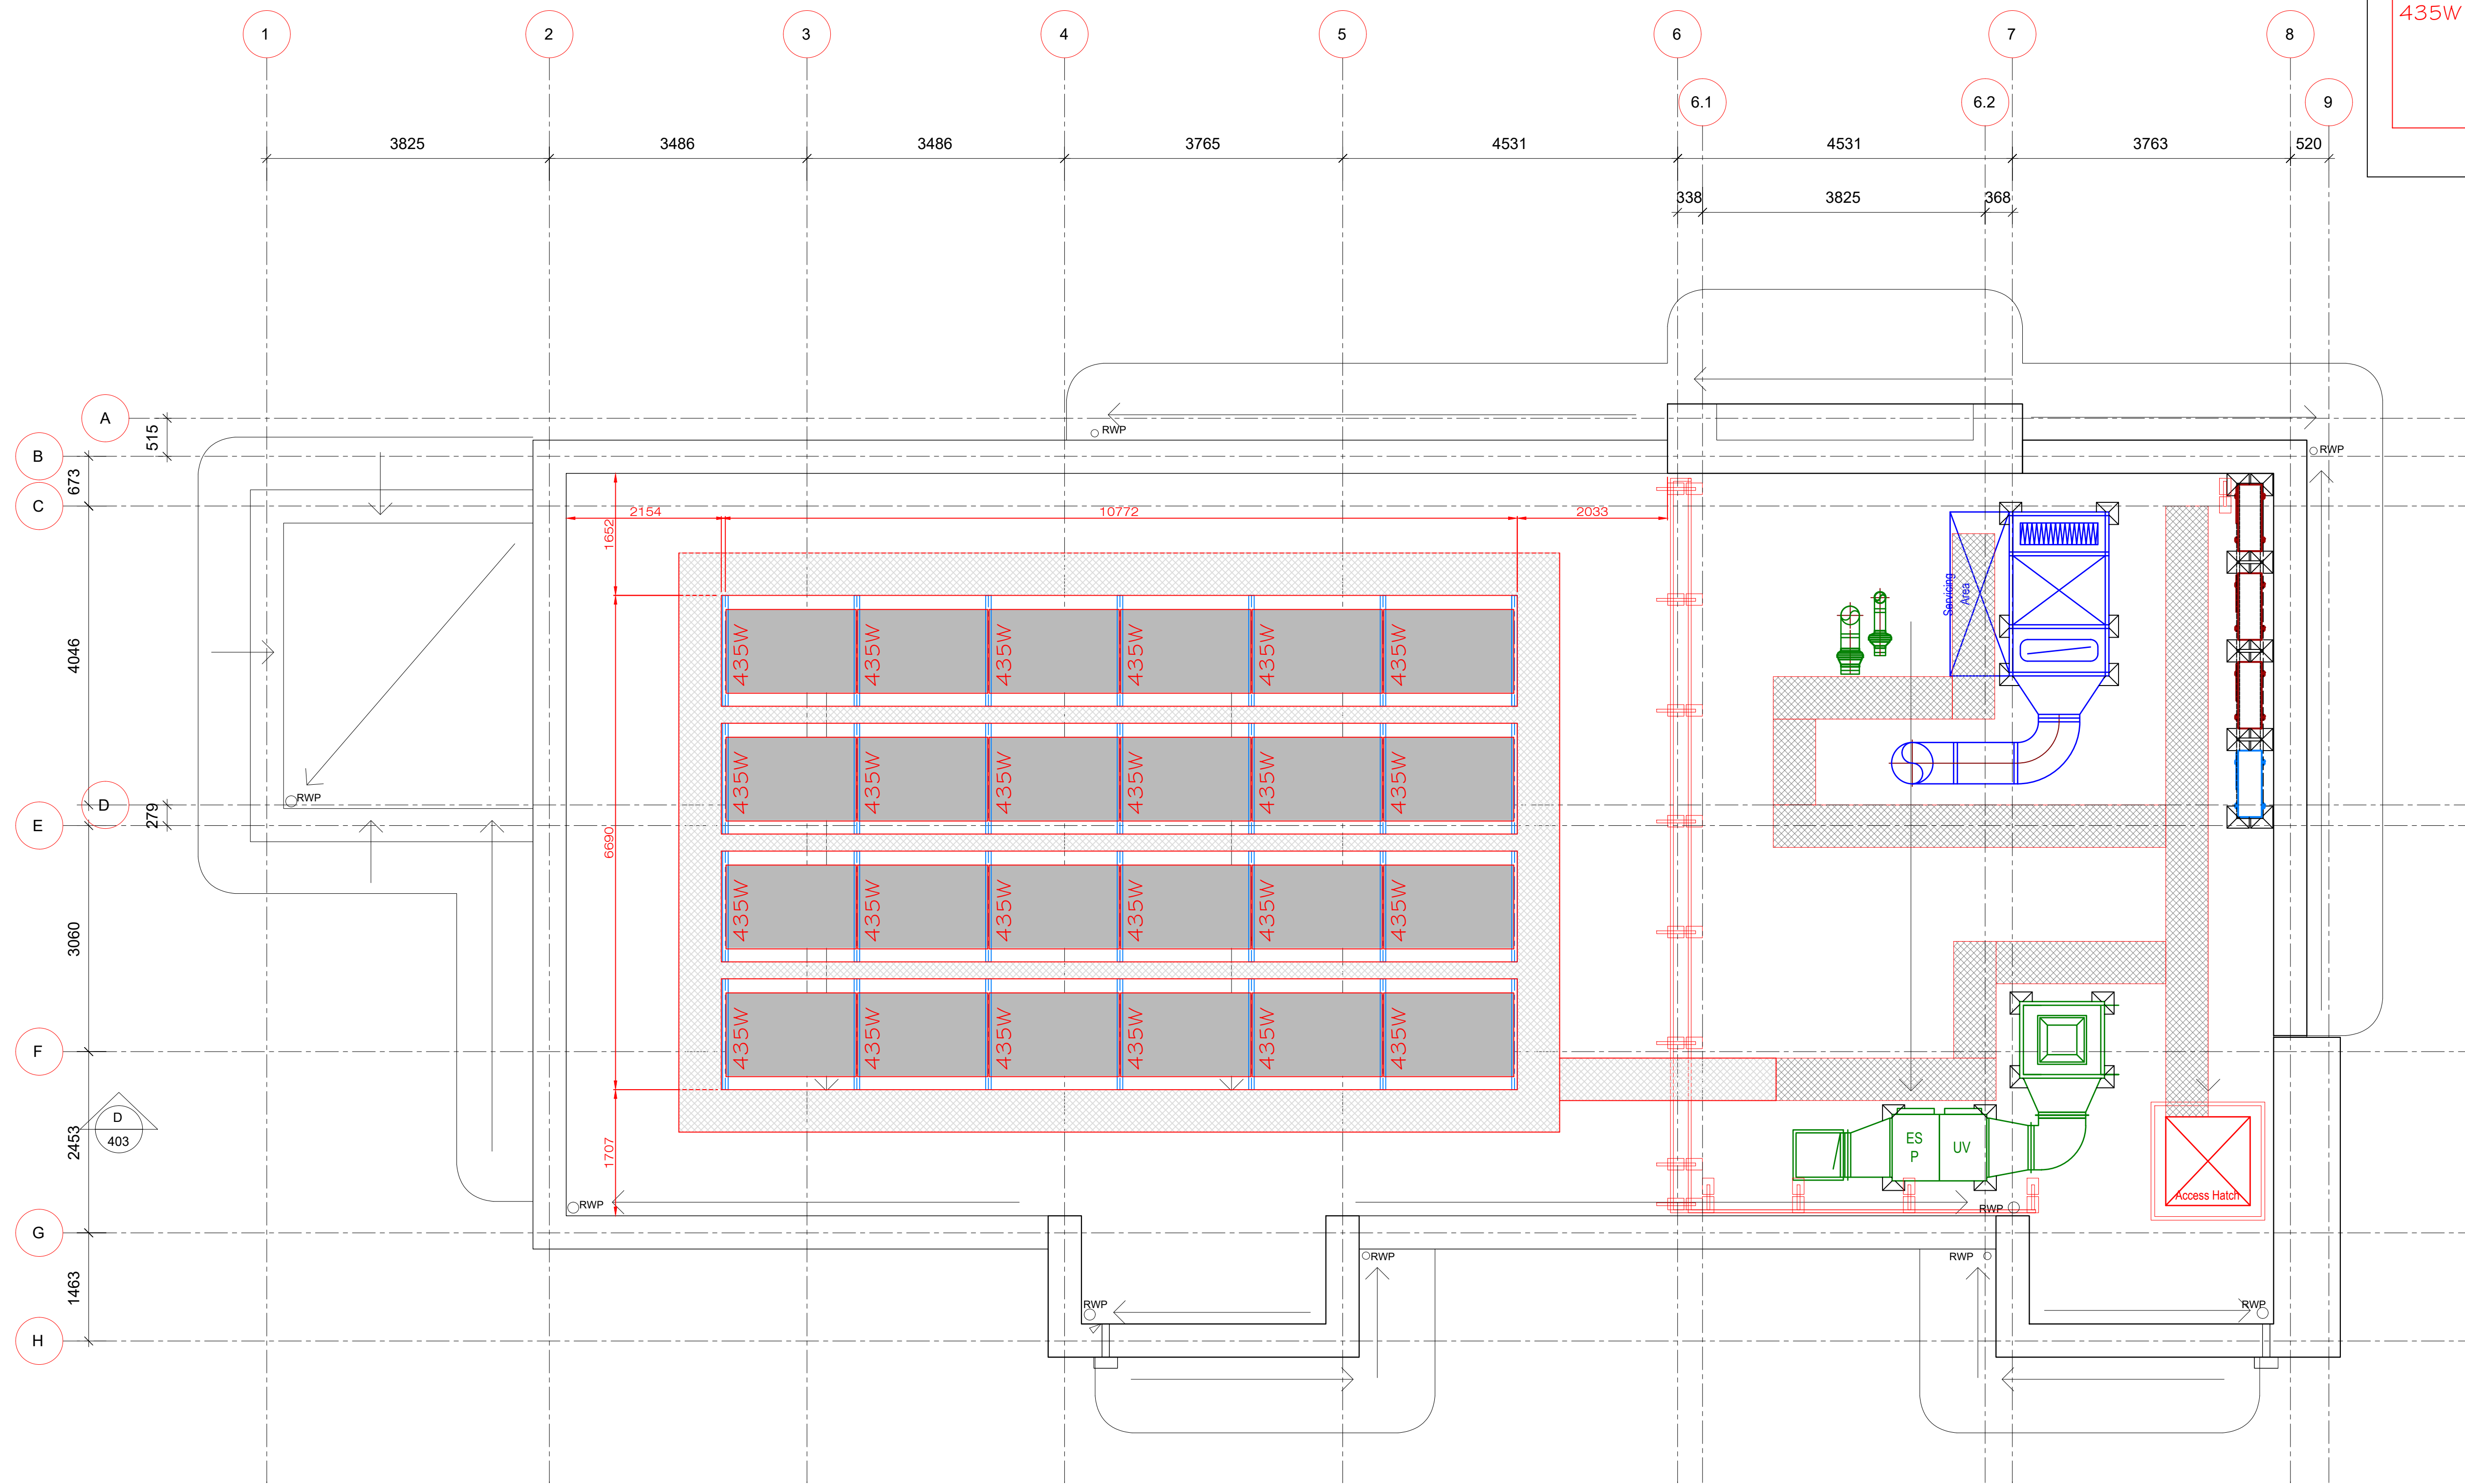

KEY		
	DESCRIPTION	QTY
435W	10.44 KW Solar Array 24x 435w Panels = 528kg Mounting System = 495.4kg	24

ROOF PLAN

1 : 50 @ A1



Revisions

Revisions

A	03.04.25	Updated solar design
B	23.05.25	Reduced number of panels
C	12.08.25	Added dimensions
D	19.08.25	Added proposed location for walkway
E	02.10.25	Updated specification details

Notes

-
-
Copyright:
The details shown on this drawing are confidential and the drawing is the exclusive property of Greenlite Group.
No use, copy or disclosure of the drawing may be made without our permission and it is to be returned to Greenlite Lighting Solutions Ltd when required.

Client:-
FIVE GUYS

Architects:-

Details:-
SOLAR LAOUT

Contract:-
SHOWCASE CINEMA, READING
ROAD, WINNERSH, RG41 5HG

DESIGN STATUS

APPROVAL
CONSTRUCTION
AS BUILT



Greenlite Lighting Solutions Ltd

Unit 11 Apollo Court
Whitehills Business Park
Blackpool FY4 5FS
08000 27 27 27
greenlitesolar.co.uk

Contract No:	Scale	Date:	Drawn by:					
.	1:50 @ A1	06.02.25	A.B					
Drawing No:		Revision Nos.						
PV-20171 -S01		A	B	C	D	E		