




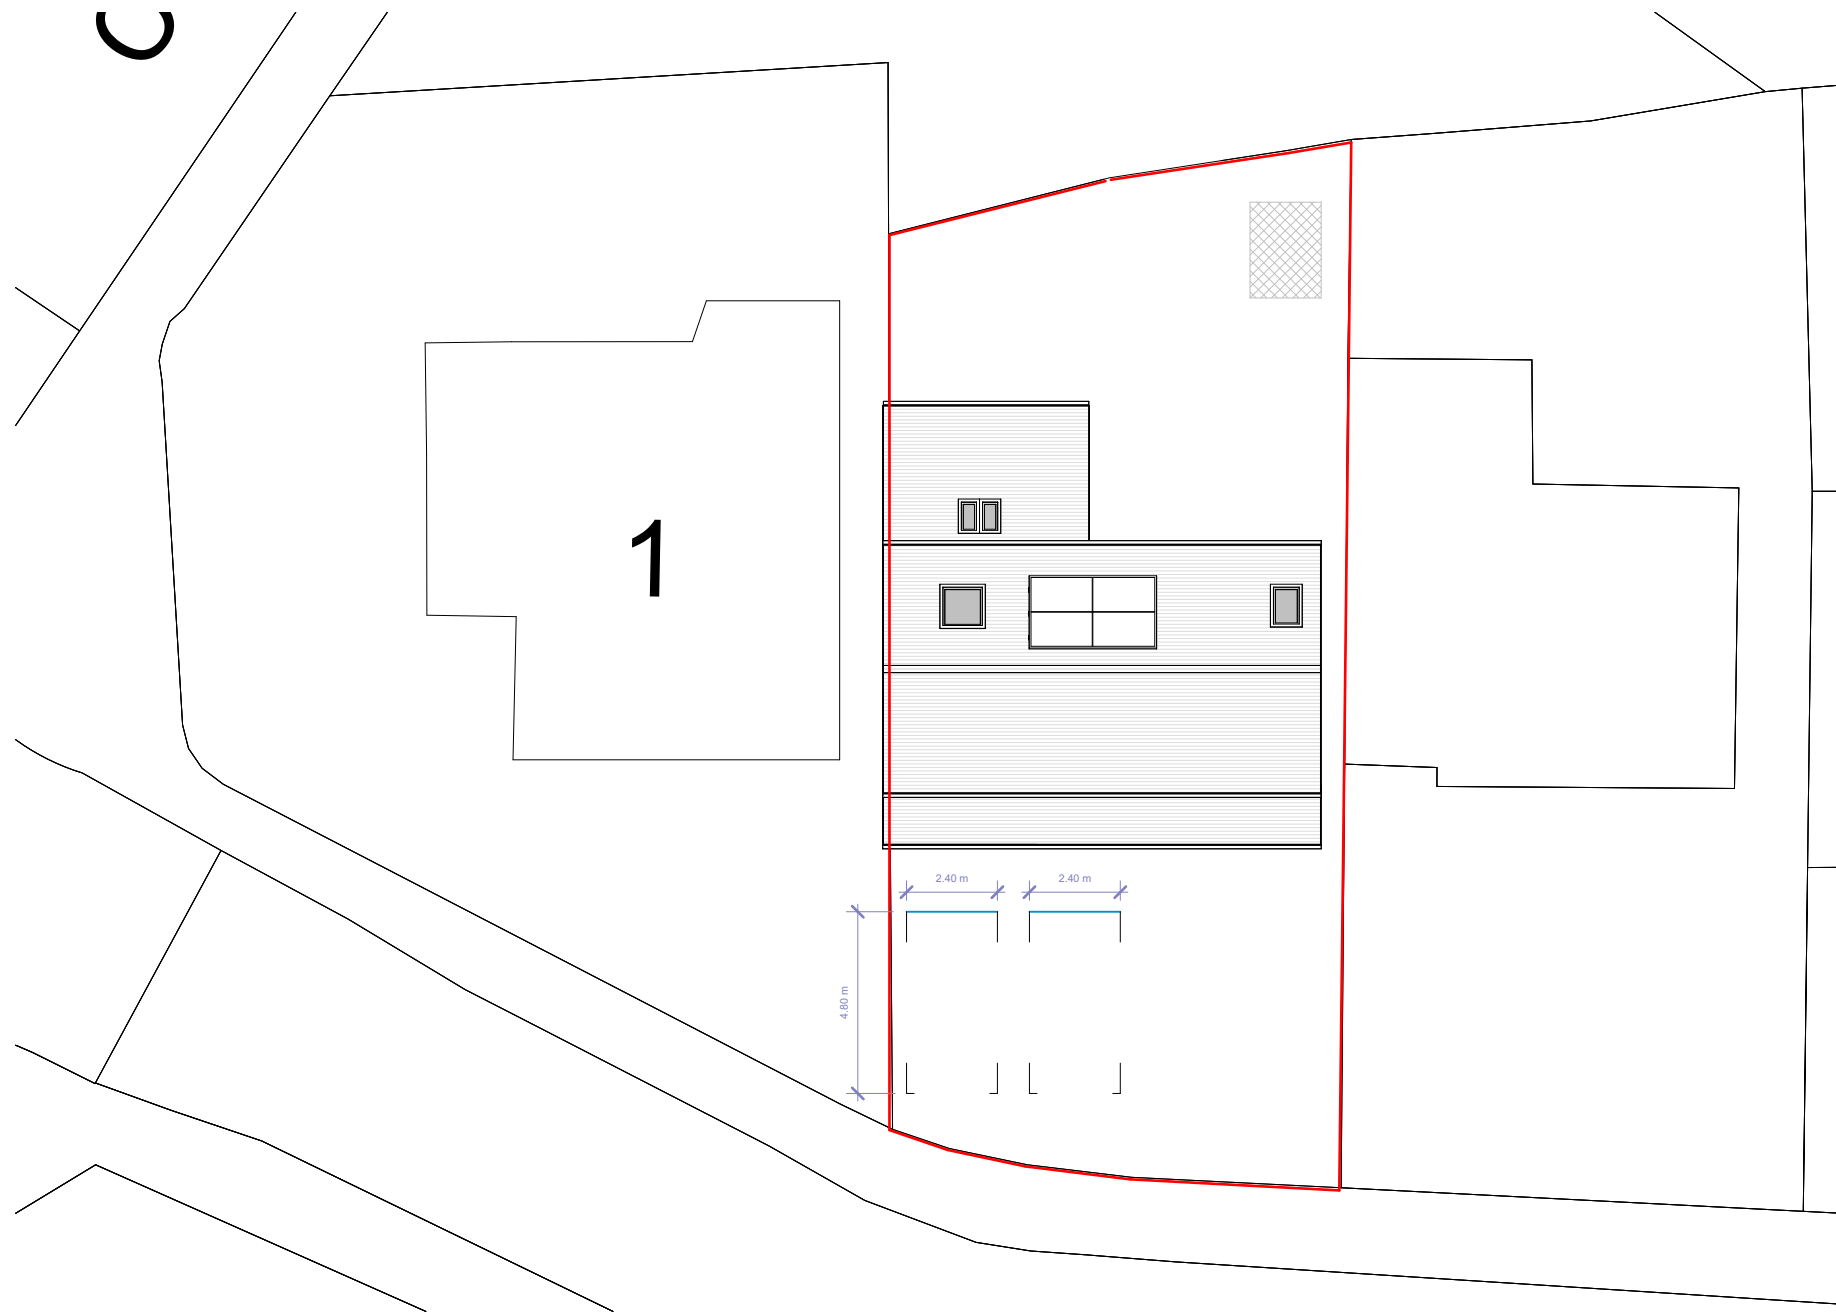

Site Plan

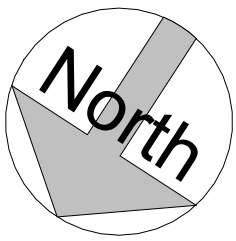

3D View 1

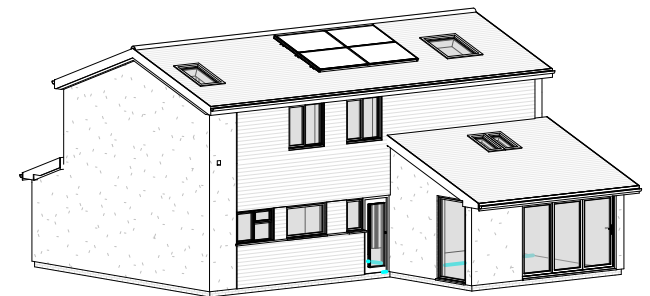

3D View 2



FLUENT
ARCHITECTURAL DESIGN SERVICES
TEL: 0800 043 8838
E-MAIL: INFO@FLUENT-ADS.CO.UK
WEB: FLUENT-ADS.CO.UK

3 Wessex Gardens, Reading

Proposed Site Plan and 3D Views

Scale @ A3
1 : 200

Date
13.05.24

Drawn by
S.G

 
Drawing number
P.M.400

Project number
2291.03

Rev
D

Key:

Existing Proposed SVP Boundary line
Existing drainage Proposed drainage Overhead



No.	Description	Date
A	First draft	13.05.24
B	Client's comments (2)	23.05.24
C	Client's comments (3)	25.07.24
D	Client's comments (4)	29.08.24