


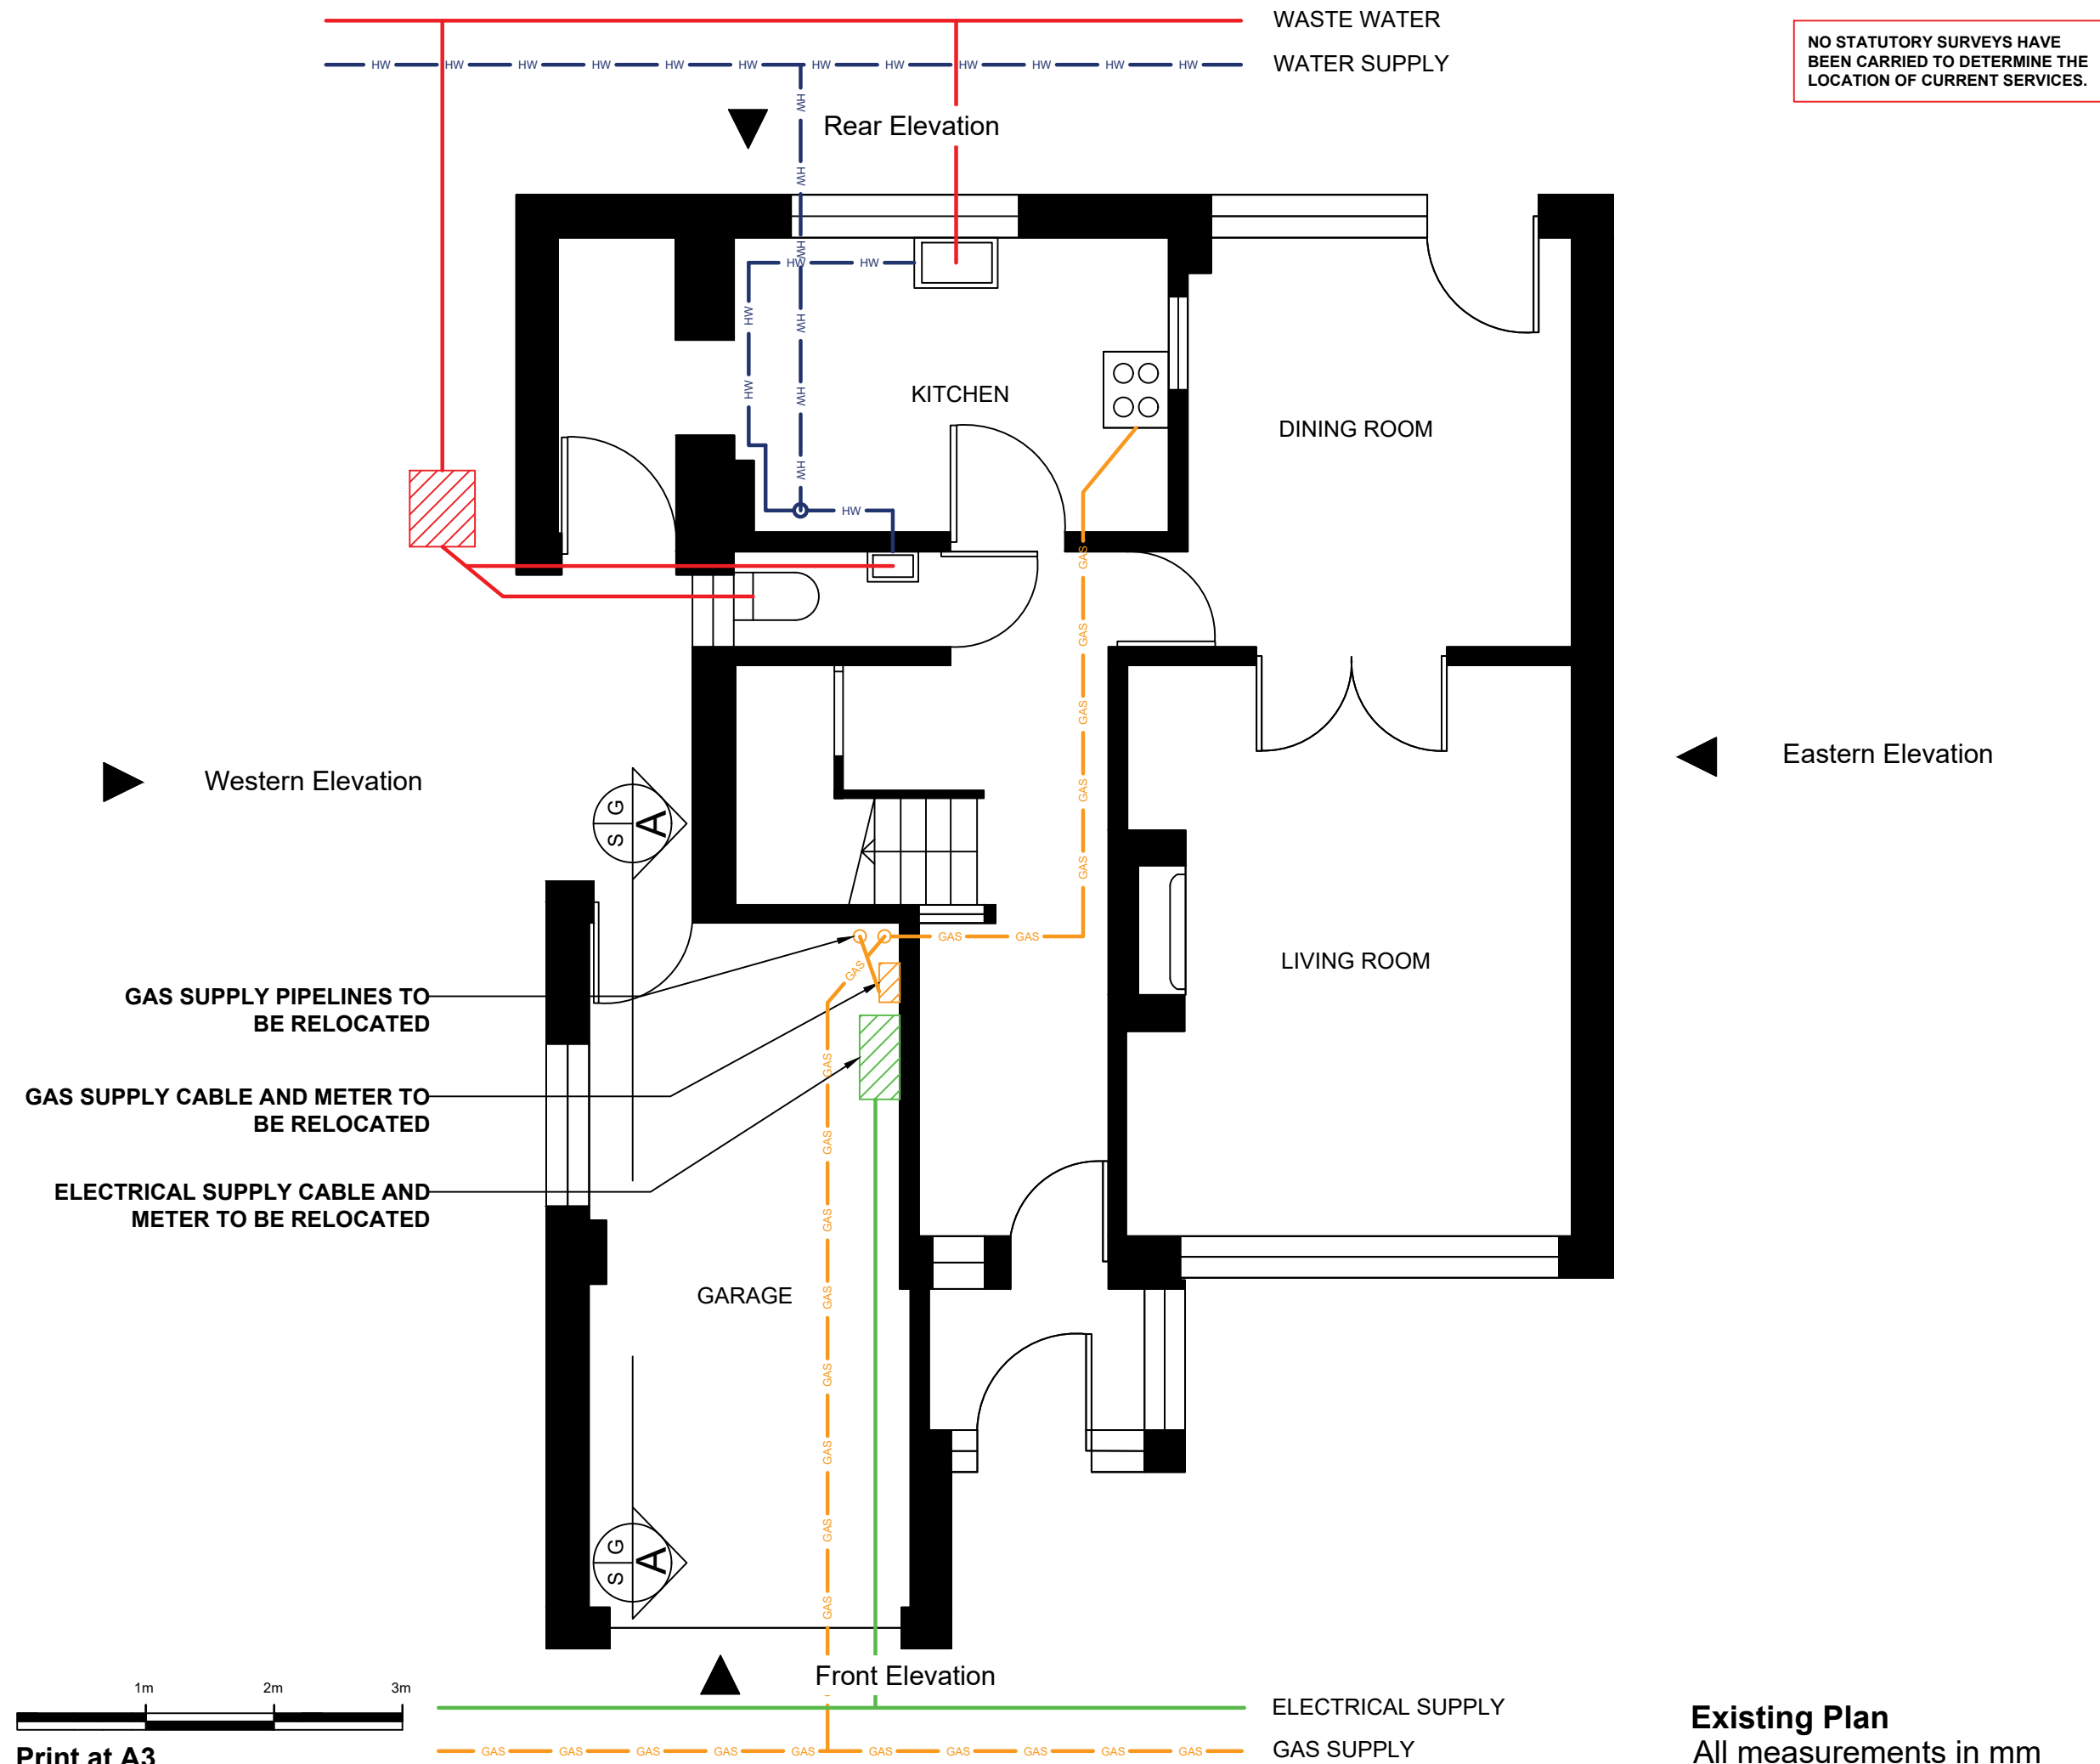

Notes

1. This drawing should be read in accordance with relevant drawings, specifications and information.

Key

Waste water	—
Clean water	—
Gas Supply	—
Electrical Supply	—

B	FOR INFORMATION	DH	SOO	SOO	30.03.25
A	FOR INFORMATION	DH	SOO	SOO	13.03.25
REV	DETAILS	DRN	CHK	APPR	DATE

96 Hartsbourne Road,
Ground Floor Plan -
Garage Conversion

Manoj Devkota

Contractor/Engineering Consultant

RegalEagle

Residential Solutions

78 Middleton Road, Morden, Surrey, SM4 6RS, United Kingdom
Tel: 44-(0)79-5654-8318 Email: Stephen.Olutola@regaleagle.co.uk

DATE	03.03.2025	DRAWN BY	DH
REFERENCE NUMBER	HR-03032025	PRODUCED BY	SOO
SCALE	1:50	CHECKED BY	SOO
DRAWING NUMBER	HR03032025/05	APPROVED BY	SOO
			B

© Copyright Regal Eagle (Engineering) Limited