


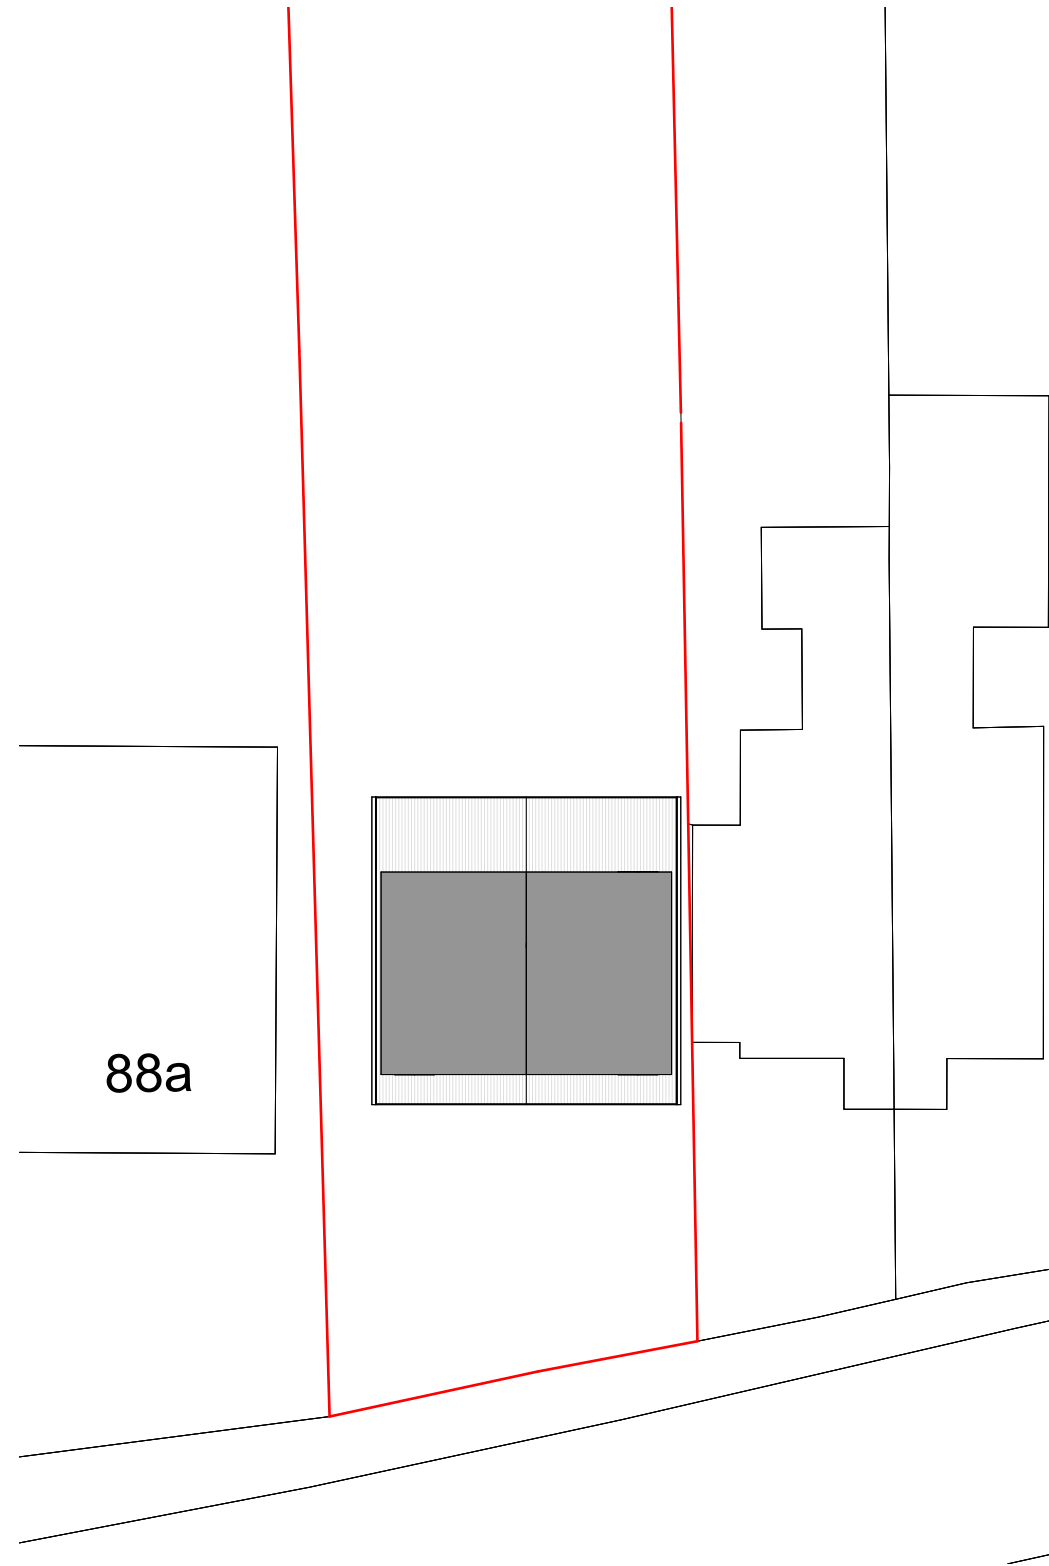


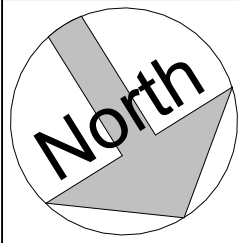

Site Plan

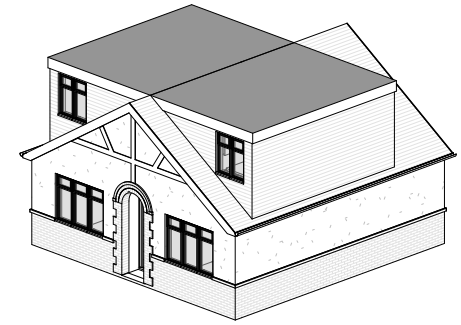

3D View 1

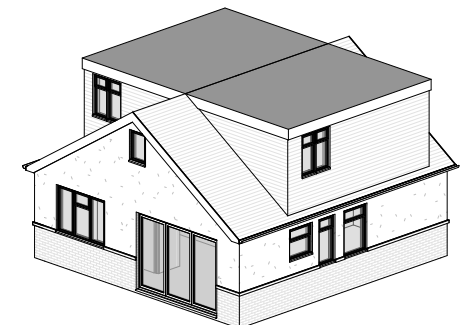

3D View 2



FLUENT
ARCHITECTURAL DESIGN SERVICES

TEL: 0800 043 8838
E-MAIL: INFO@FLUENT-ADS.CO.UK
WEB: FLUENT-ADS.CO.UK

90 Matthewsgreen Rd Wokingham RG41 1JT

Proposed Site Plan and 3D Views

Scale @ A3
1 : 200

Date
06.03.2026

Drawn by
MV

Drawing number
P.M.400

Project number
2528

Rev
A

Key:

Existing Proposed SVP Boundary line

Existing drainage Proposed drainage Overhead

0 4 8 12 16 20

GRAPHIC SCALE: 1:200

No.	Description	Date
A	Client's comments (1)	31.03.26