



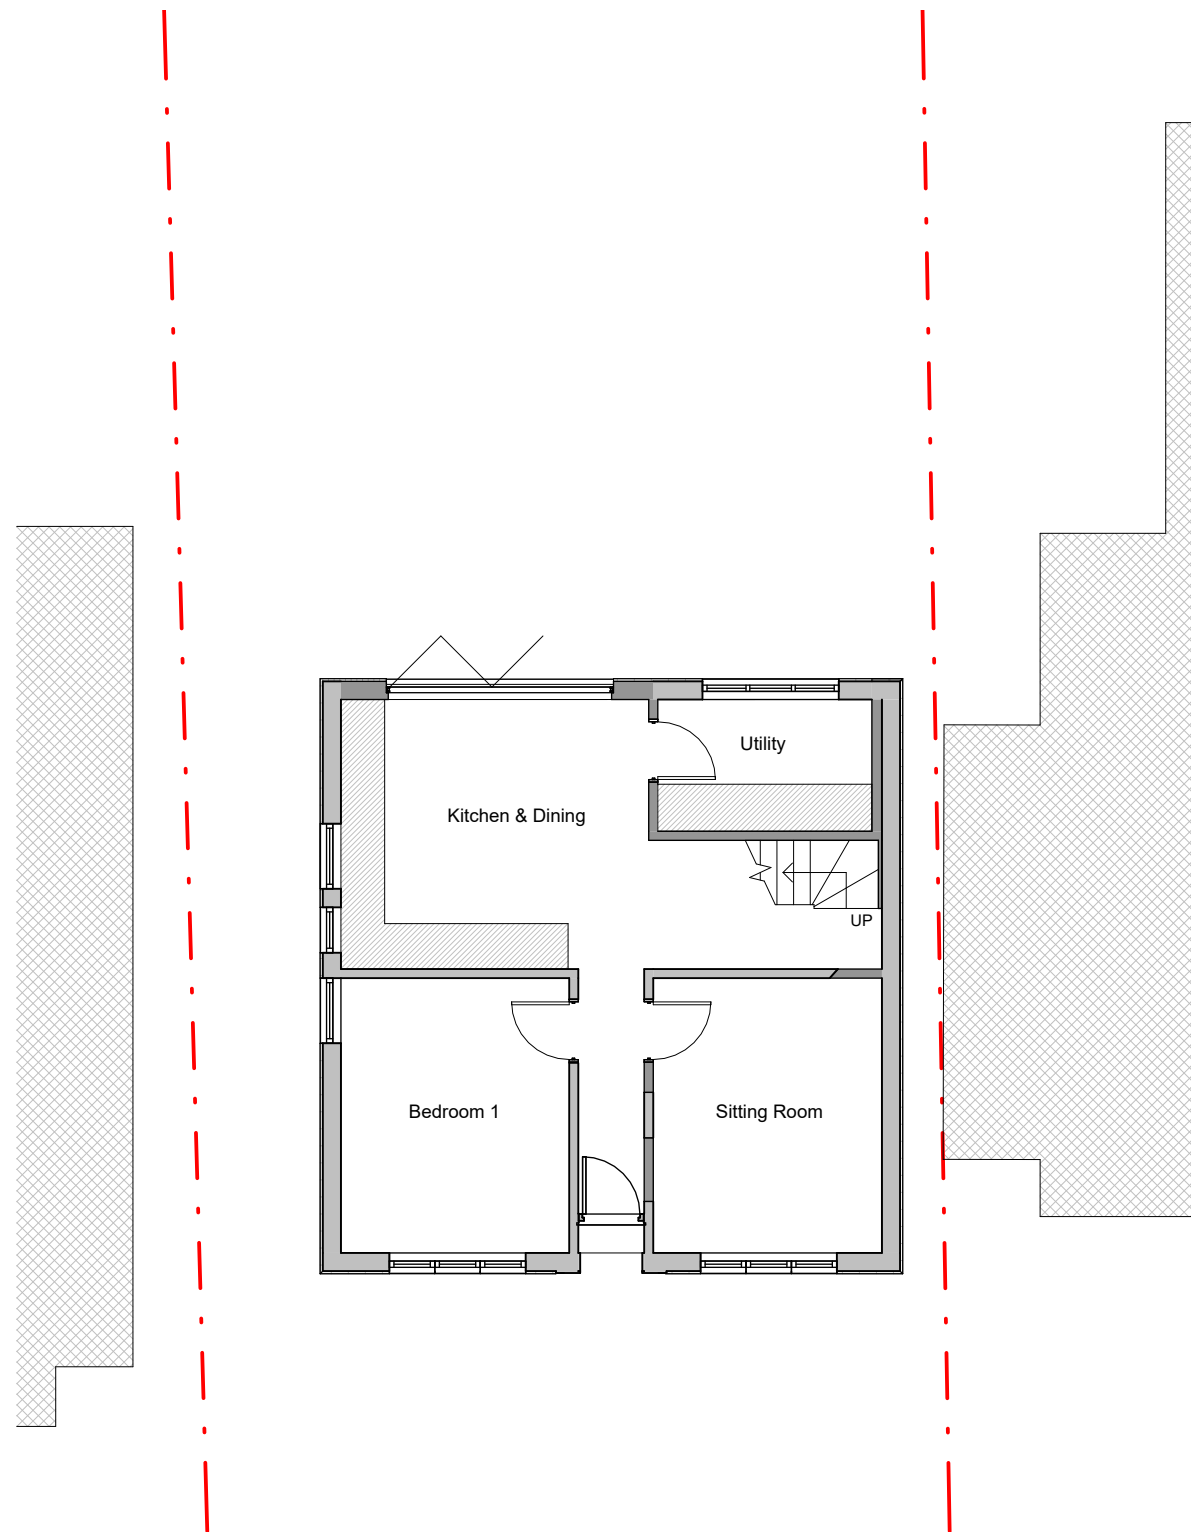

Ground Floor

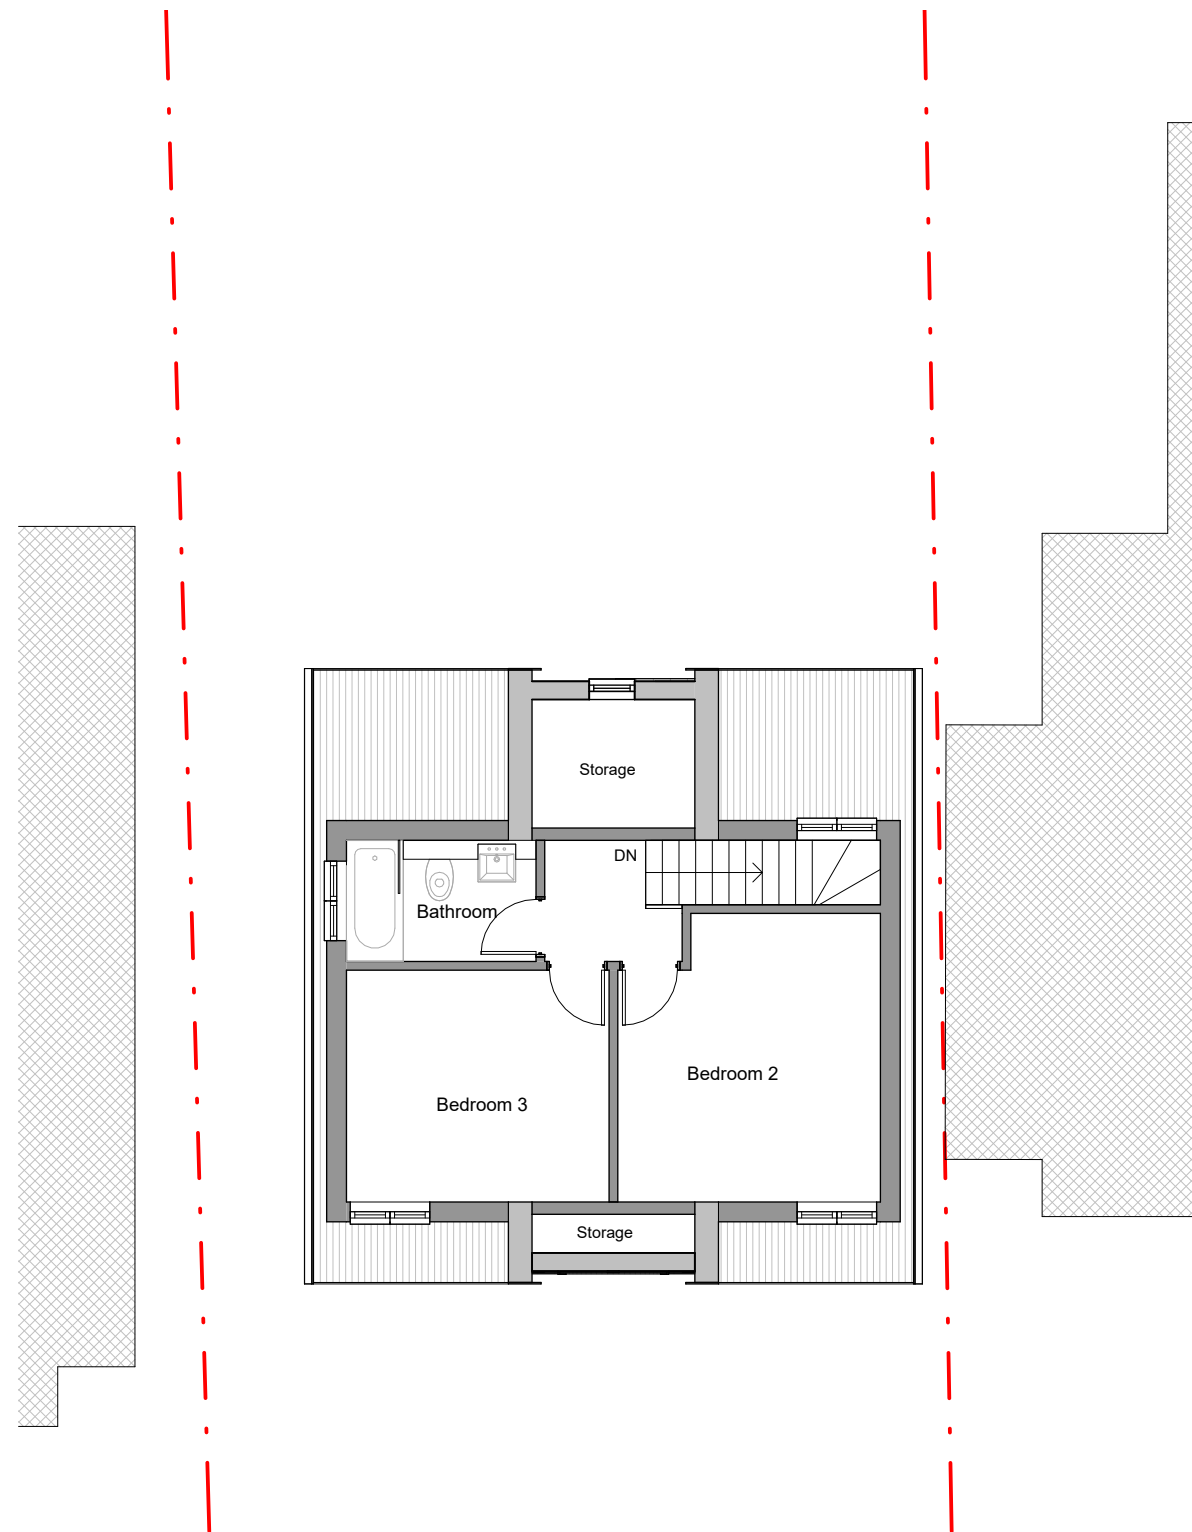

First Floor



FLUENT
ARCHITECTURAL DESIGN SERVICES
TEL: 0800 043 8838
E-MAIL: INFO@FLUENT-ADS.CO.UK
WEB: FLUENT-ADS.CO.UK

90 Matthewsgreen Rd Wokingham RG41 1JT

Proposed Floor Plans

Scale @ A3
1 : 100

Date
06.03.2026

Drawn by
MV

 
Drawing number
P.M.500

Project number
2528

Rev
A

Key:

Existing Proposed SVP Boundary line
Existing drainage Proposed drainage Overhead



No.	Description	Date
A	Client's comments (1)	31.03.26