

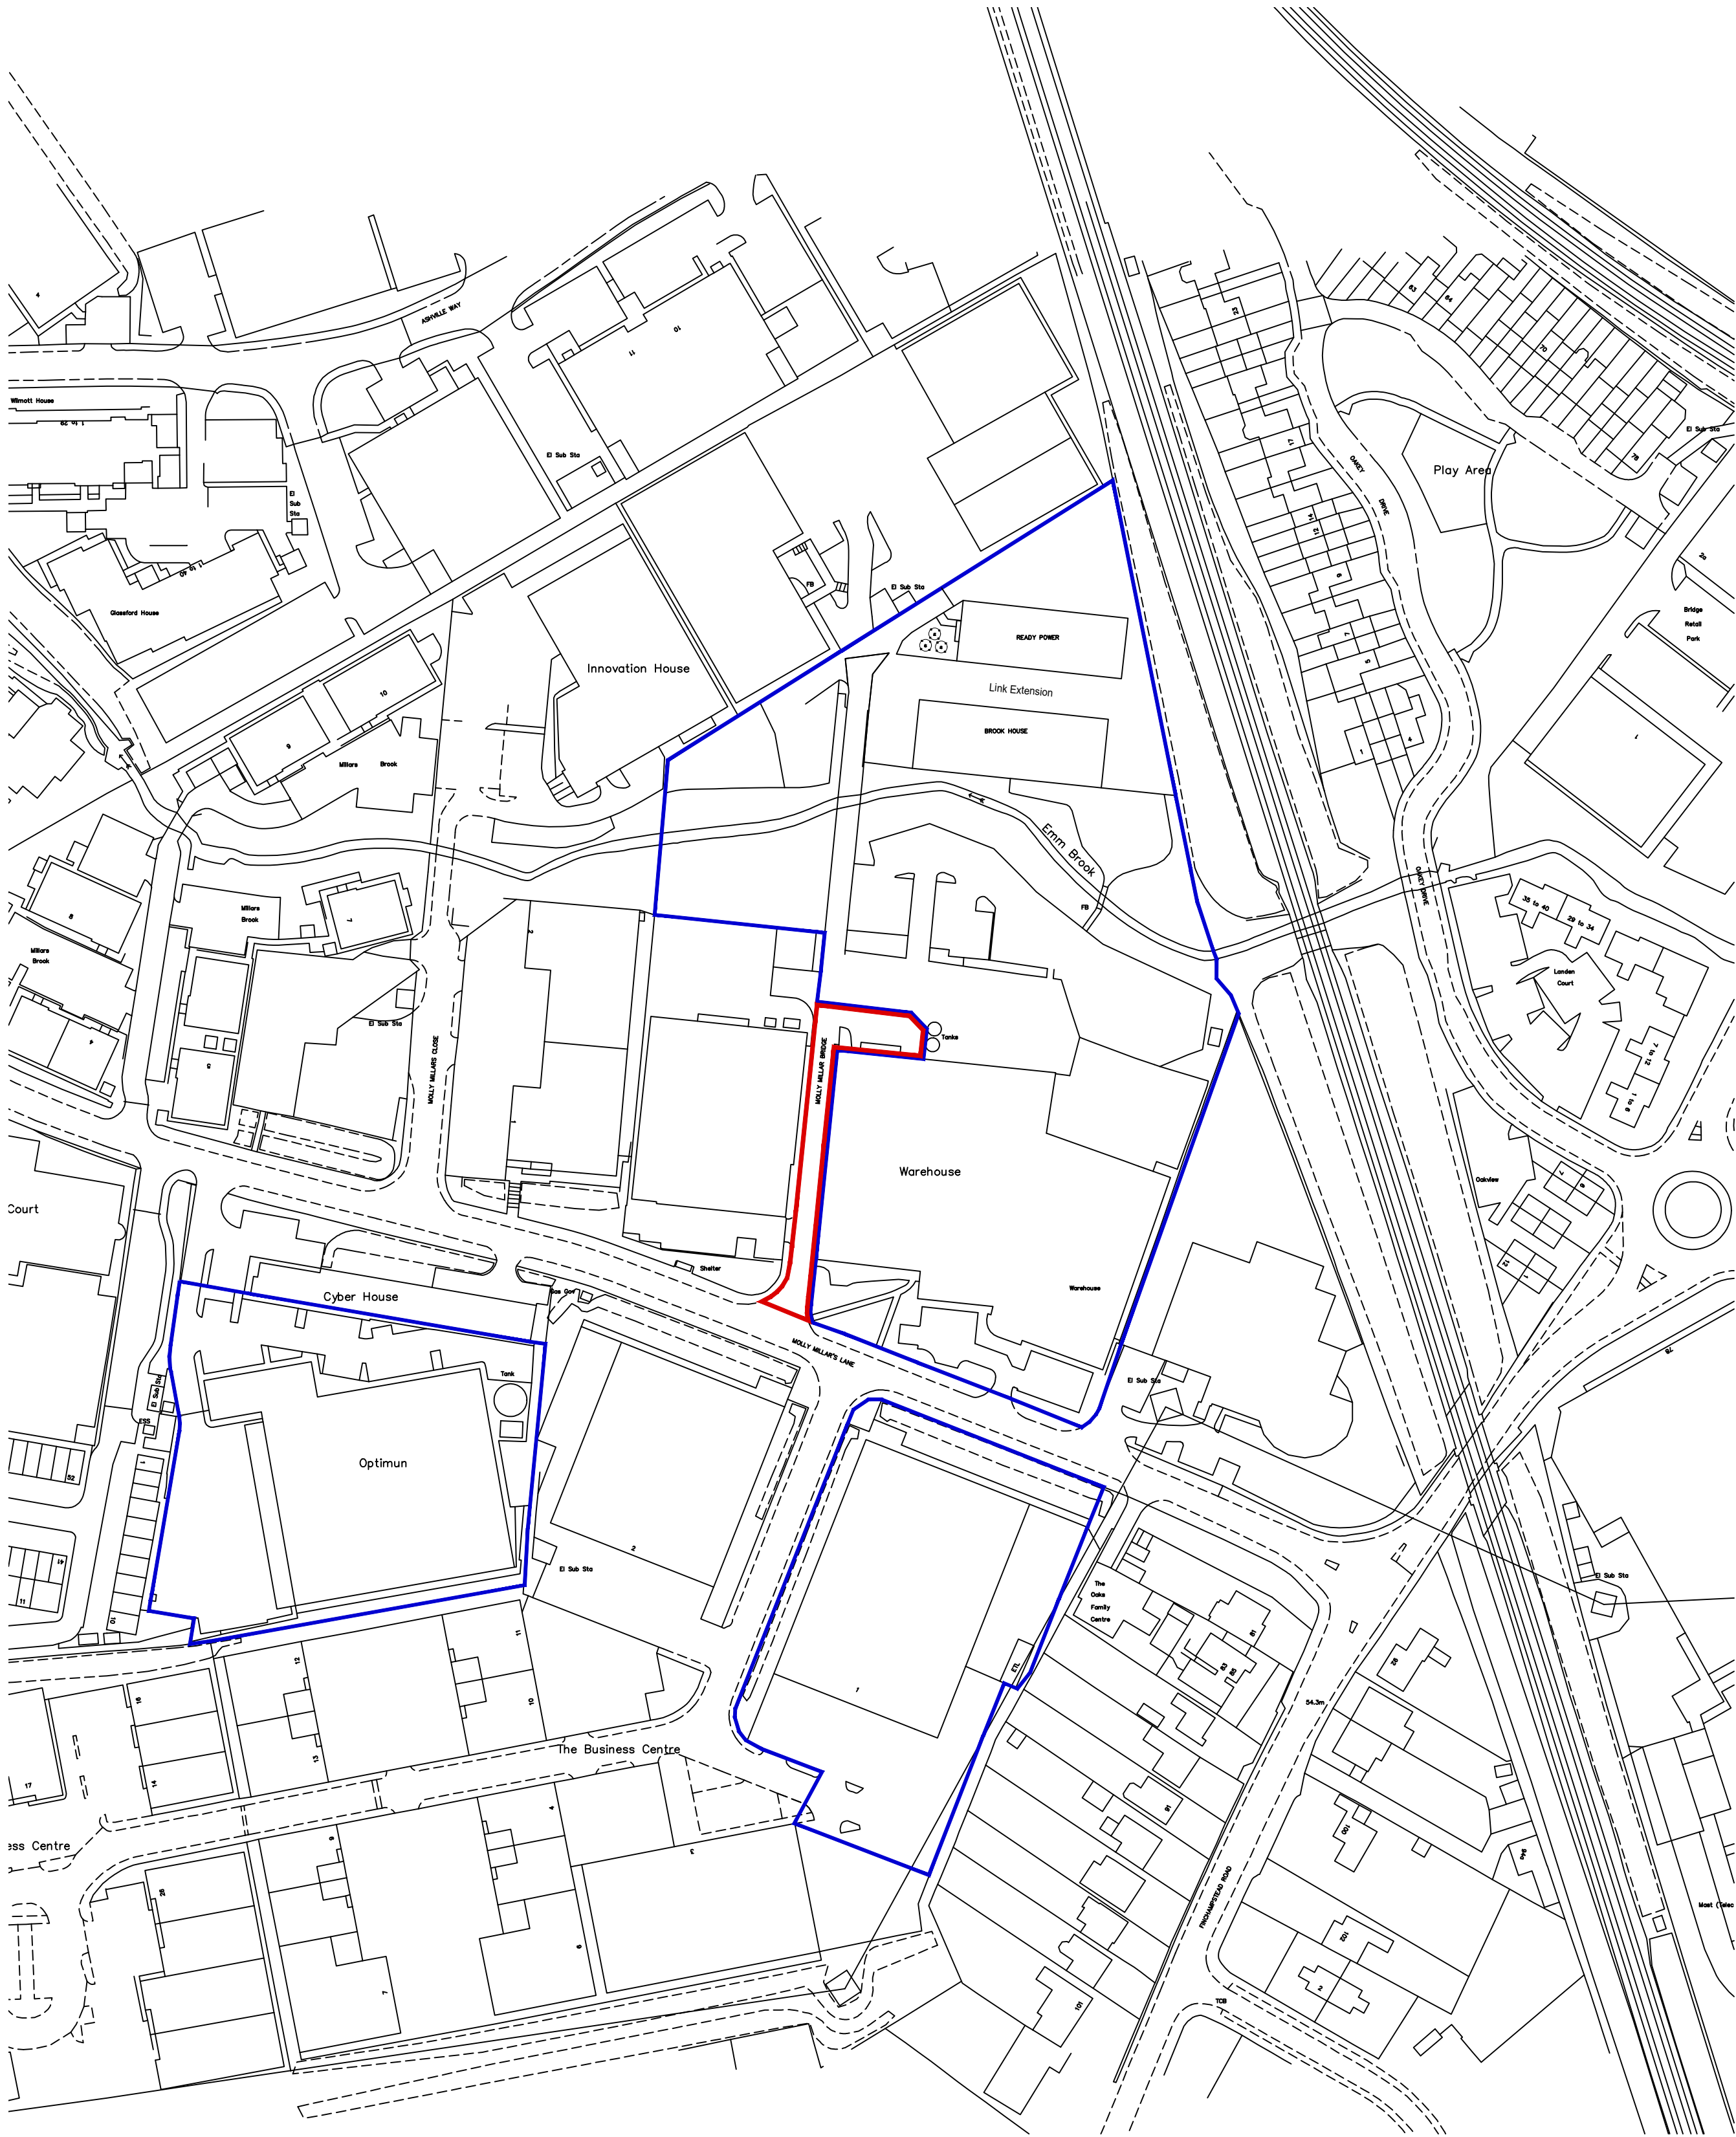


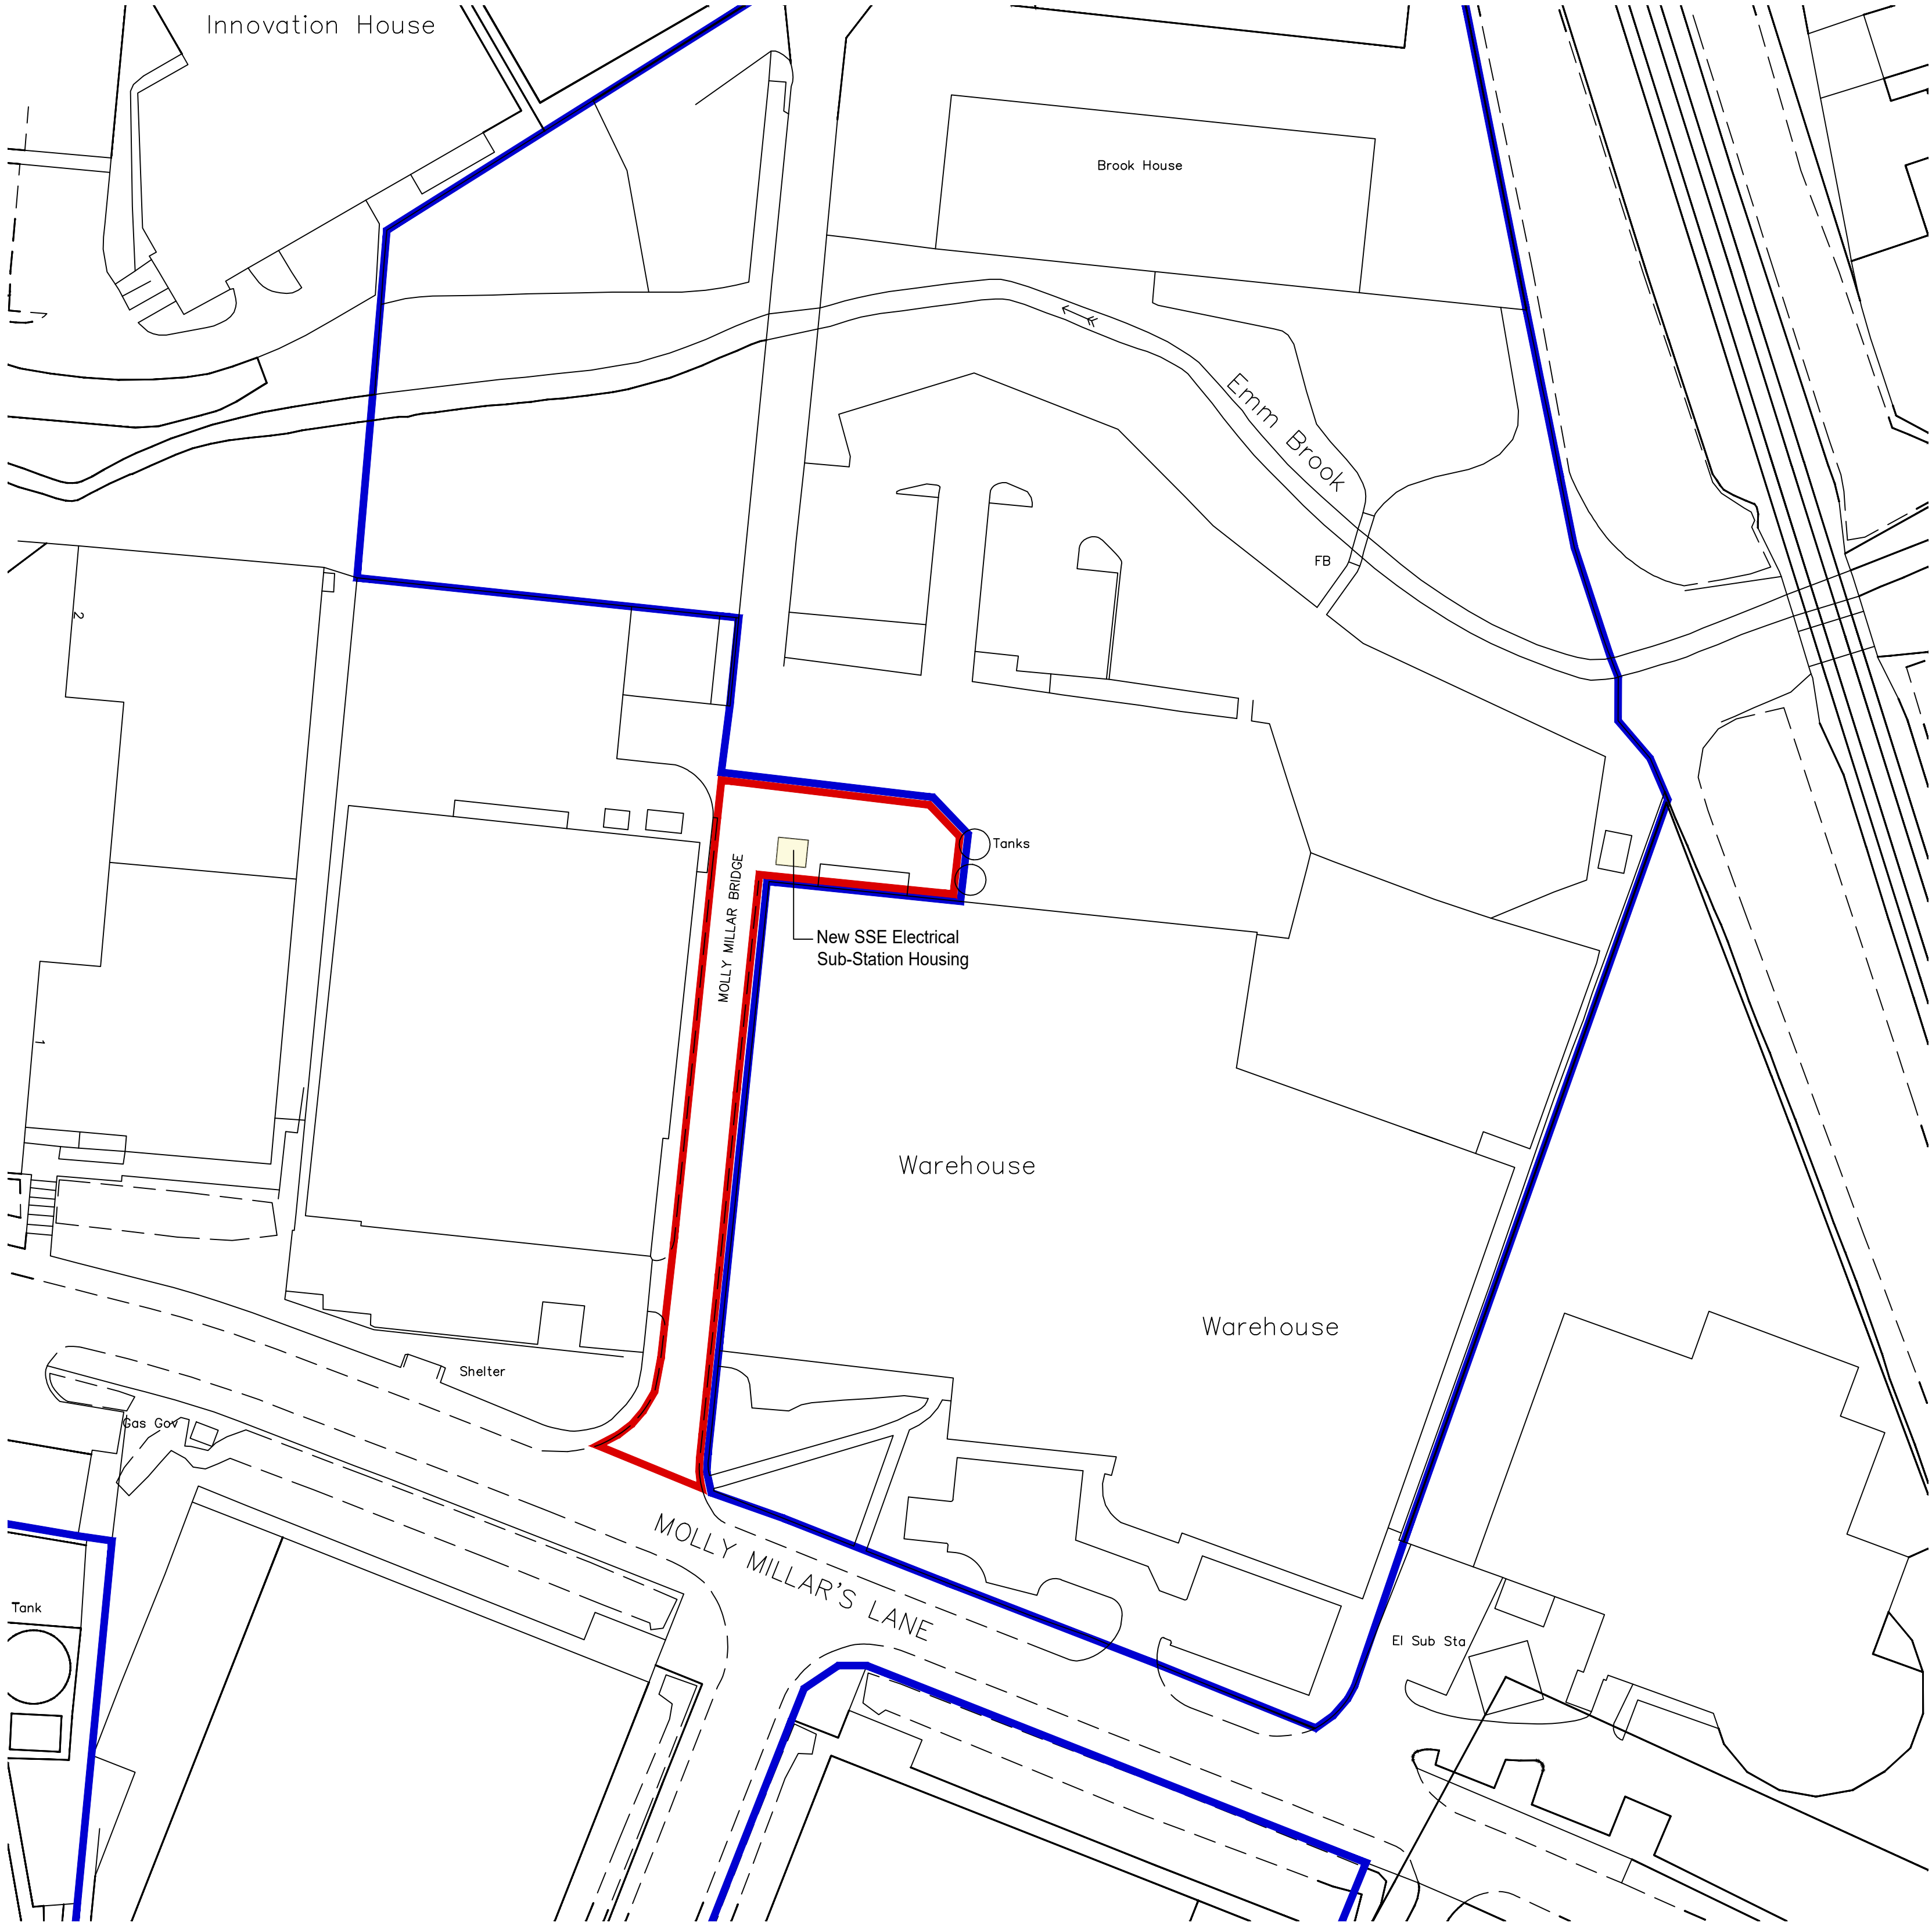

Location Plan

Scale 1:1250

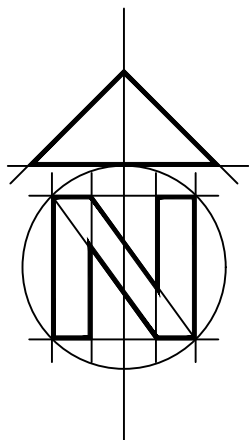

Site Plan

Scale 1:500

Rev A - North Point Added - Aug 2025

Bonney Architecture
PLANNING & TECHNICAL SERVICES

CLIENT Intersurgical Ltd 14 Hornbeam Close
Wokingham
RG41 4LR

JOB SSE ELECTRICITY SUPPLY
Intersurgical, Wok, RG41 2QP 07515 355 770
bonneyarchitecture@gmail.com

DRG SITE & LOCATION PLANS

SCALE As Shown DRAWN P Bonney DATE June 2025 BA 0270 | 50 /04|A

1:500 scale Bar
This Drawing has been produced for printing onto A2 size paper.
If printing on A3 please use the scale below for reference.



1:1250 scale Bar
This Drawing has been produced for printing onto A2 size paper.
If printing on A3 please use the scale below for reference.

