


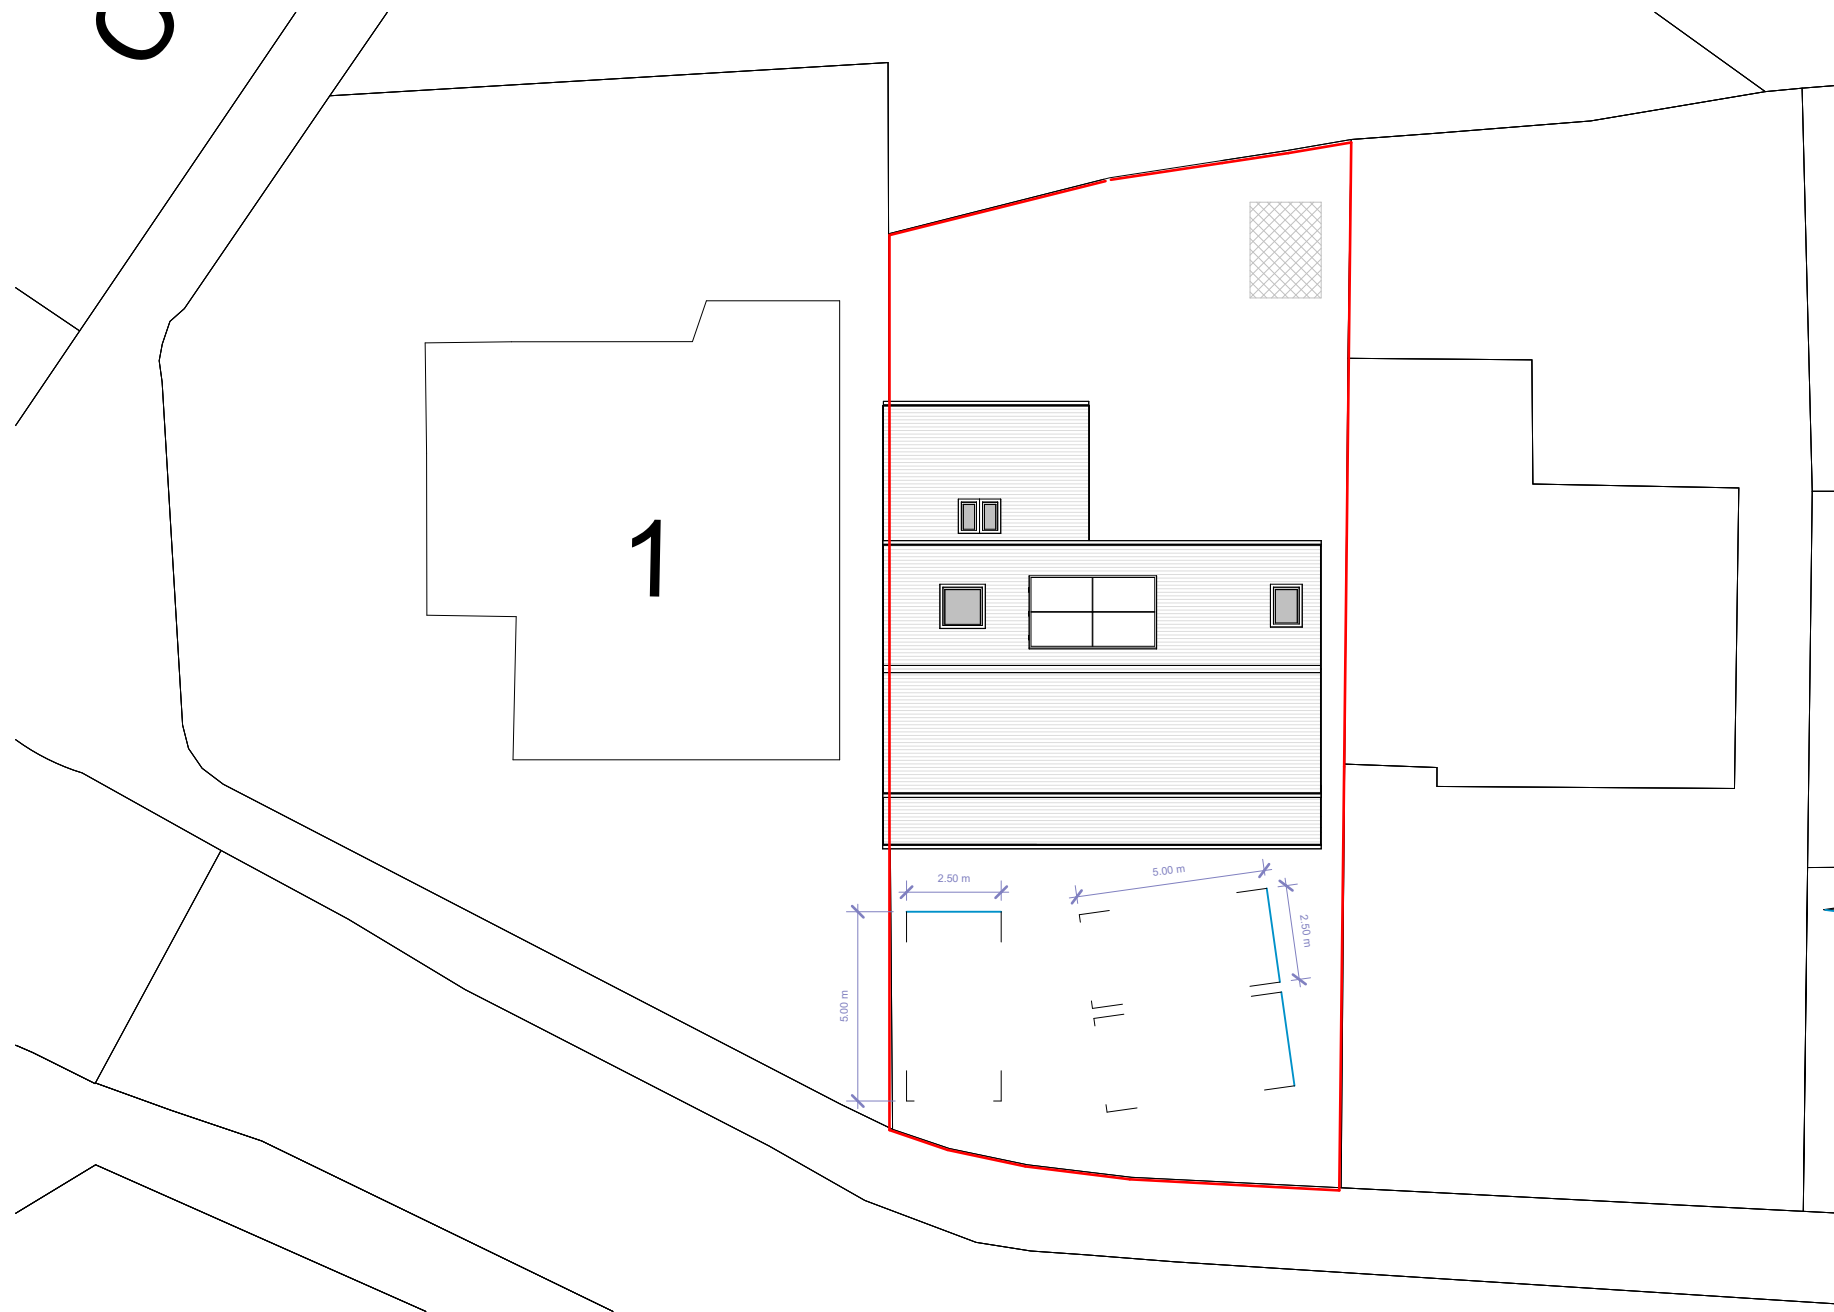


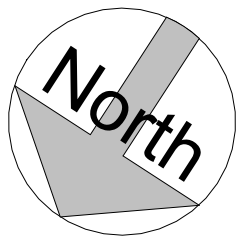

Site Plan

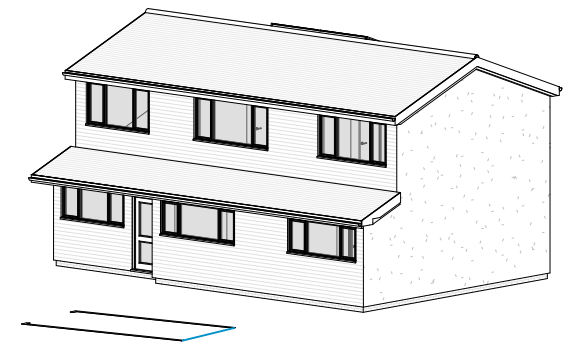

3D View 1

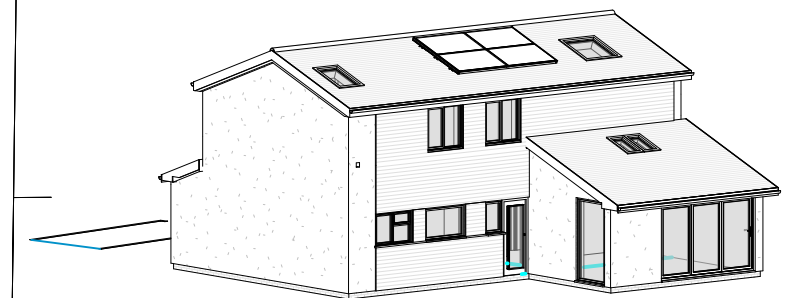

3D View 2



**FLUENT**  
ARCHITECTURAL DESIGN SERVICES  
TEL: 0800 043 8838  
E-MAIL: INFO@FLUENT-ADS.CO.UK  
WEB: FLUENT-ADS.CO.UK

3 Wessex Gardens, Reading

Proposed Site Plan and 3D Views

Scale @ A3  
1 : 200

Date  
13.05.24

Drawn by  
S.G

 
Drawing number  
P.M.400

Project number  
2291.03

Rev  
E

Key:

Existing Proposed SVP Boundary line  
Existing drainage Proposed drainage Overhead



| No. | Description           | Date     |
|-----|-----------------------|----------|
| A   | First draft           | 13.05.24 |
| B   | Client's comments (2) | 23.05.24 |
| C   | Client's comments (3) | 25.07.24 |
| D   | Client's comments (4) | 29.08.24 |
| E   | Planning amendment    | 17.12.24 |
|     |                       |          |
|     |                       |          |