



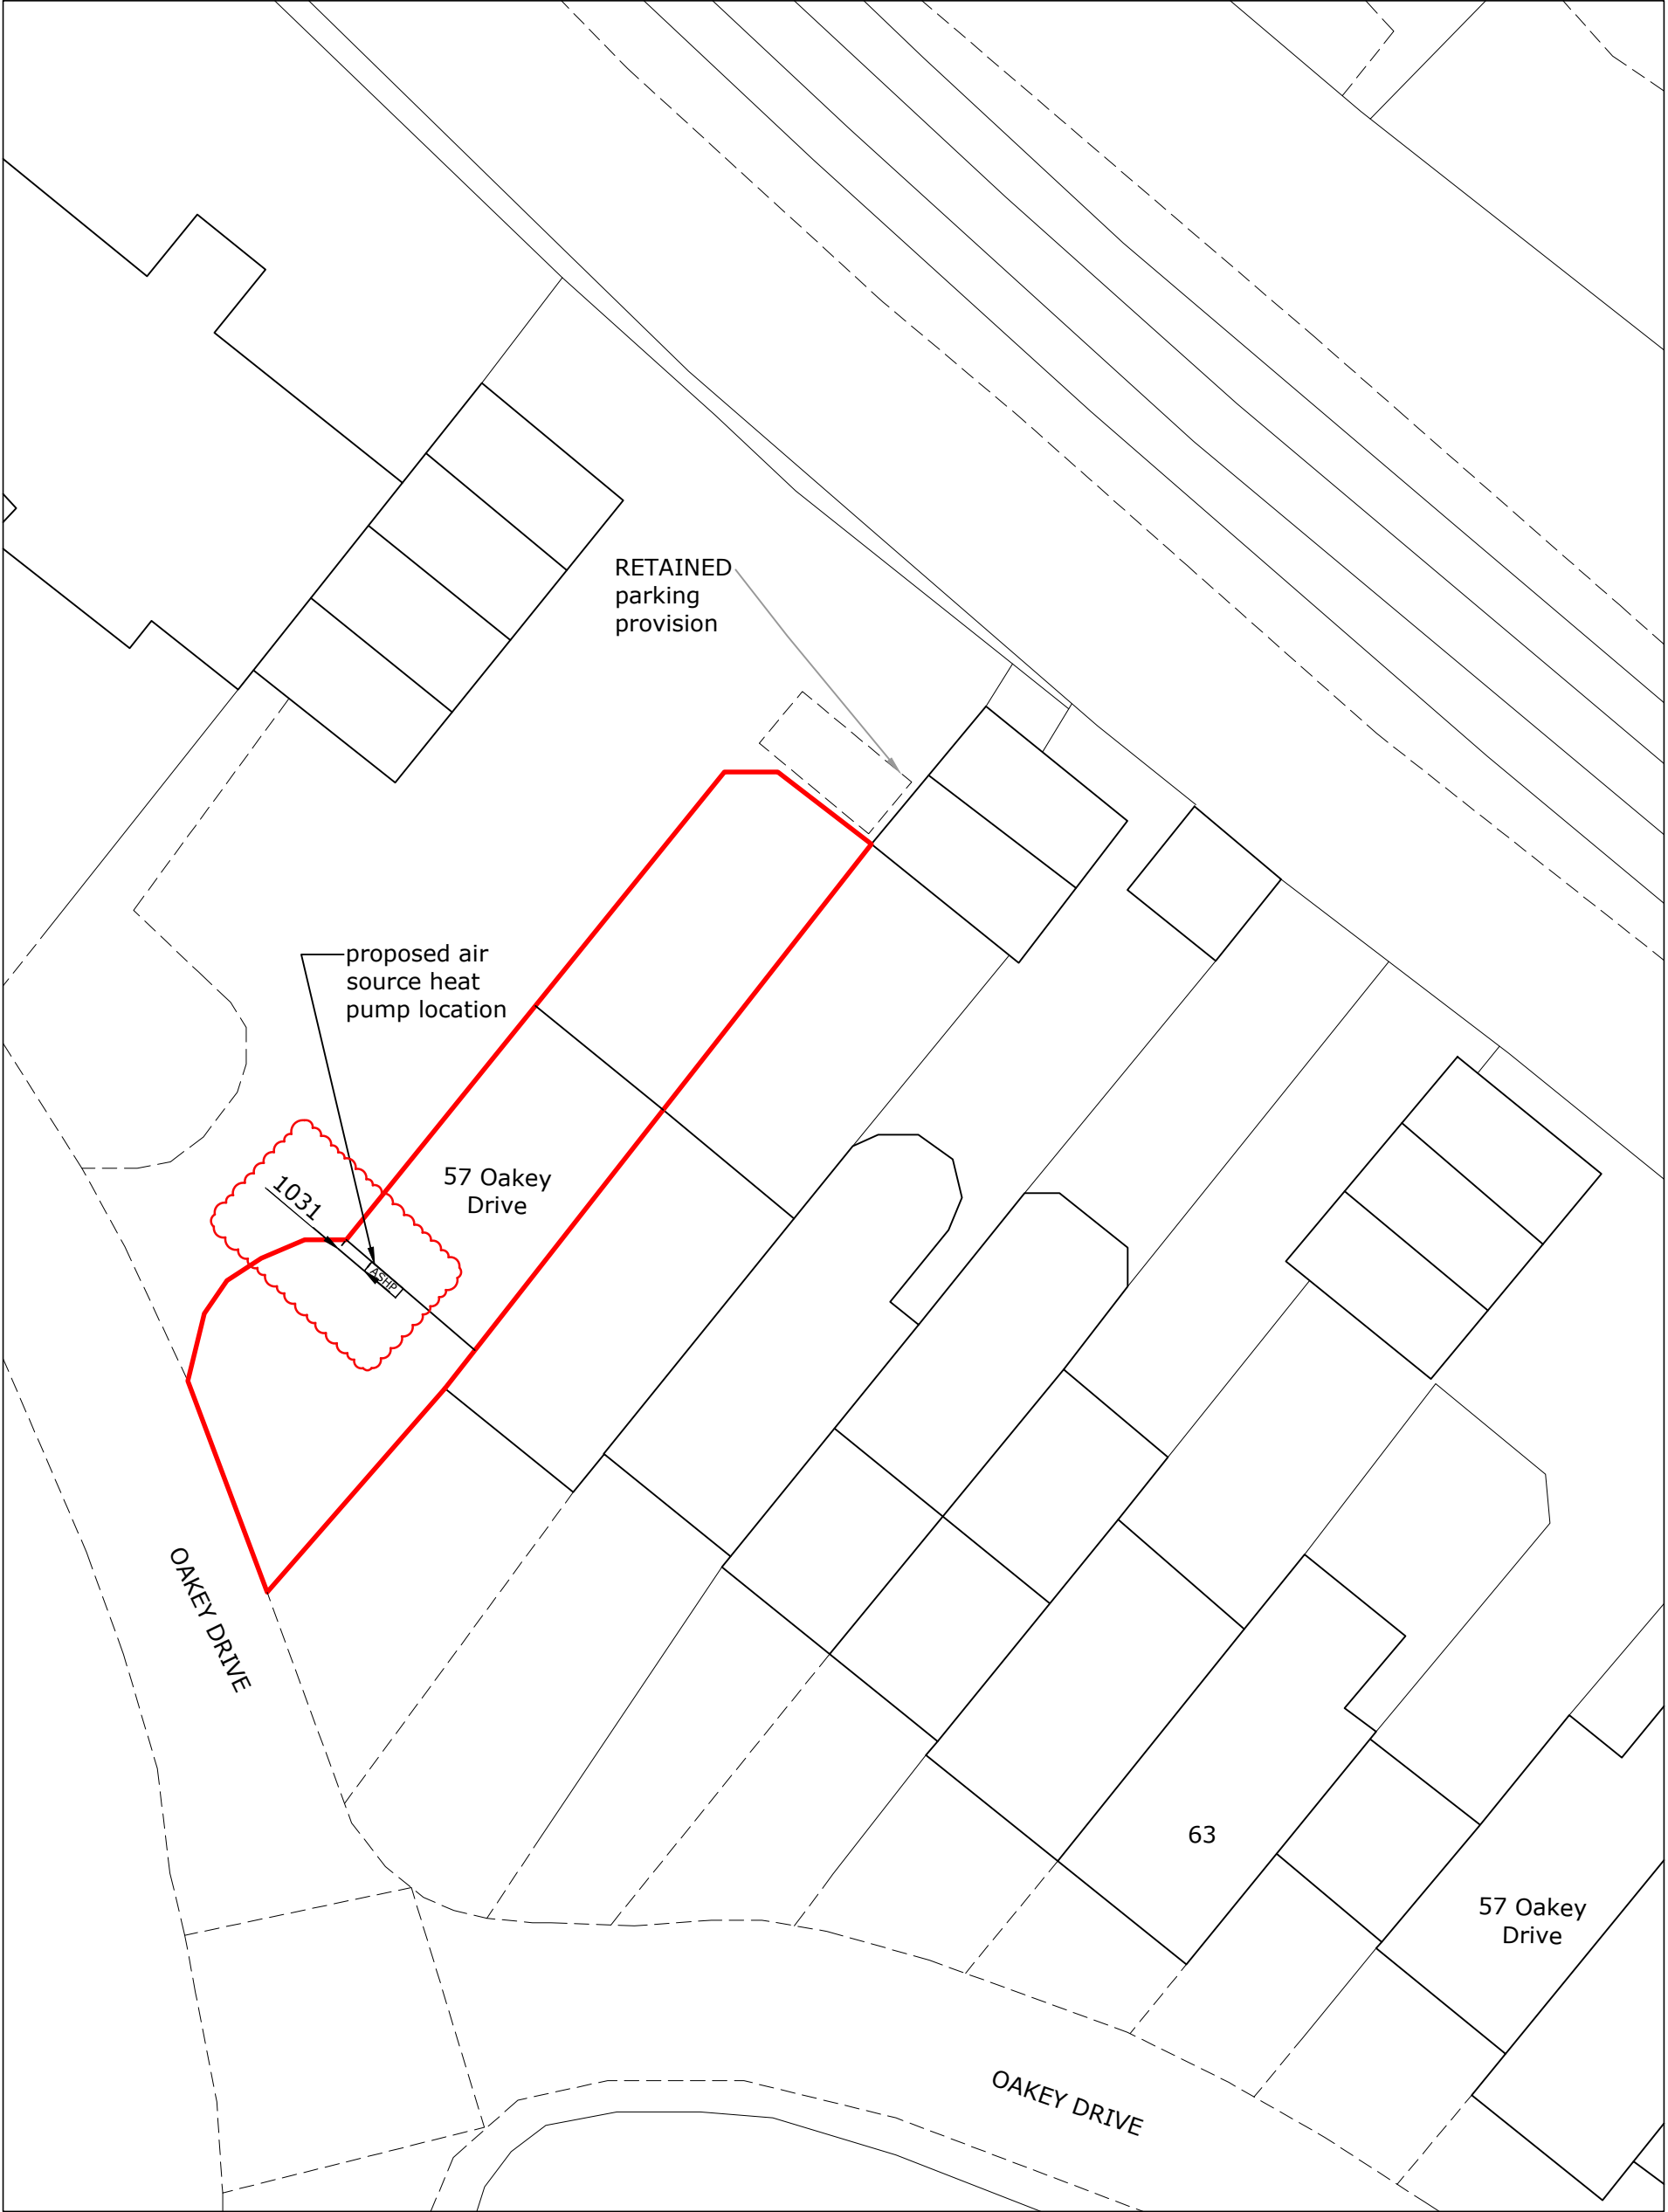

1:200 0 2 4 6 8 10 12 14 16 18 20

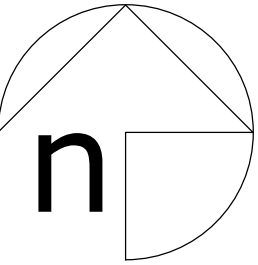

octopusenergy
services

Accredited by:


Client/Project:
Robert Westmancoat
57 Oakey Drive, Wokingham,
RG40 2DT

Project status:
PLANNING

Drawing title:
Site plan as proposed

C	Air source heat pump wall mounted, location adjusted	AW	03/12/24
B	Oakley label corrected to Oakey	AW	18/11/24
A	Drawings updated, minor changes to ensure consistency, air source heat pump wall mounted	AW	07/11/24
-	Description: Installation of 1No air source heat pump to the front	By:	Date:
Rev:	Description:	By:	Date:

Scale: 1:200	Paper Size: A2	Drawn: TS & AW	Checked:
Project ID: J-47E890D0	Drawing No: 02	Revision: C	Date: 11.10.2024