




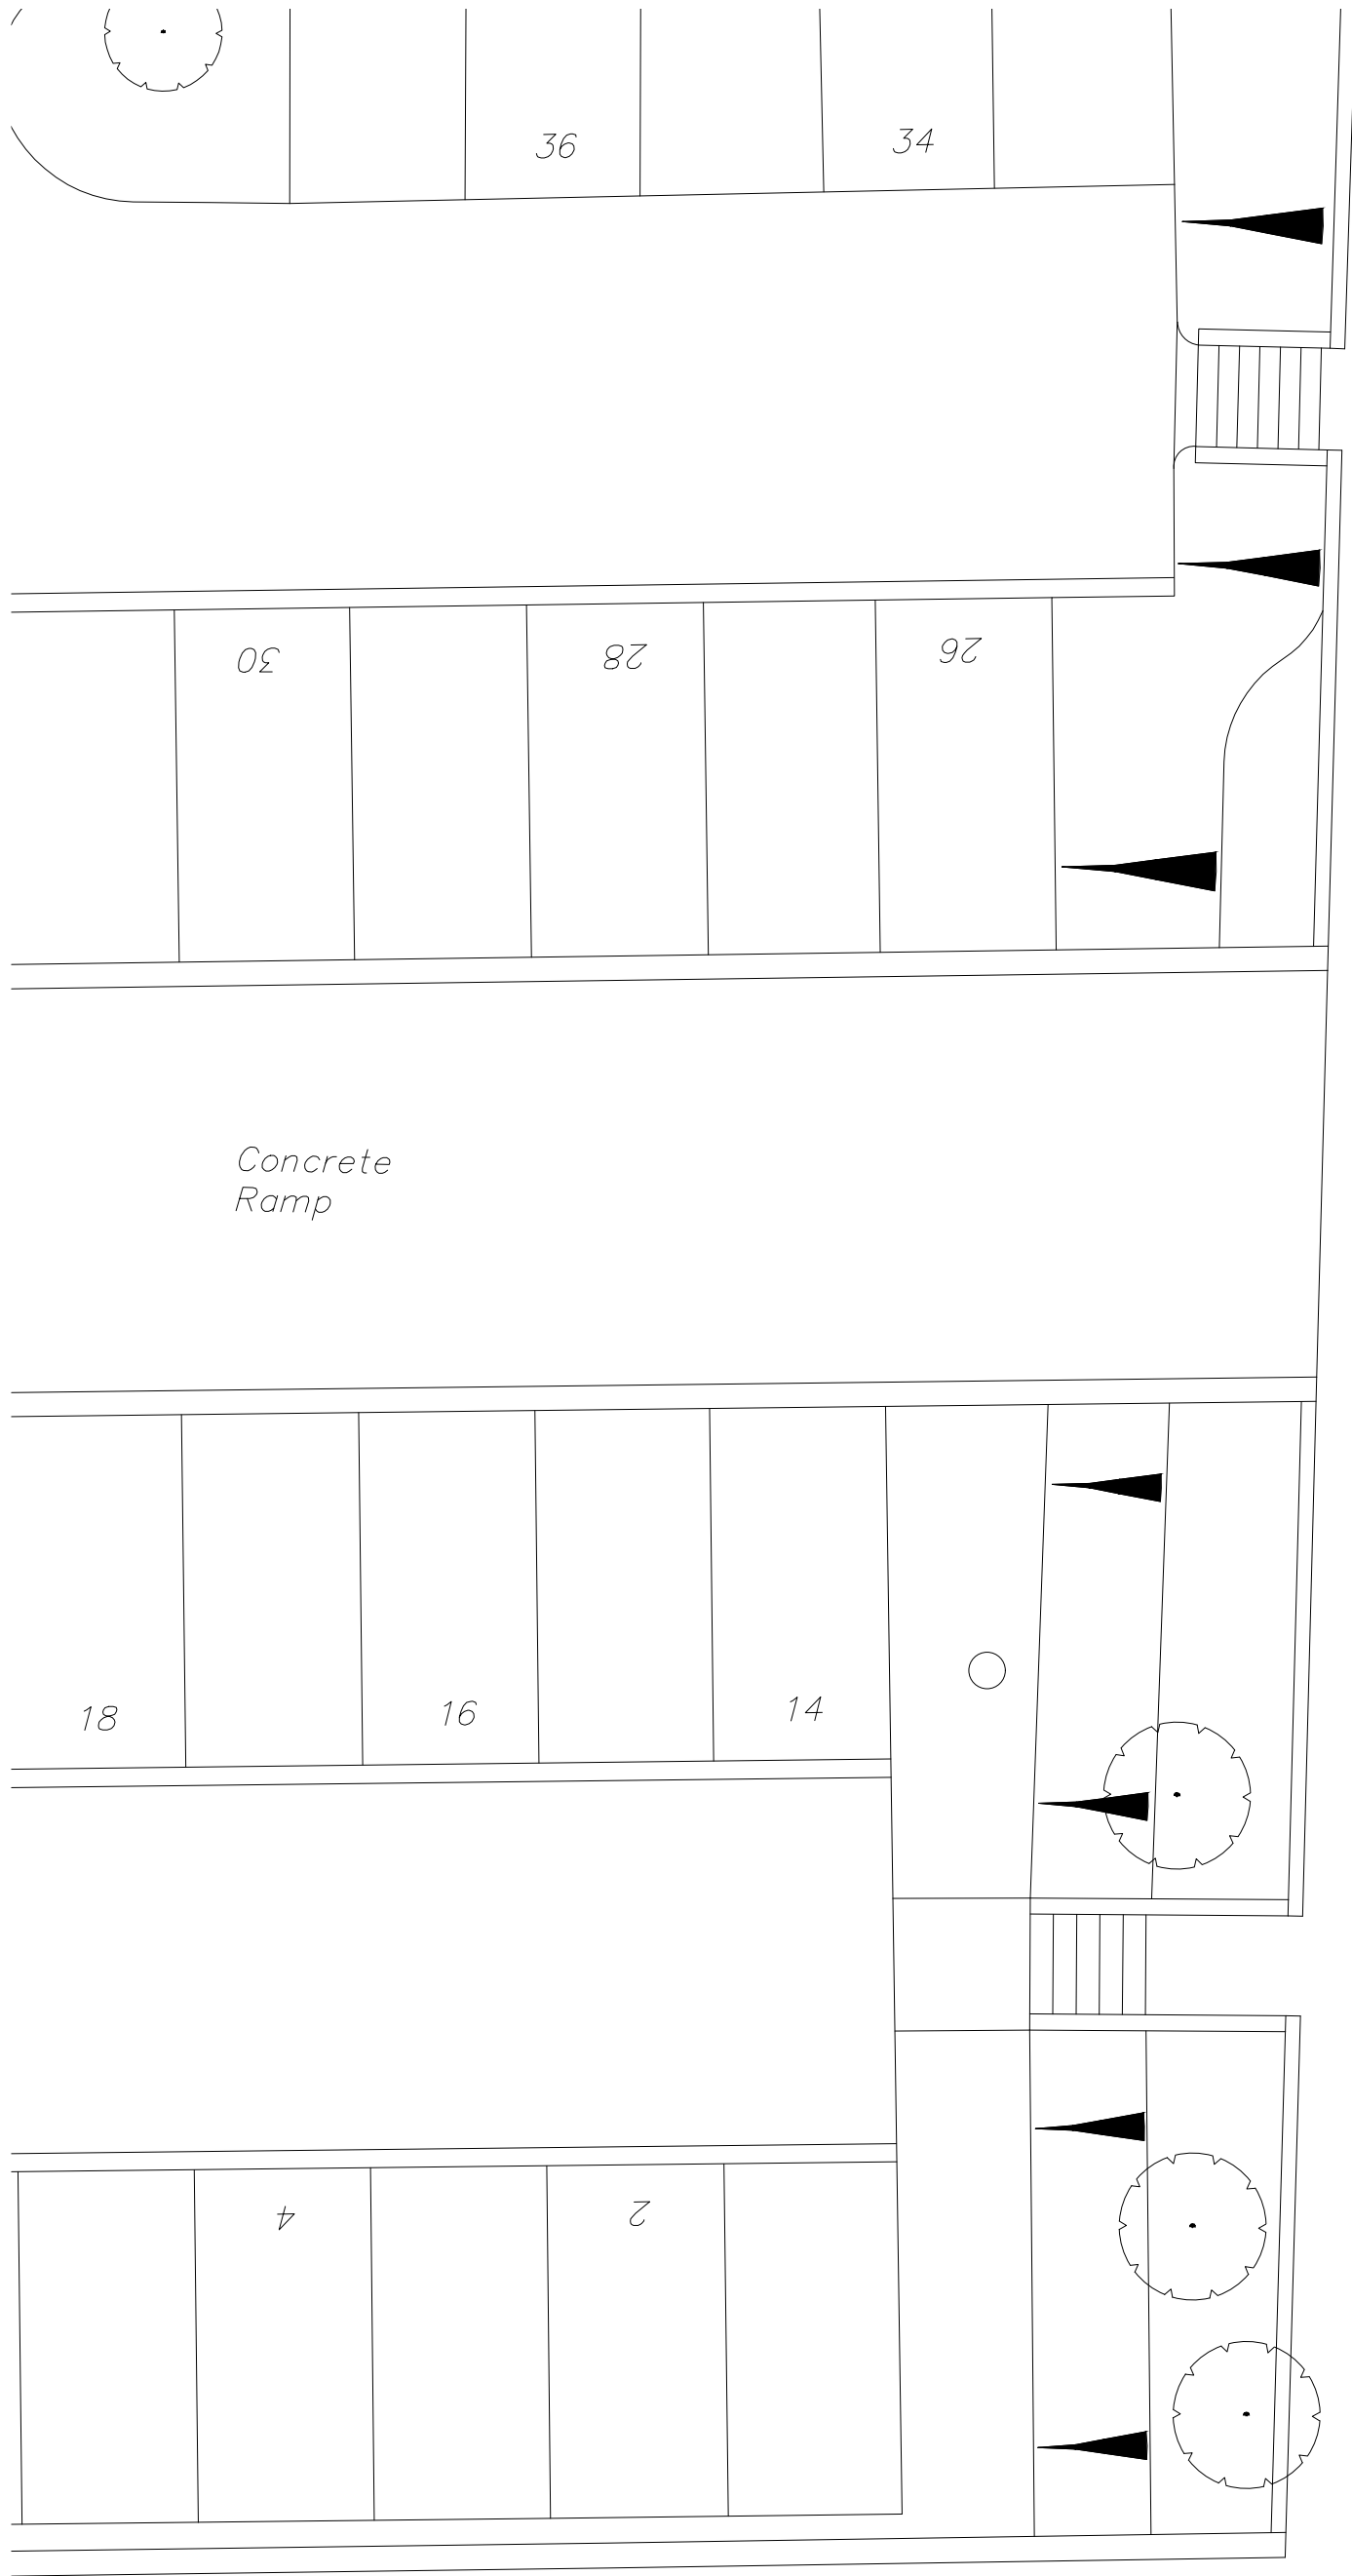

Molly Millers Bridge

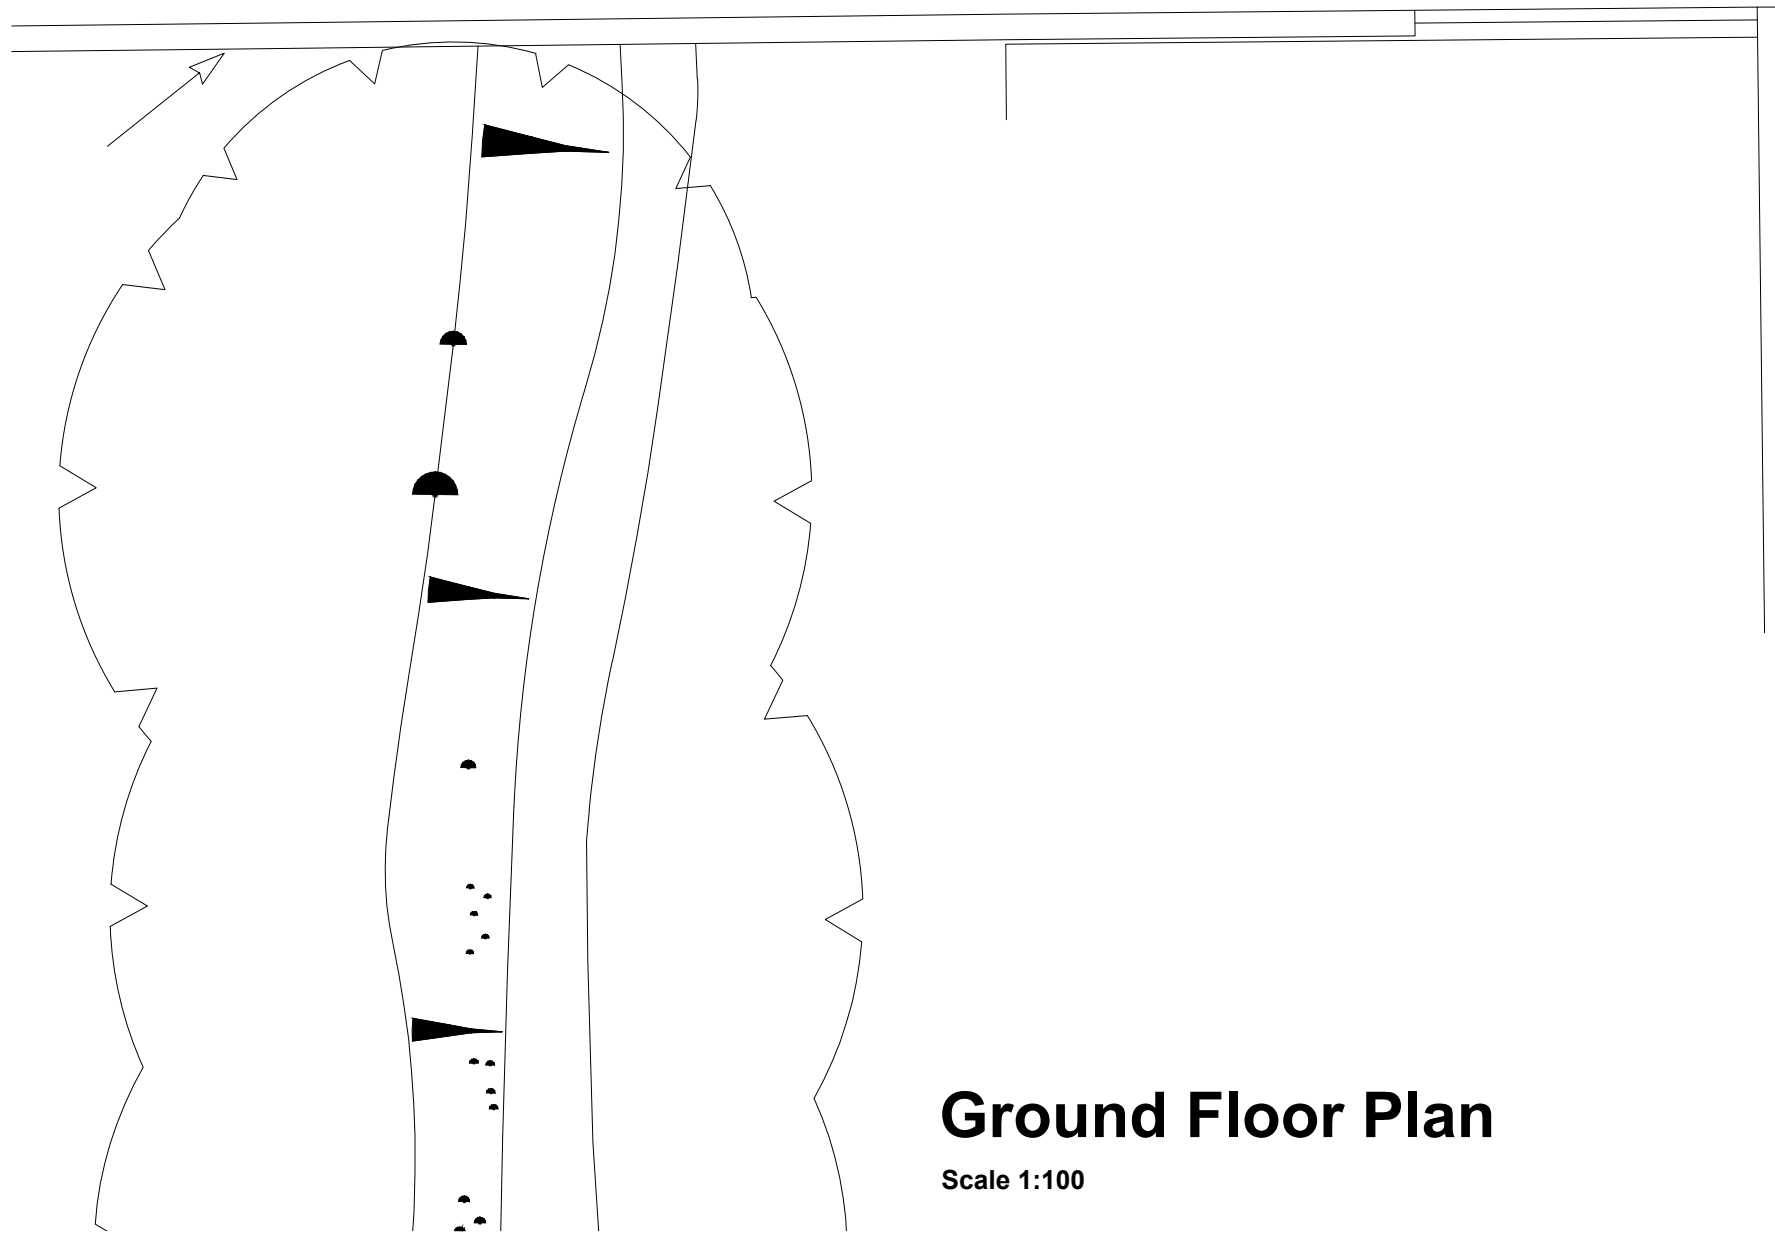

Ground Floor Plan
Scale 1:100

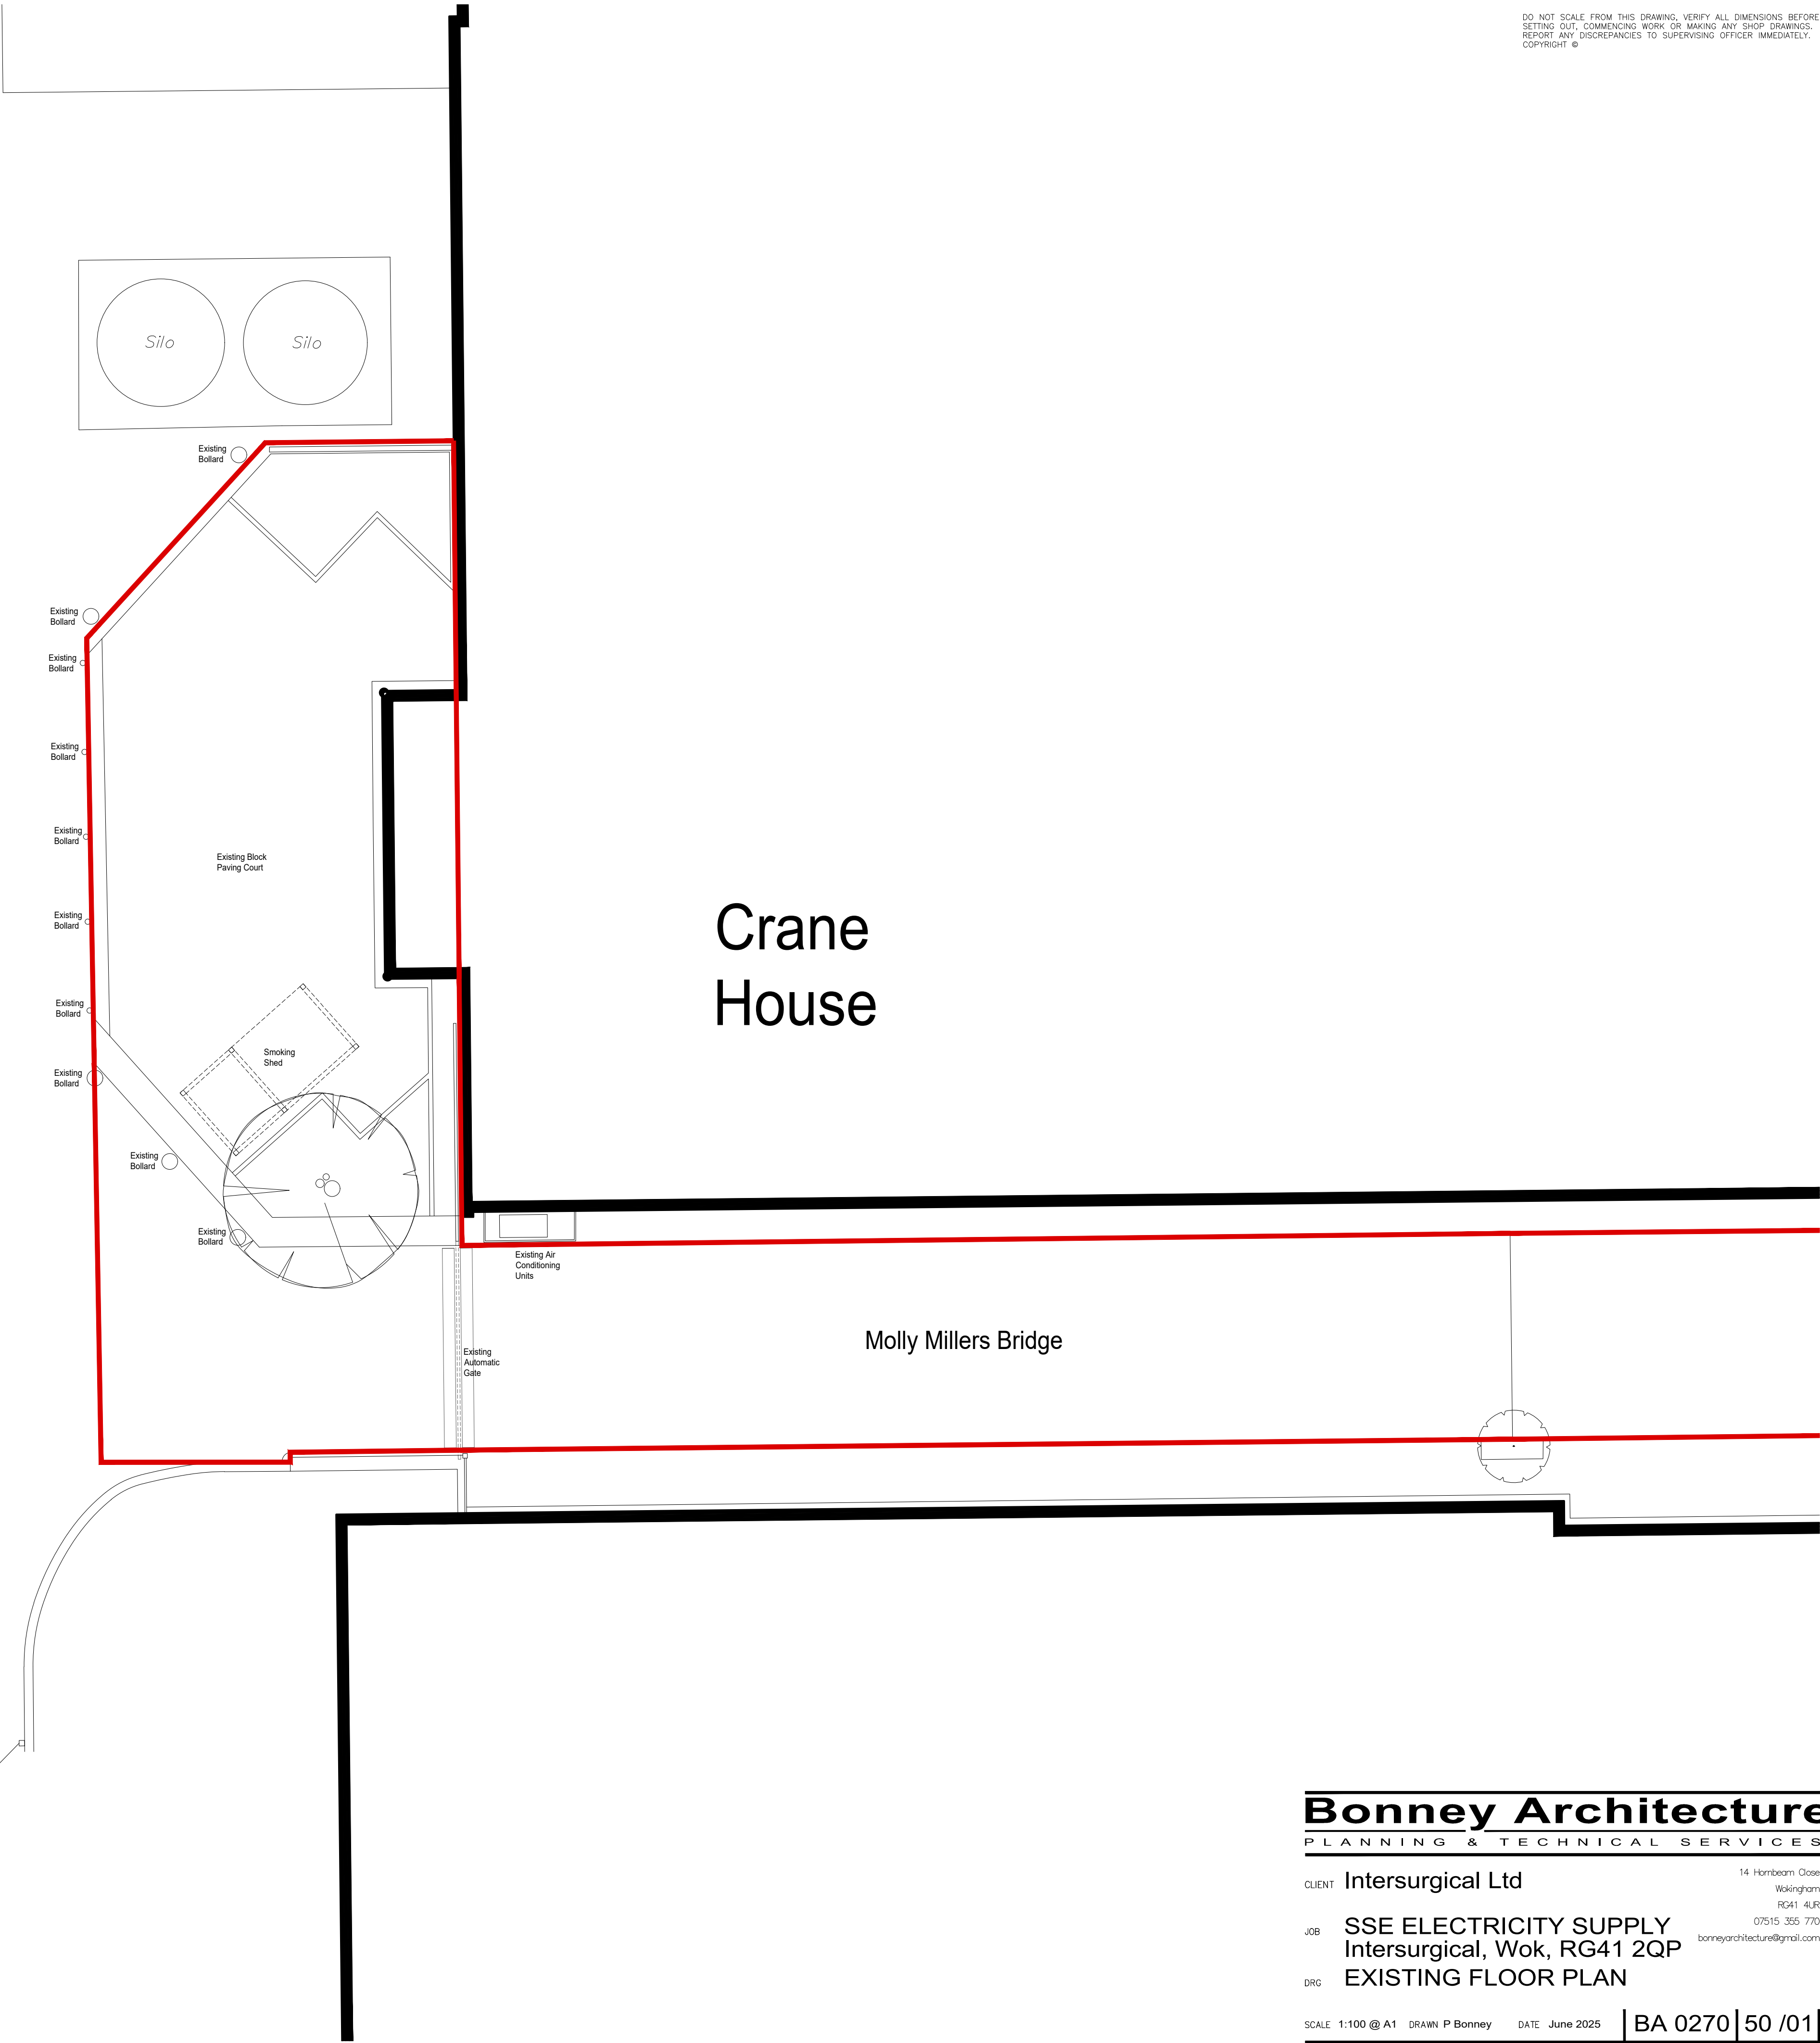

DO NOT SCALE FROM THIS DRAWING. VERIFY ALL DIMENSIONS BEFORE SETTING OUT. COMMENCING WORK OR MAKING ANY SHOP DRAWINGS. REPORT ANY DISCREPANCIES TO SUPERVISING OFFICER IMMEDIATELY. COPYRIGHT ©

Bonney Architecture
PLANNING & TECHNICAL SERVICES

CLIENT	Intersurgical Ltd	14 Hornbeam Close Wokingham RG41 4LR
JOB	SSE ELECTRICITY SUPPLY Intersurgical, Wok, RG41 2QP	07515 355 770 bonneyarchitecture@gmail.com
DRG	EXISTING FLOOR PLAN	

SCALE	1:100 @ A1	DRAWN	P Bonney	DATE	June 2025	BA 0270	50 /01
-------	------------	-------	----------	------	-----------	---------	--------