




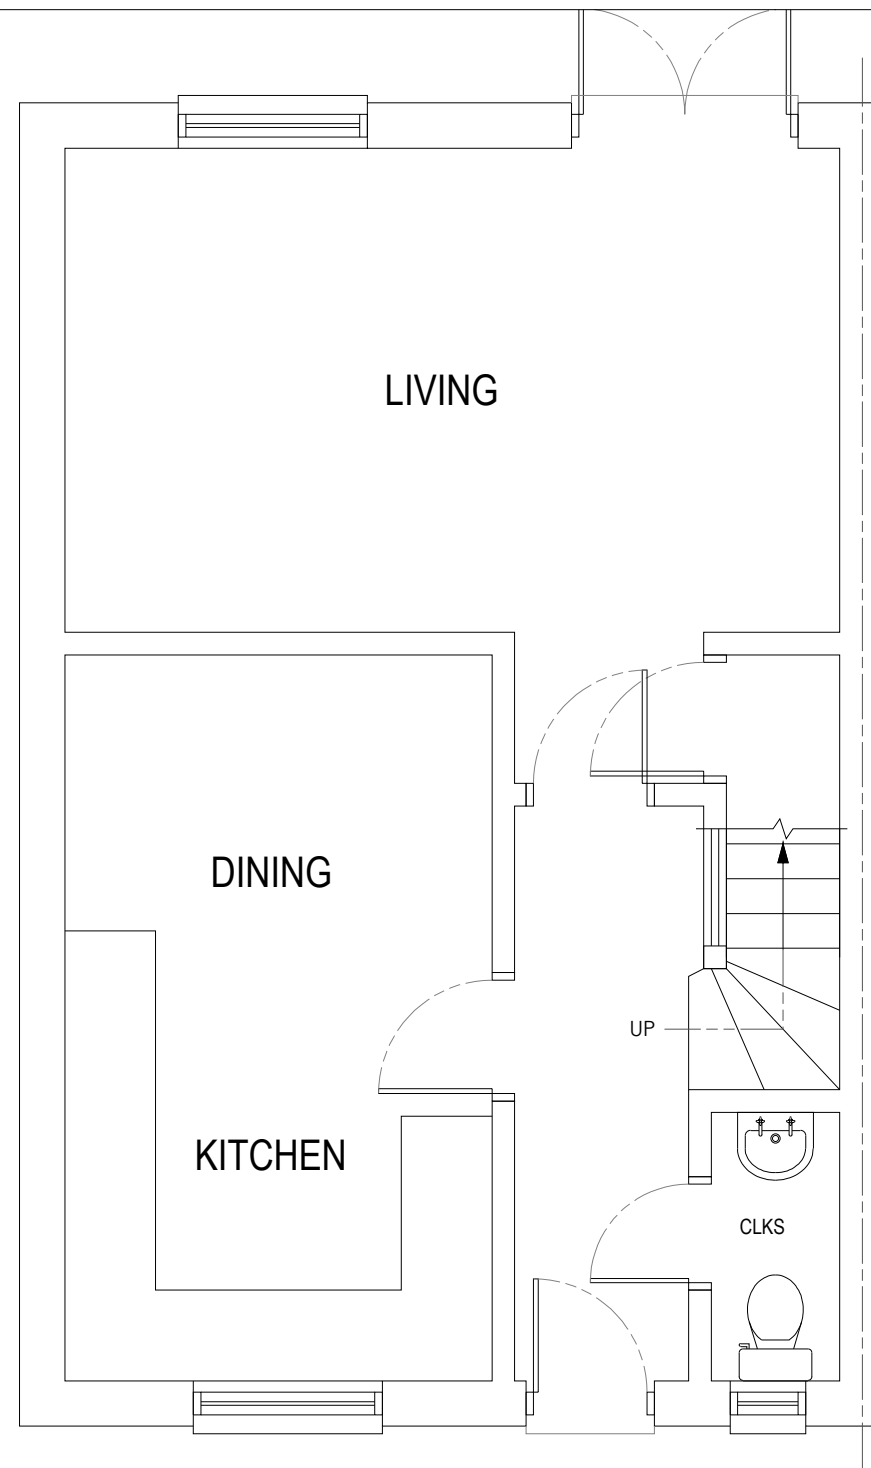

GROUND FLOOR

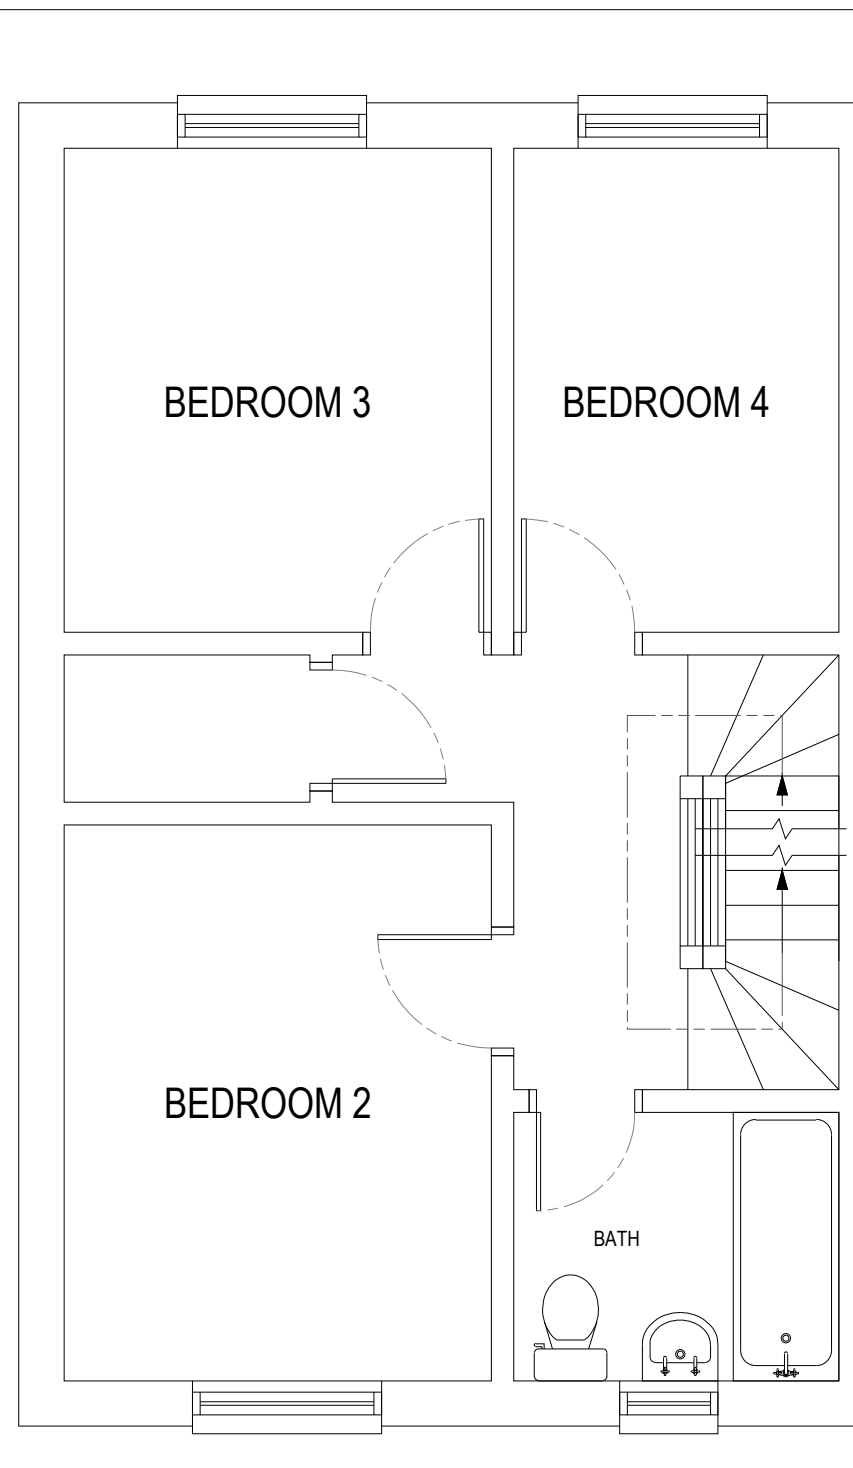

1st FLOOR

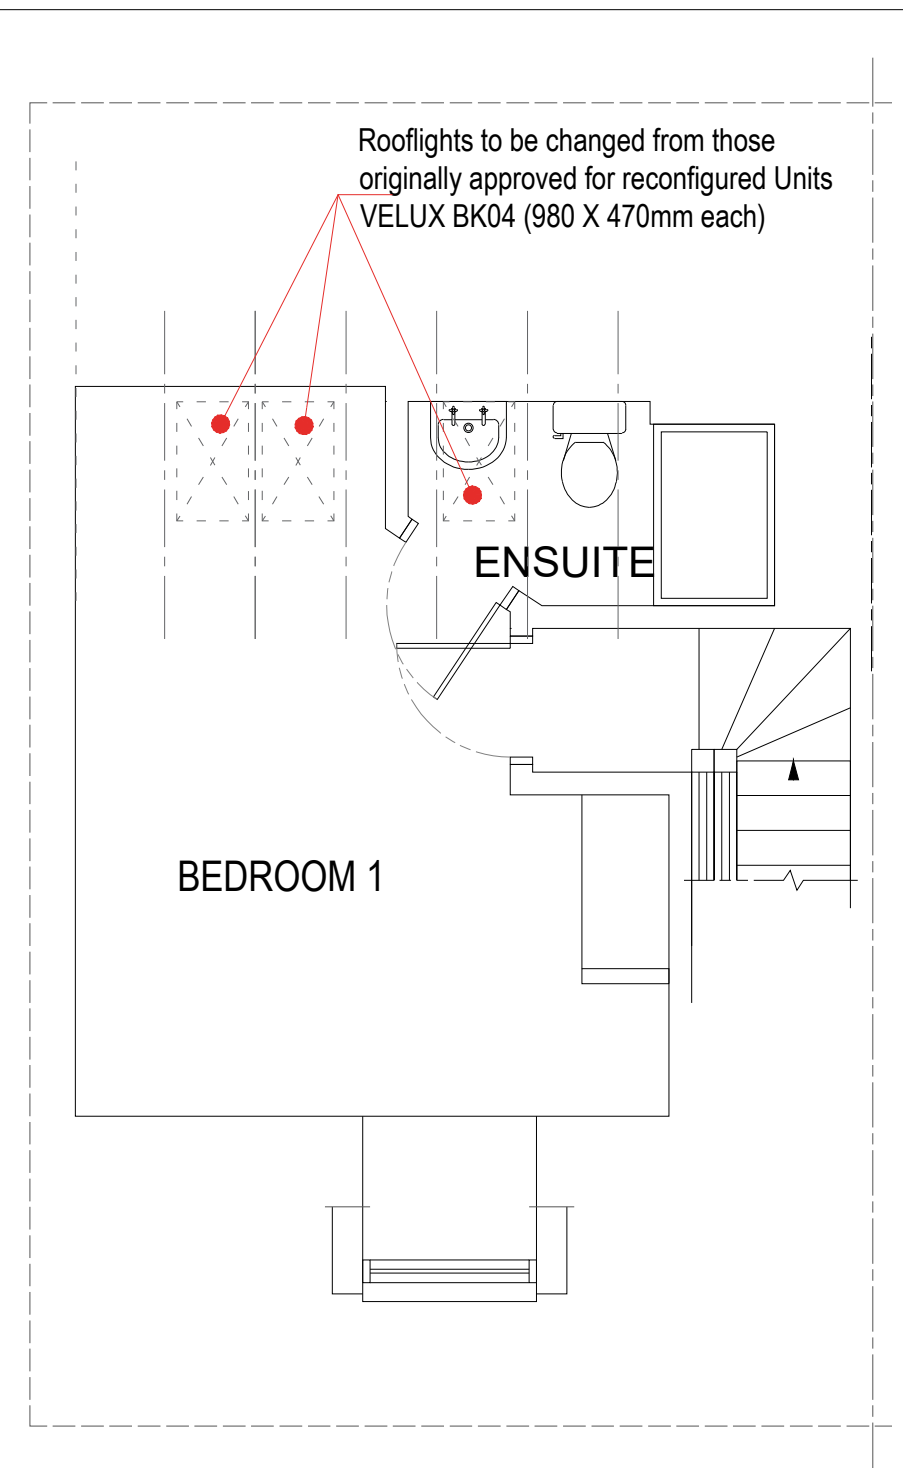

2nd FLOOR


Rooflights to be changed from those originally approved for reconfigured Units VELUX BK04 (980 X 470mm each)

Floor Plan drawing in support of Application for a Non-Material Change to Planning Consent 242401 dated 24 October 2024



Seine Consult Ltd

The Copse, Fanny's Lane
Bucklebury
Berkshire RG7 6TA
Tel: 01635 914478
email: john.kingham@seineconsult.co.uk

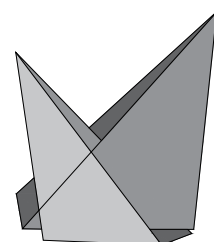

Project Address: Mr Steven Chan
Project Address: 23, Dalley Road
Wokingham RG40 5BQ

Scale : 1: 50 @ A3 Date: 30/01/2025

Drawing Title: **FLOOR PLANS SHOWING RECONFIGURED ROOFLIGHTS IN TOP FLOOR**

Drawing No: **SC/PL/ 02**