

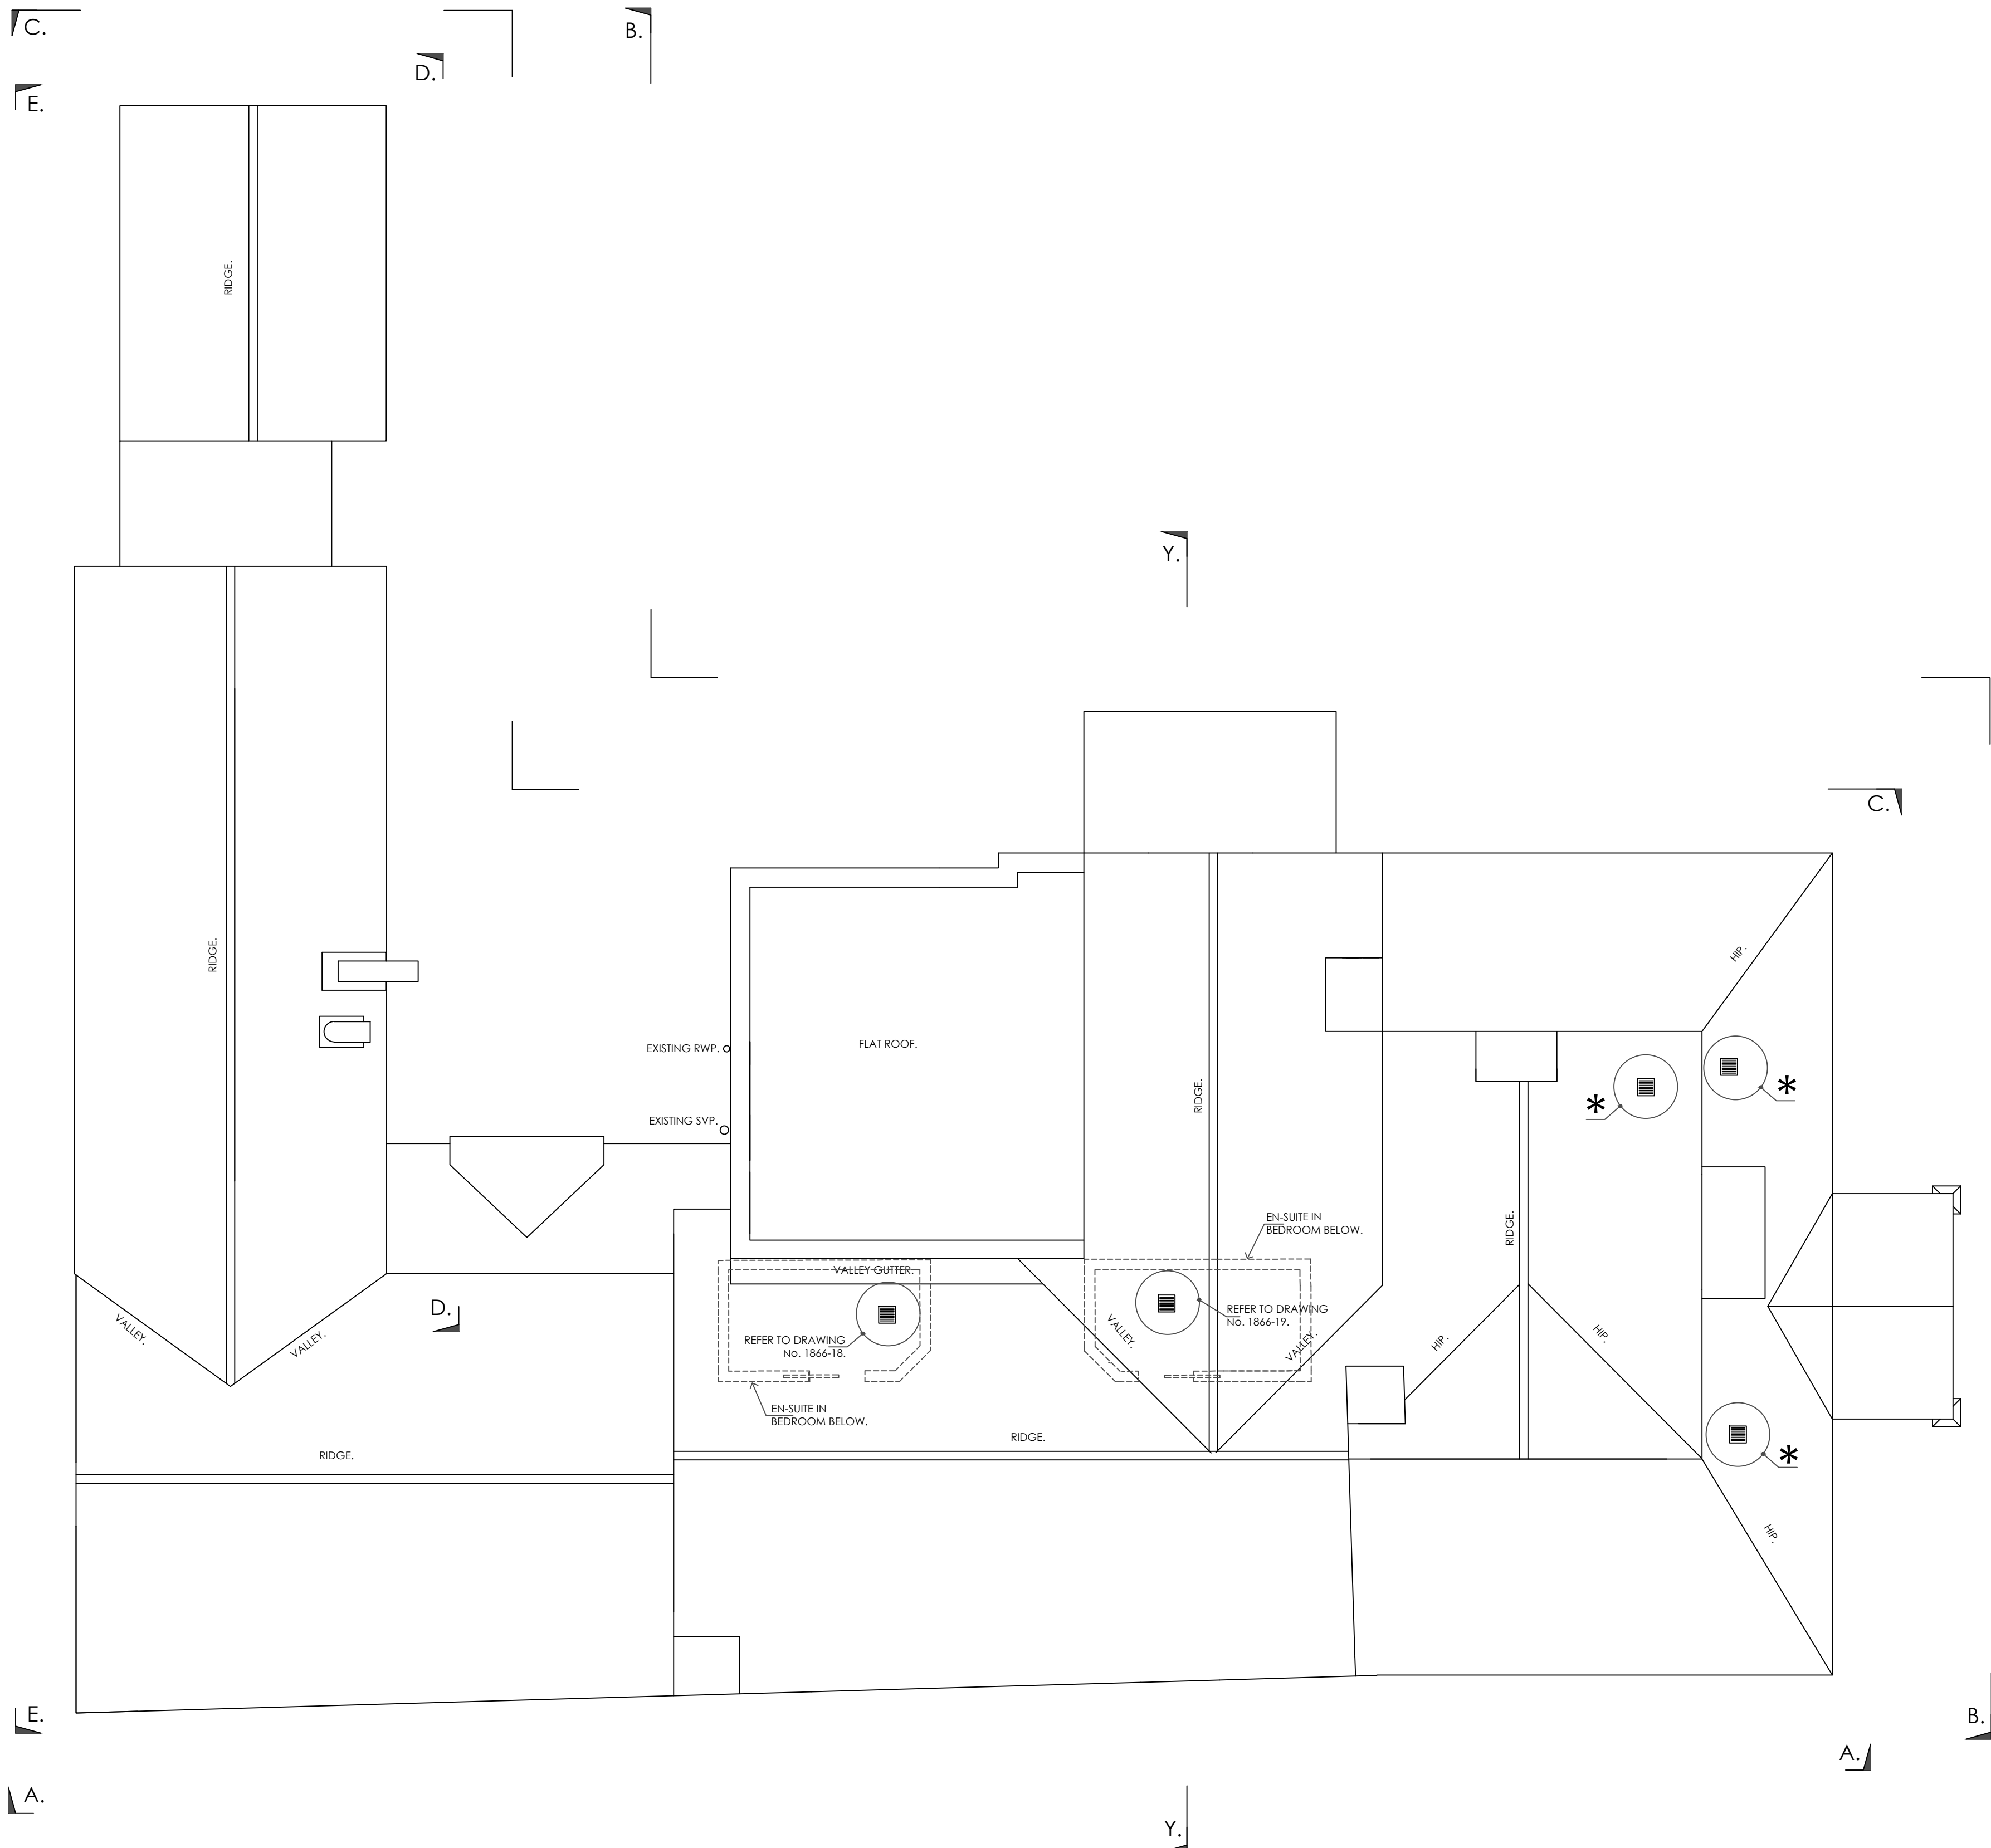
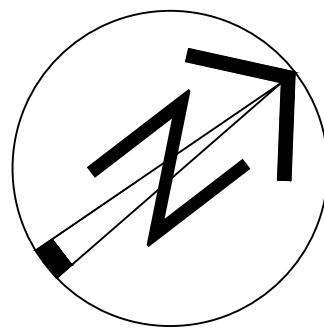


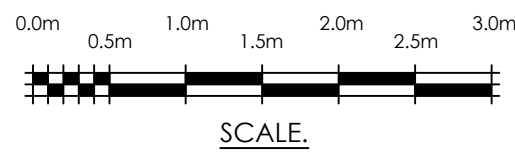

- * METHOD OF INSTALLATION:**
- CAREFULLY REMOVE MINIMUM NUMBER OF EXISTING ROOF TILES TO EXPOSE AREA WHERE NEW VENT IS TO BE INSTALLED.
 - CAREFULLY CUT OUT HOLE IN SARKING FELT AVOIDING ROOF RAFTERS .
 - CAREFULLY REINSTATE EXISTING ROOF TILES AND NEW UB8INK UB39 VEPAC IN-LINE SLATE ROOF VENT SERVICE TERMINAL.
 - WITHIN ROOF VOID CAREFULLY LOCATE POSITION OF NEW EXTRACT FAN AVOIDING EXISTING CEILING JOISTS AND DRILL 10mm PILOT HOLE THROUGH CEILING.
 - INTERNALLY CORE DRILL 110mm HOLE IN EXACT LOCATION OF PILOT HOLE THUS AVOIDING EXISTING CEILING JOISTS.
 - INSERT DUCTING CONNECTING TO VENT TILE AND EXTRACT FAN.
 - FIX NEW VENT AXIA SILENT BATHROOM EXTRACTOR FAN TO EXISTING CEILING.

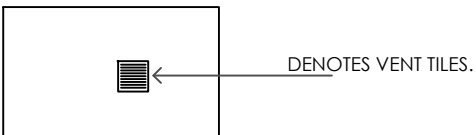

PROPOSED ROOF PLAN INDICATING VENT TILES.

REV	DATE	REVISION
CLIENT		
Horns Hospitality Limited.		
PROJECT		
The Horns Public House, Crazies Hill, Berkshire.		
TITLE		
Proposed Alterations and Refurbishment.		
 Wargrave Design Consultancy The Old Pump House - Wargrave - Berkshire - RG10 8DJ 0118 940 1678 - info@wargravedesign.com www.wargravedesign.com		
DRAWN	G.D.G.	SCALE
DATE	June 2024	1:50 @ A1
DRAWING No.	1886 - 17	REV.
		P1

These plans must not be acted upon until the appropriate planning and building regulation approvals have been granted. Should the works be undertaken prior to the above approvals being in place it is done so entirely at the clients own risk.