



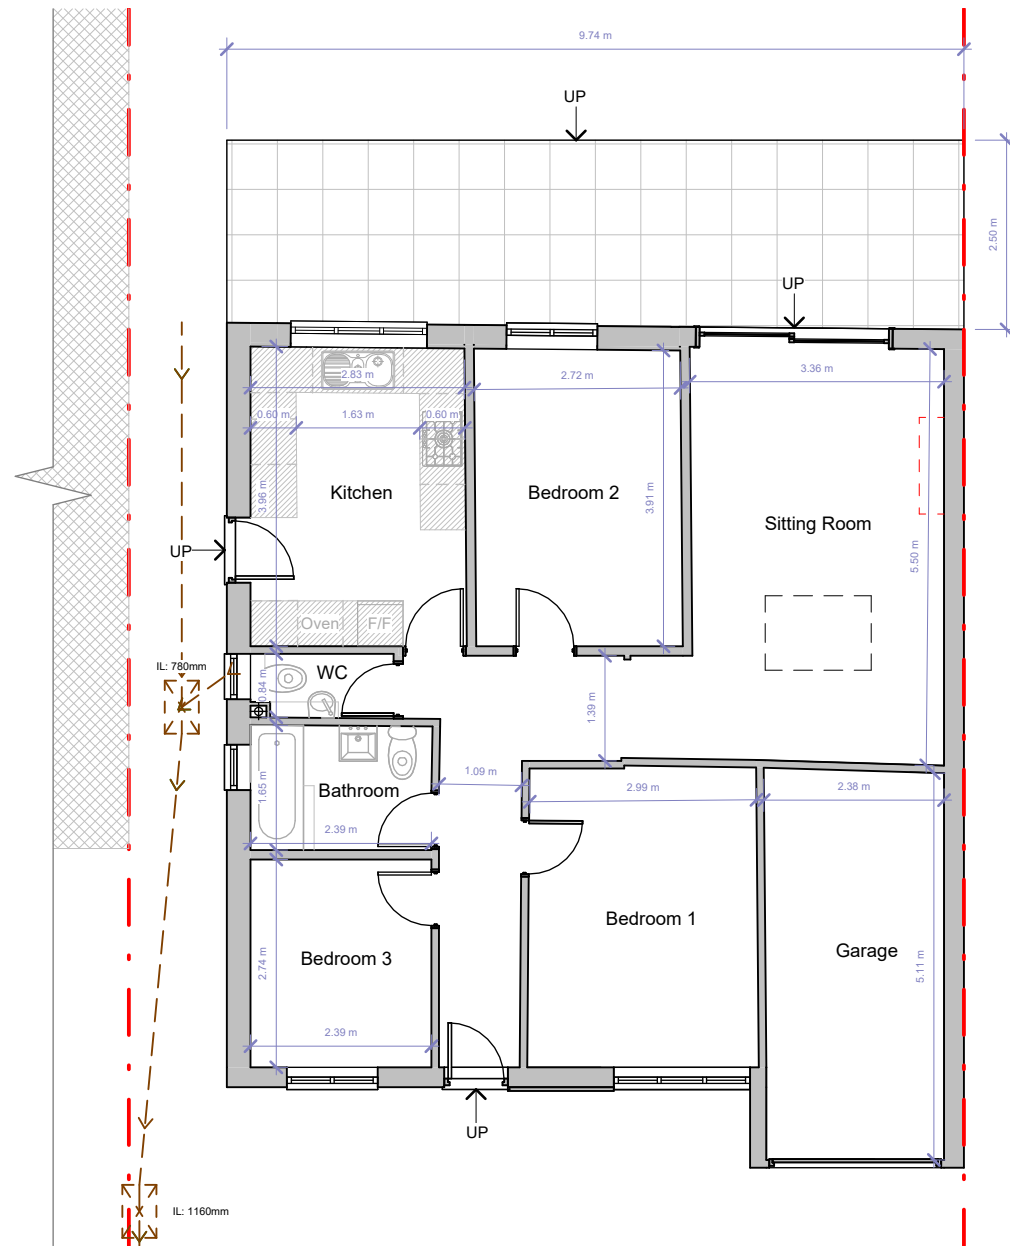

Ground Floor

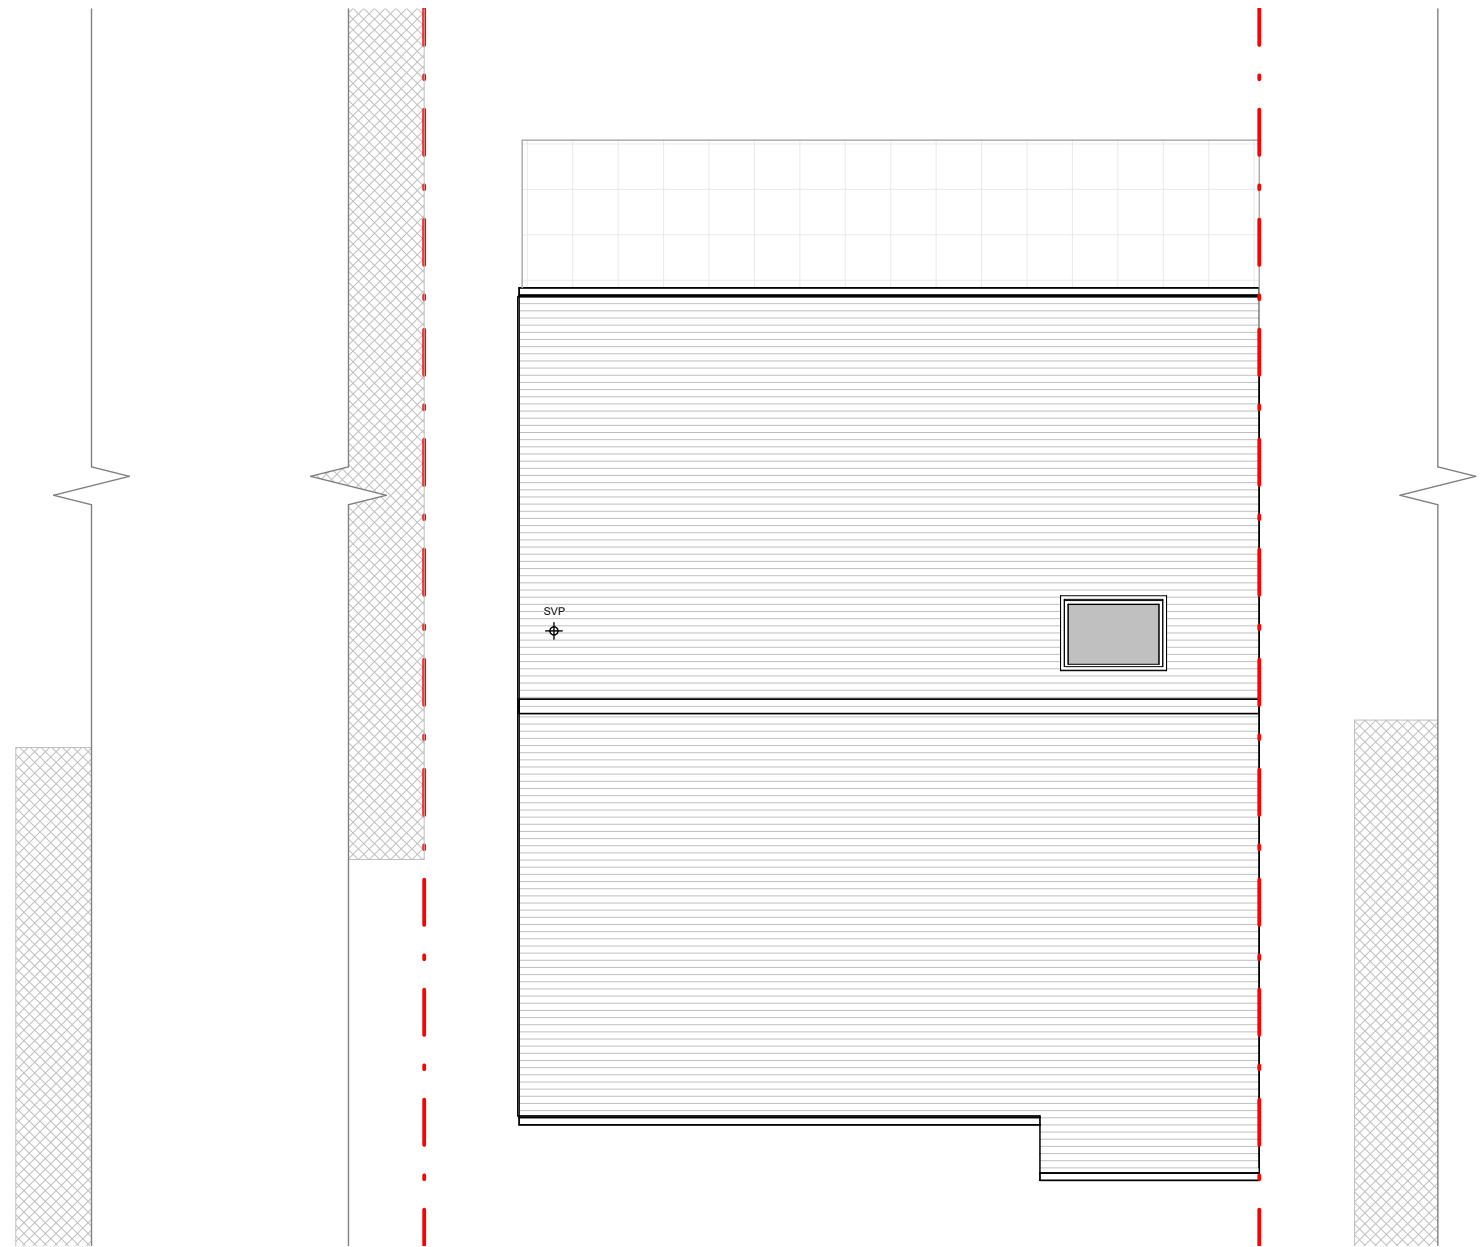

Roof Plan



FLUENT
ARCHITECTURAL DESIGN SERVICES
TEL: 0800 043 8838
E-MAIL: INFO@FLUENT-ADS.CO.UK
WEB: FLUENT-ADS.CO.UK

84 Broadwater Road Twyford

Proposed Floor Plans

Scale @ A3
1 : 100

Date
05.02.26

Drawn by
S.G

 
Drawing number
P.M.500

Project number
2502

Rev
E

Key:

Existing Proposed SVP Boundary line
Existing drainage Proposed drainage Overhead



No.	Description	Date
0	First Draft	05.02.26
A	Client's comments (1)	19.02.26
B	Client's comments (2)	02.03.26
C	Client's comments (3)	04.03.26
D	Drawing amended	31.03.26
E	Drawing amended	02.04.26