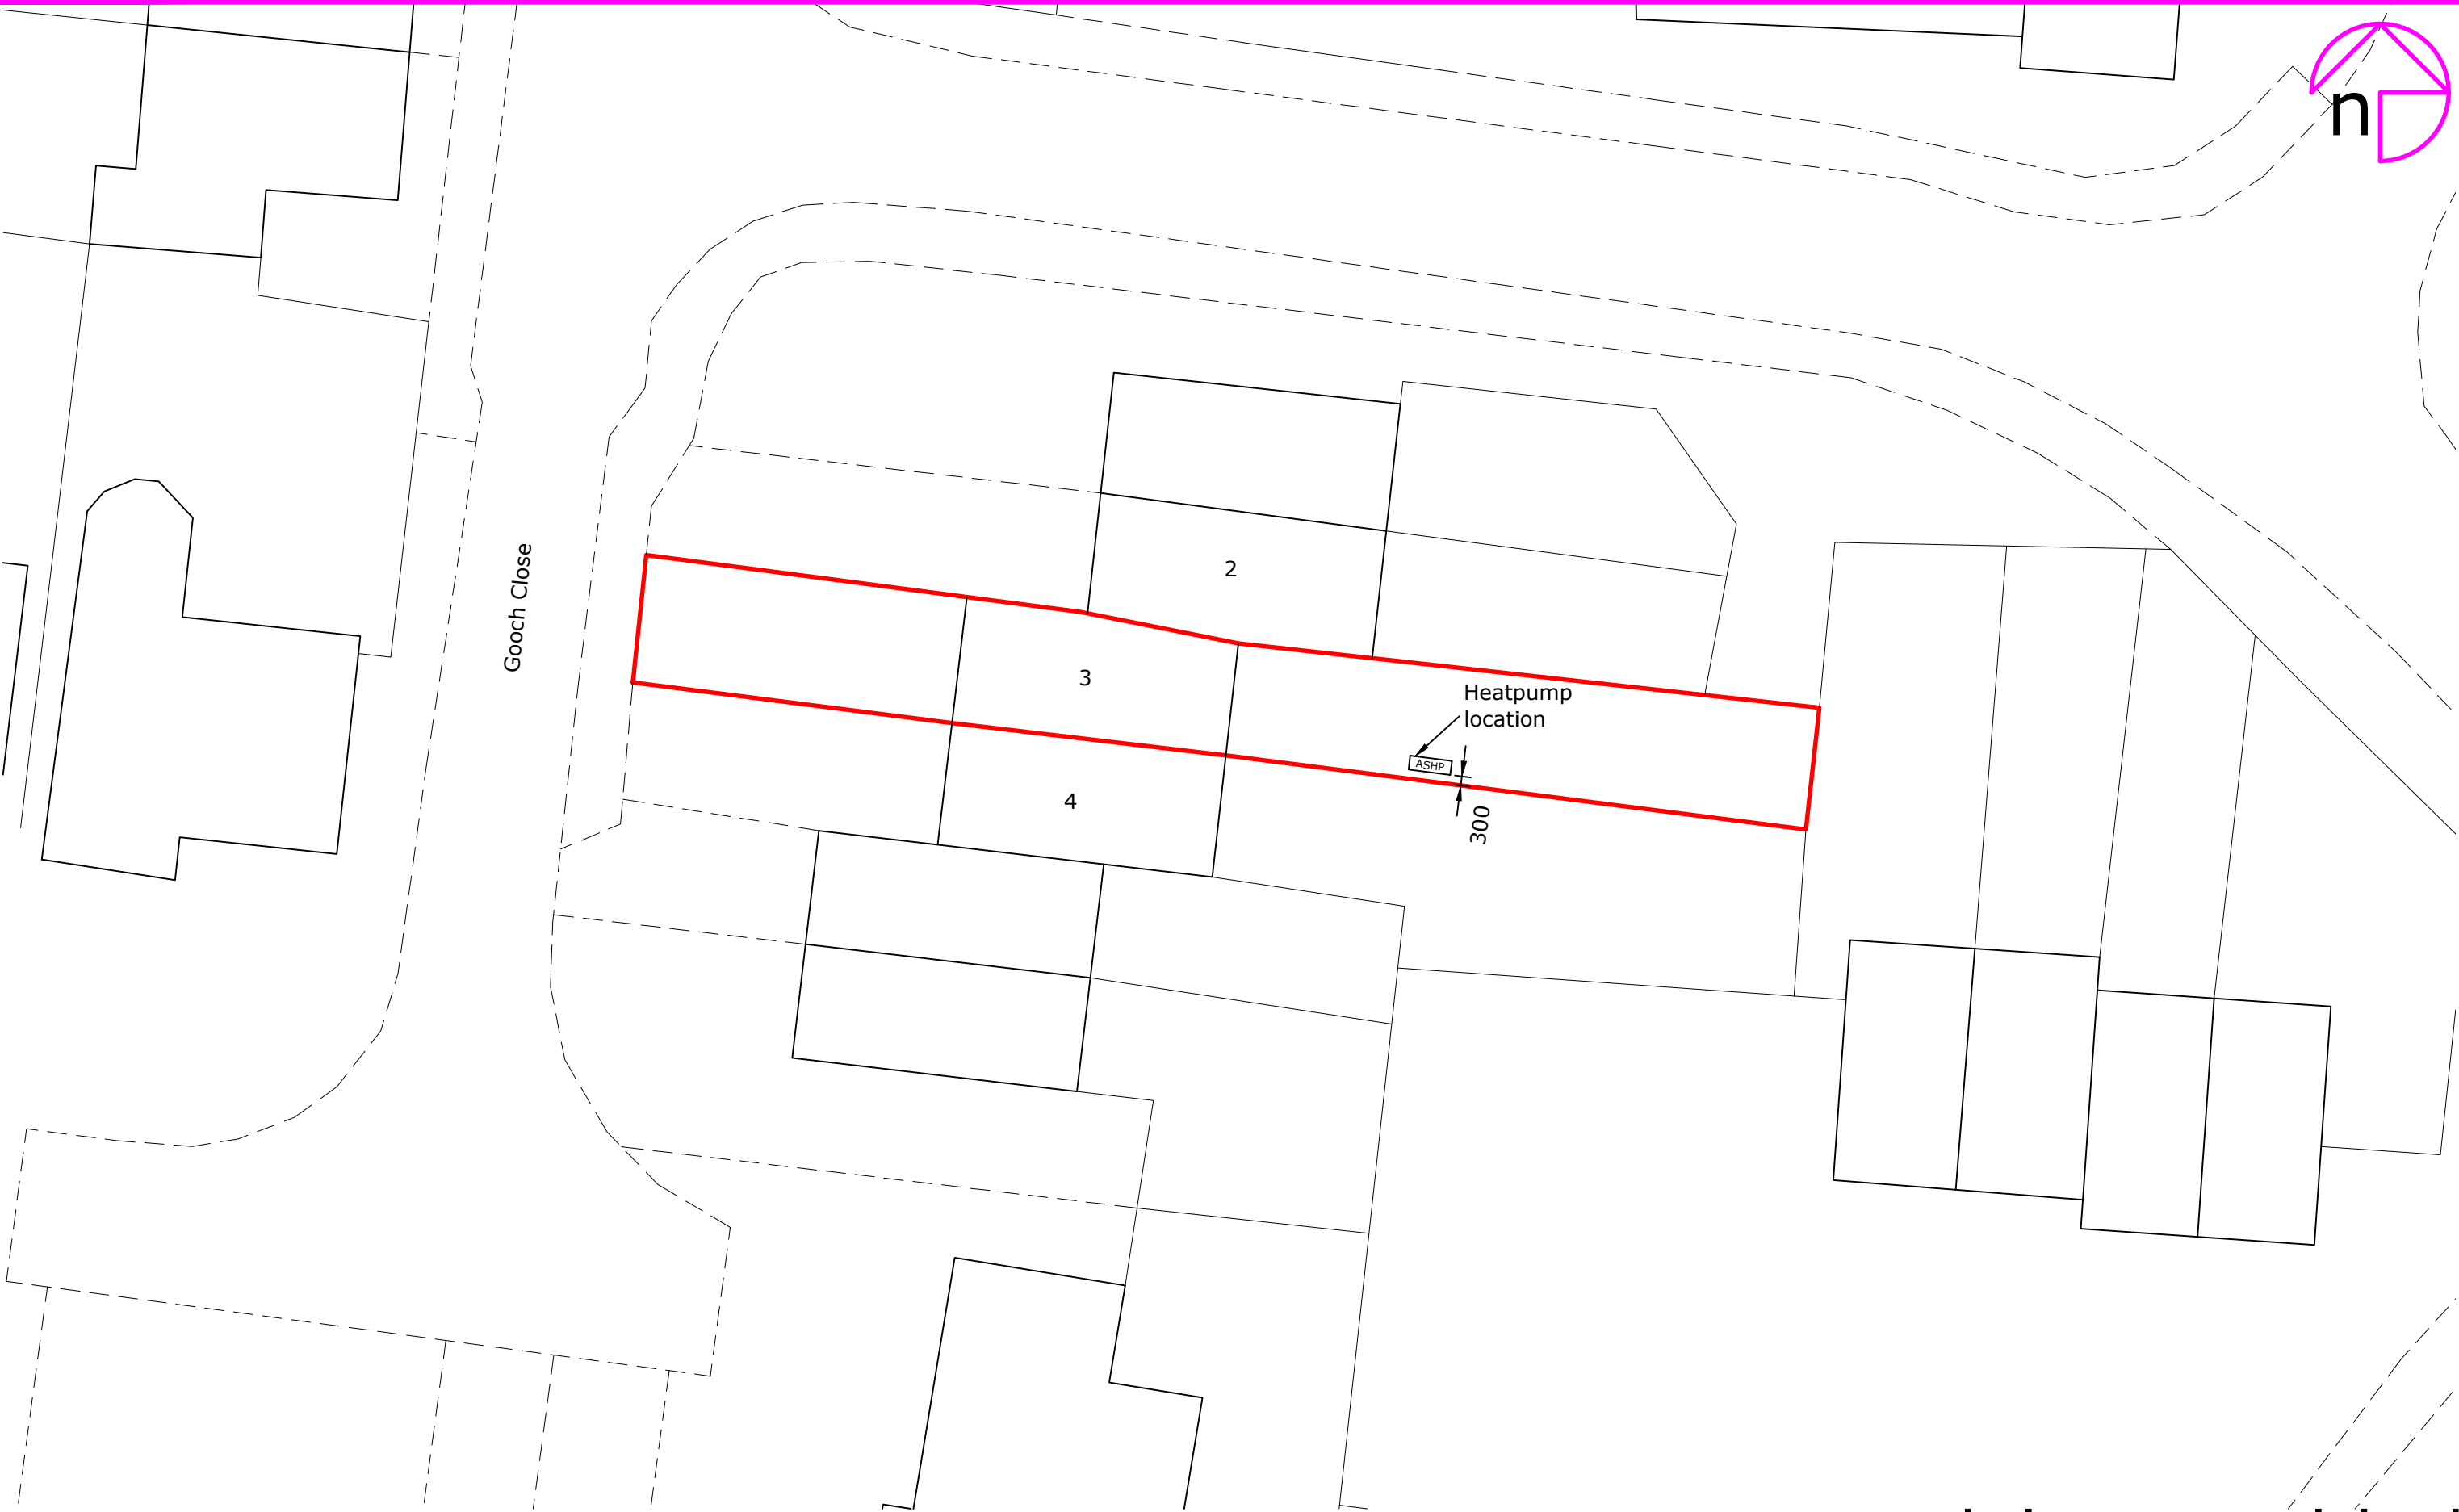
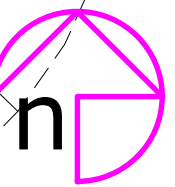


Client/Project: Leila Naboulsi, 3 Gooch Close, Twyford, Reading, RG10 0XS	Project status: PLANNING
	Drawing title:Site plan as proposed showing location of air source heat pump

A	Heatpump location revised	AK	25.10.24
Rev:	Description:	By:	Date:

Scale: 1:200	Paper Size: A3	Drawn: A.Kenyon	Checked: O. Barnes
Project ID: J-217A604C	Drawing No: 02	Revision: A	Date: Oct 2024