


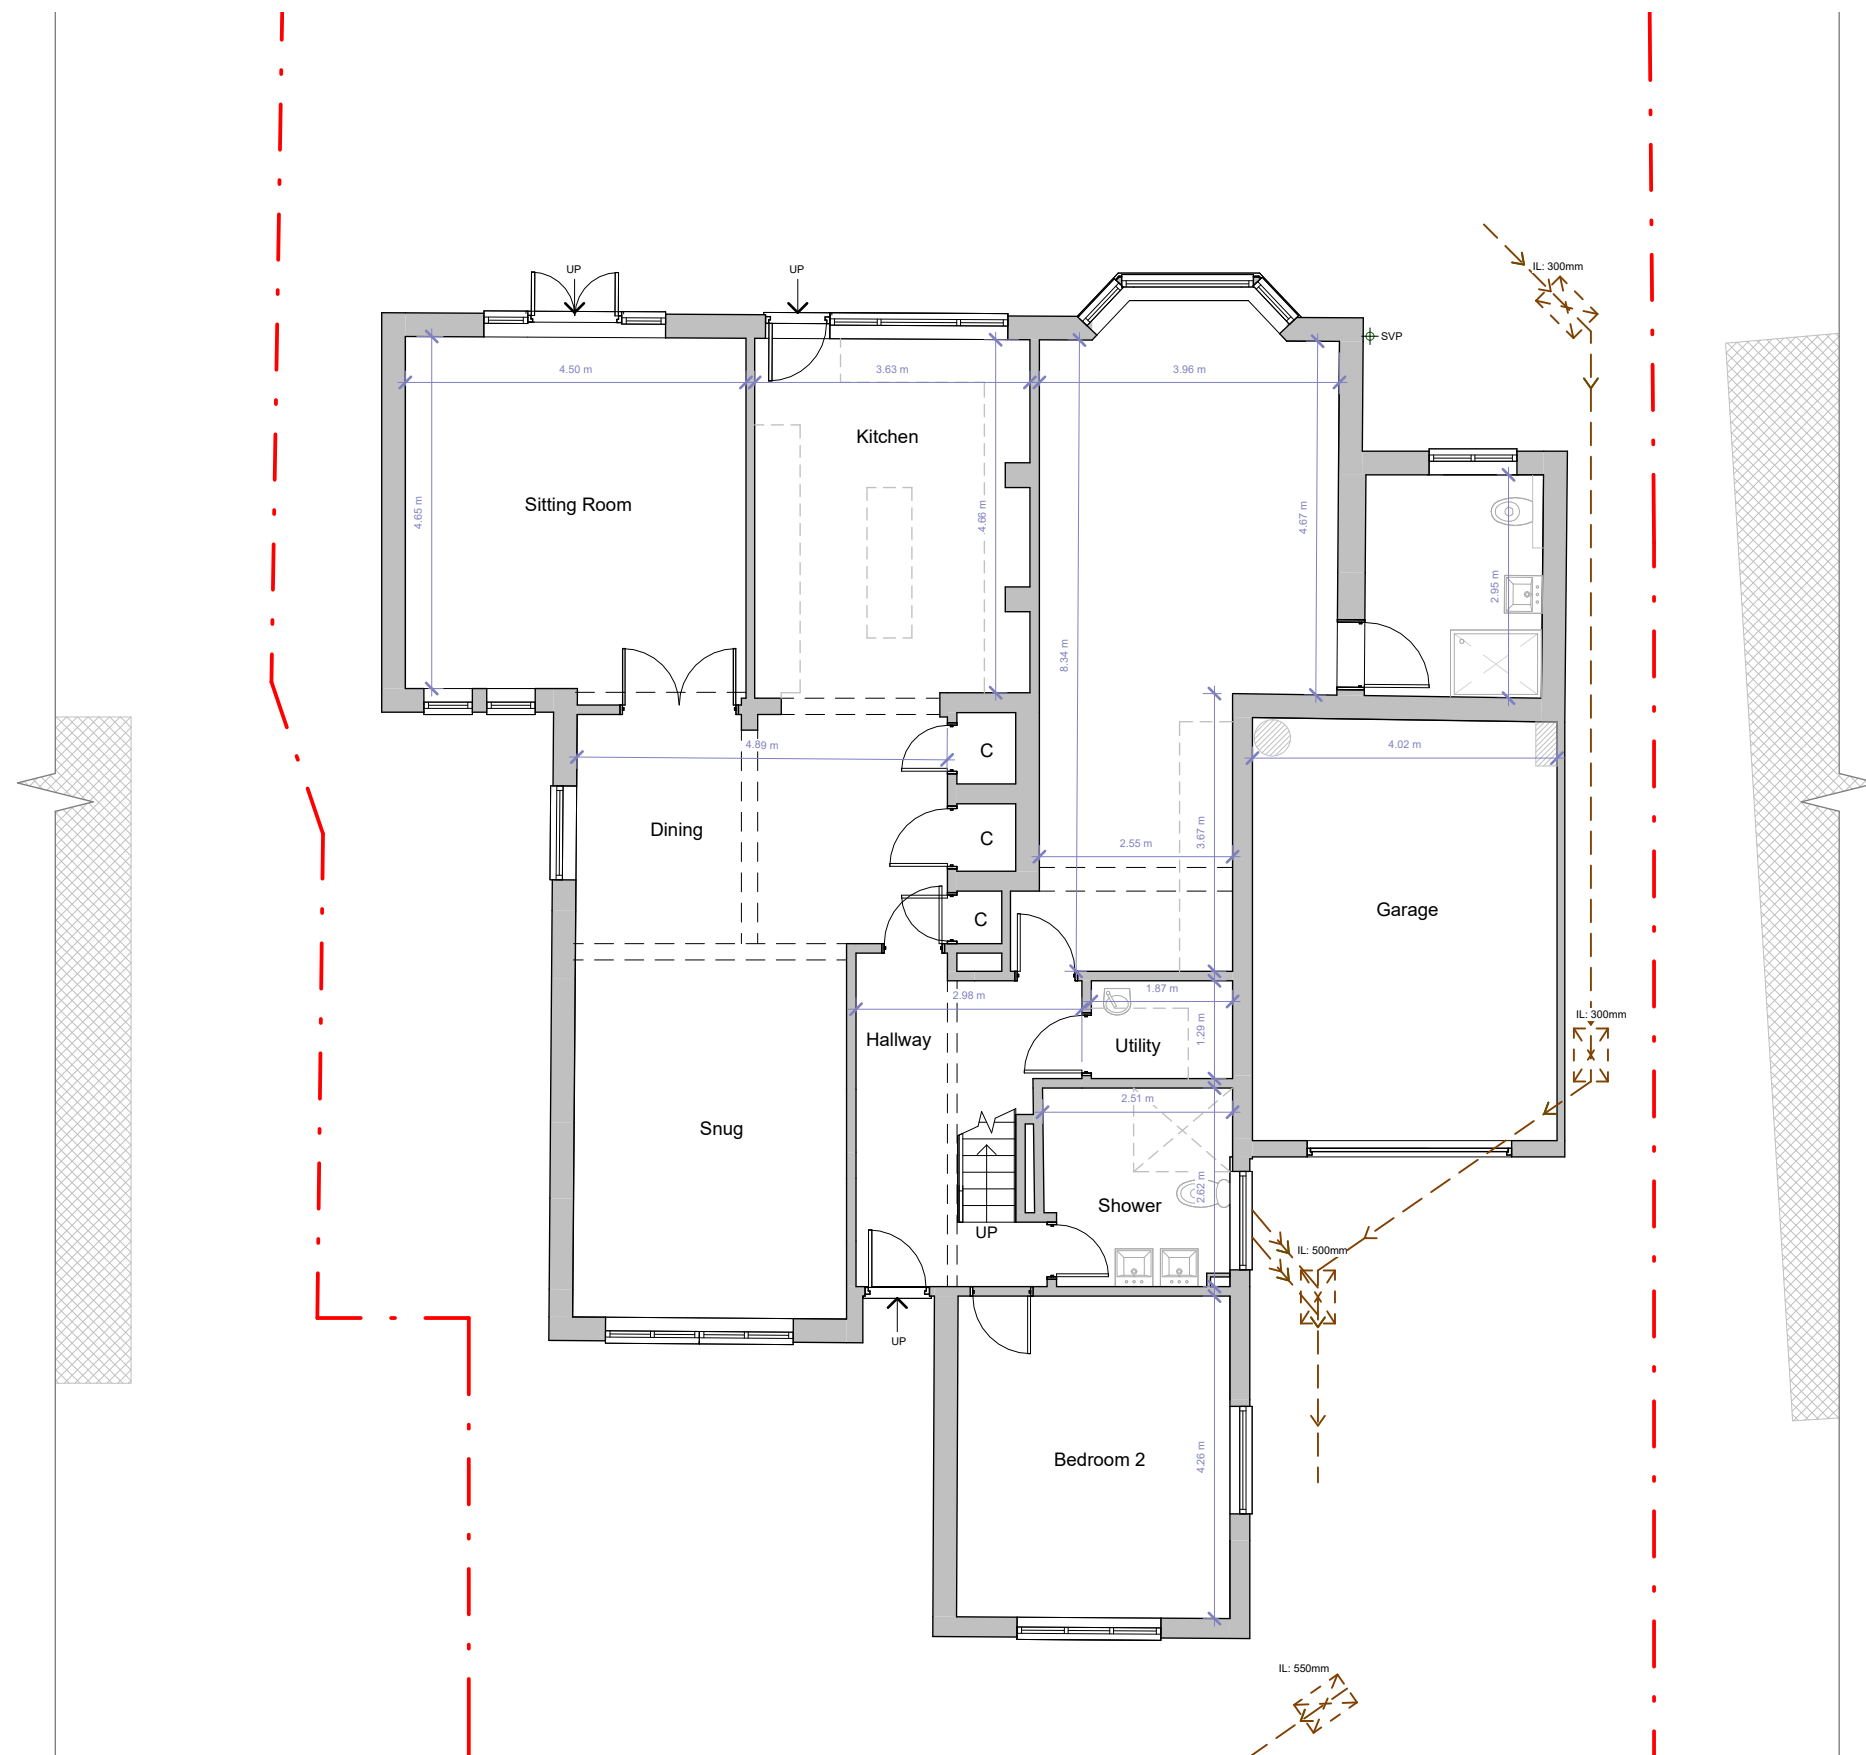

Ground Floor



FLUENT
ARCHITECTURAL DESIGN SERVICES
TEL: 0800 043 8838
E-MAIL: INFO@FLUENT-ADS.CO.UK
WEB: FLUENT-ADS.CO.UK

204 London Road Wokingham

Existing Ground Floor Plan

Scale @ A3
1 : 100

Date
26.08.25

Drawn by
S.G

 
Drawing number
P.M.200

Project number
2407

Rev
A

Key:

Existing Proposed SVP Boundary line
Existing drainage Proposed drainage Overhead



No.	Description	Date
0	First Draft	26.08.25
A	Revision 13	16.09.26