


NOTES:

- THIS DRAWING IS TO BE READ IN CONJUNCTION WITH THE RELEVANT SPECIFICATION, INC. RISK ASSESSMENTS AND ALL OTHER RELATED DRAWINGS ISSUED BY THE ENGINEER.
- DO NOT SCALE FROM THIS DRAWING. WORK FROM FIGURED DIMENSIONS ONLY.
- ALL DIMENSIONS SHOWN ON THIS DRAWING ARE IN METRES UNLESS OTHERWISE STATED.
- ALL DIMENSIONS, LEVELS AND SURVEY GRID CO-ORDINATES ARE TO BE CHECKED ON SITE AND THE ENGINEER NOTIFIED IMMEDIATELY OF ANY DISCREPANCIES PRIOR TO THE COMMENCEMENT OF THE WORKS.
- NO DEVIATION FROM THE DETAILS SHOWN ON THIS DRAWING IS PERMITTED WITHOUT PRIOR PERMISSION FROM THE ENGINEER.
- ANY WORKS OUTSIDE RED SITE BOUNDARY ARE FOR INFORMATION PURPOSES ONLY. UNLESS SPECIFICALLY NOTED, ALL WORKS OUTSIDE THE SITE BOUNDARY WILL BE UNDERTAKEN BY OTHERS UNDER A SEPARATE CONTRACT.

DRAINAGE KEY

- SITE BOUNDARY
- EXISTING DRAINAGE DITCH
- PROPOSED FOUL SEWER AND MANHOLE
- PROPOSED FOUL LATERAL AND PPIC
- PROPOSED SEWAGE TREATMENT PLANT
- PROPOSED SURFACE WATER SEWER AND MANHOLE
- PROPOSED SURFACE WATER LATERAL AND PPIC
- PROPOSED ATTENUATION CRATES
- PROPOSED COMBINED SEWER AND MANHOLE
- PROPOSED COMBINED RISING MAIN
- PROPOSED HEADWALL
- PROPOSED OVERLAND FLOOD ROUTE

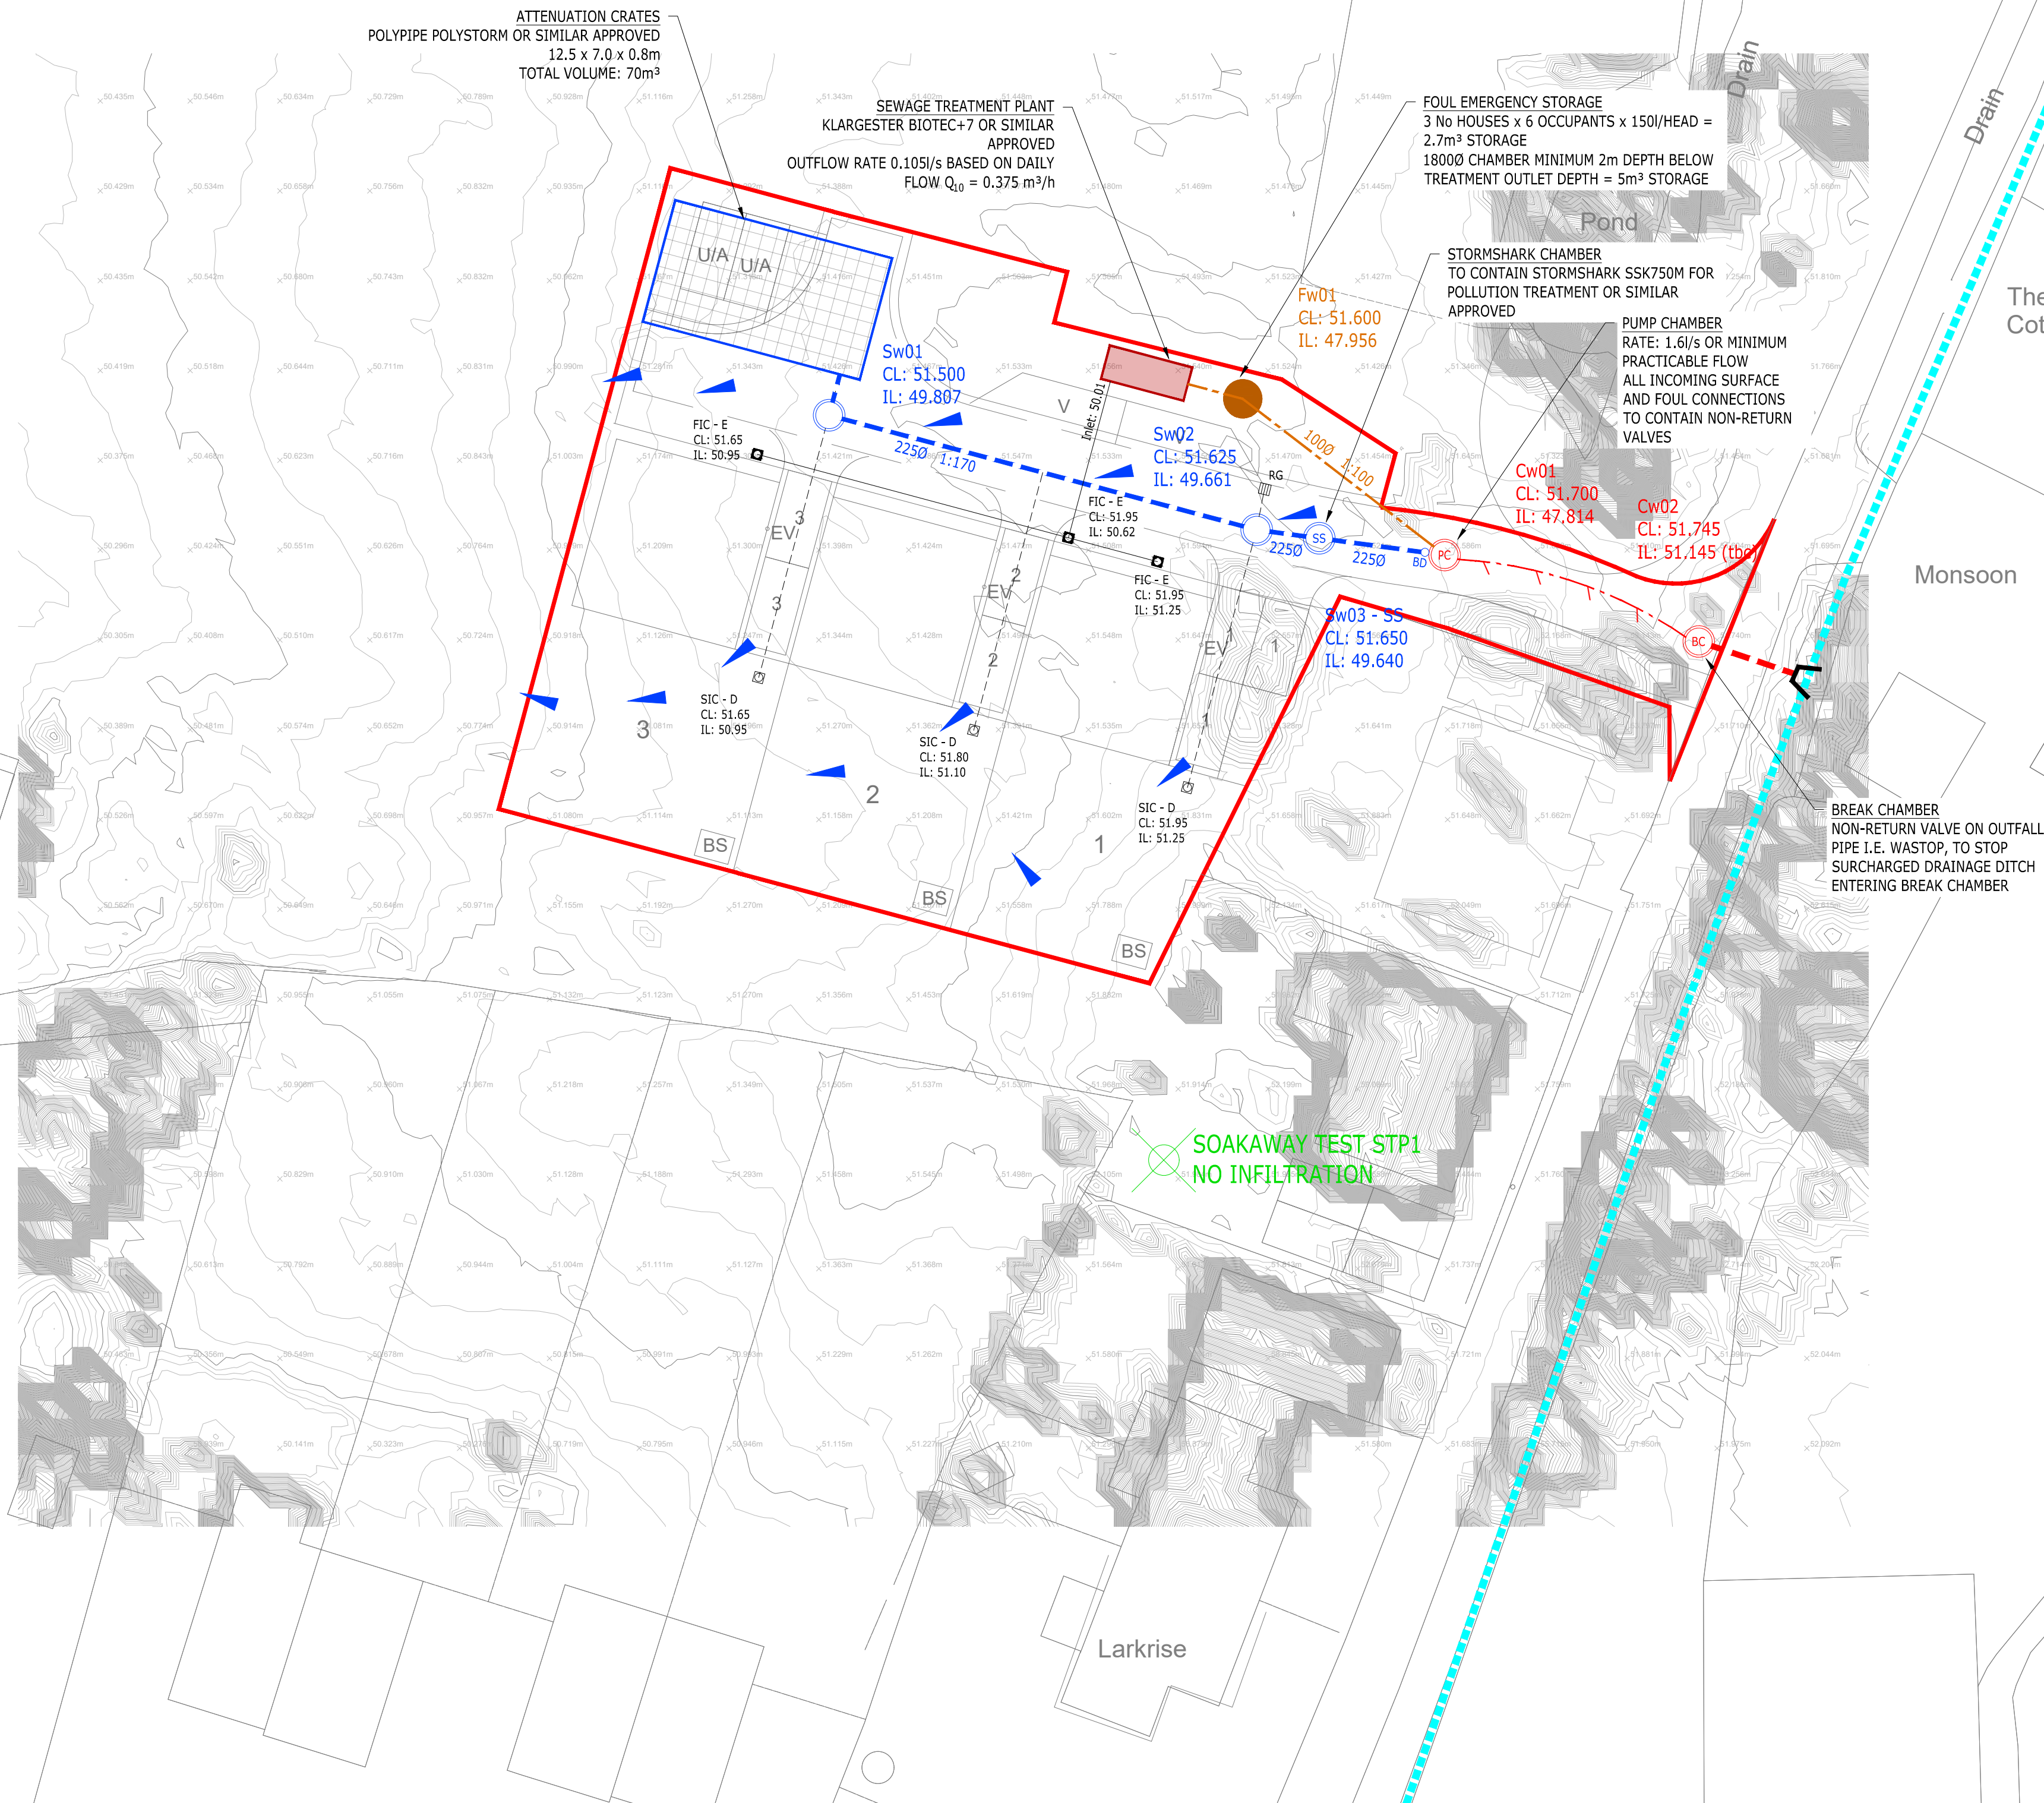

P5	REVISED SITE LAYOUT, ADDED OVERLAND FLOOD ROUTES AND CONTOURS	AMC	AMC	AD	27-03-26
P4	REVISED SITE LAYOUT	AMC	AMC	AD	22-10-25
P3	REVISED SITE LAYOUT	AMC	AMC	AD	06-10-25
P2	UPDATED CLIENT NAME	AMC	PTW	AD	15-09-25
P1	FIRST ISSUE	AMC	PTW	AD	12-09-25
Rev	Description	Drn	Chk	App	Date

Purpose:	PRELIMINARY	Status:	NOT YET APPROVED
----------	-------------	---------	------------------

ARDENT CONSULTING ENGINEERS
AN EMPLOYEE OWNED COMPANY

Third Floor
The Hallmark Building
52-56 Leadenhall Street
London
EC3M 5JE

Tel: 020 7680 4088
Web: www.ardent-ce.co.uk
E-mail: enquiries@ardent-ce.co.uk

Client

SSIP

worksafe consultant

ELIZABETH ROSE HOMES LIMITED

Project Title:
MILL LANE, SINDLESHAM

Drawing Title:
DRAINAGE LAYOUT

Drawn by AMC	Checked by PTW	Approved by AD	Revision P5
A1 Scale 1:250@A1	Date 12-09-25		
Drawing Number 2506120-ACE-XX-XX-DR-C-0601			