


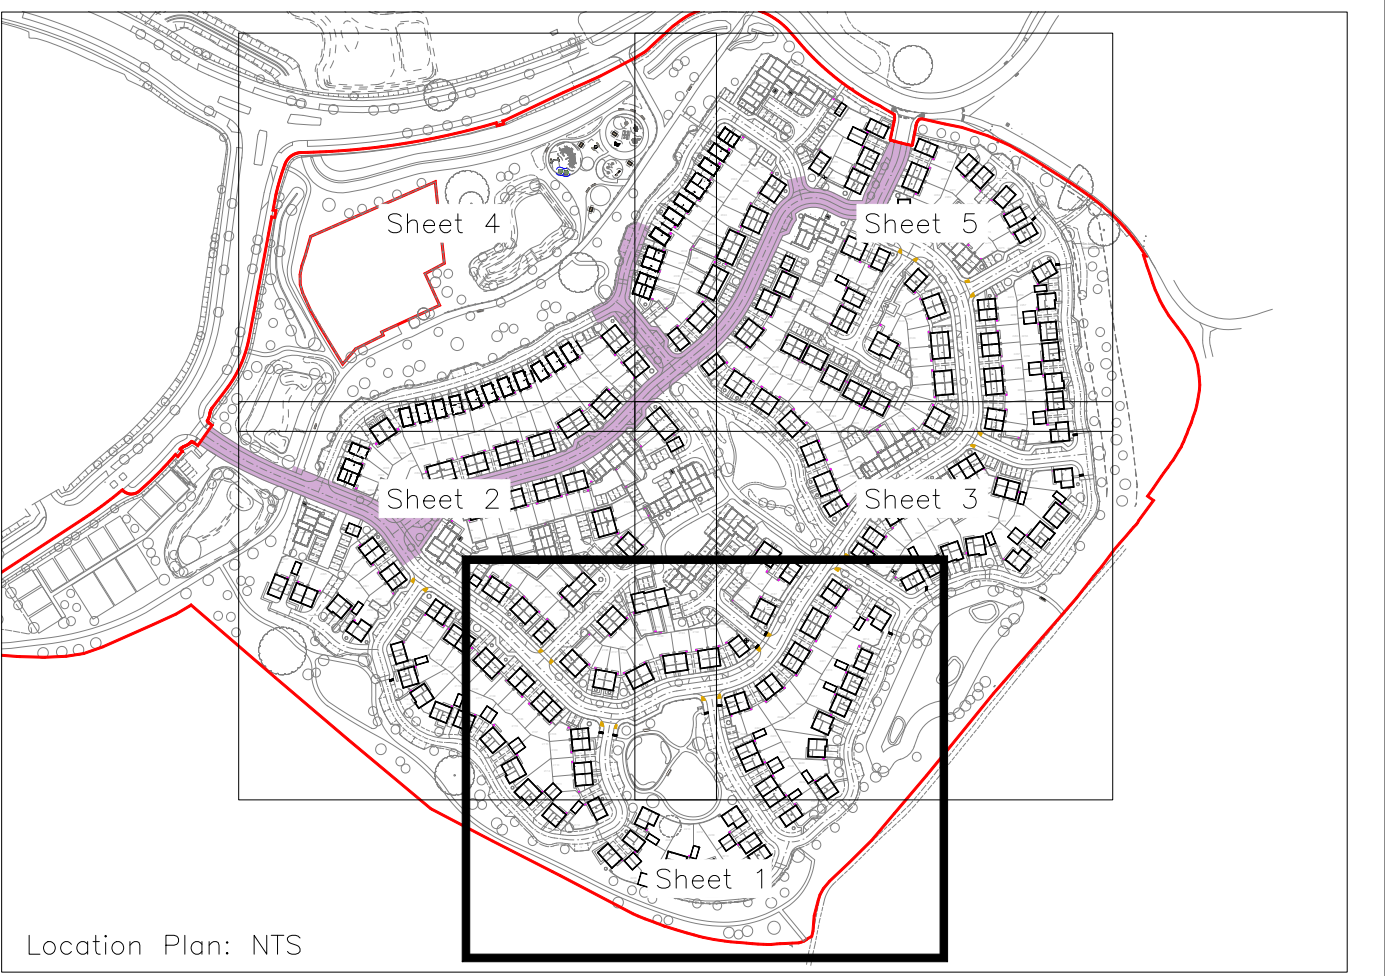

- Notes:
1. Do not scale from this drawing.
 2. All dimensions in metres.
 3. All levels relate to Ordnance datum.
 4. This drawing shall be read in conjunction with all other contract documents.
 5. Any discrepancies with the drawings shall be reported to the Engineer.
 7. For a full list of scheme specific notes, please refer to drawing number 000.

LIGHTING KEY

Proposed street lighting column
Columns: 6.0m height, c/w integral bracket, 3.0' max incl:
0.3m projection
Lanterns: Philips Luma Gen2 Micro BGP702 DM10. Lamp
LED-HB 5.2S 740

- 5.0 Lux Contour
2.5 Lux Contour
1.0 Lux Contour

SECTION 38 - NOT APPROVED
SECTION 104 - APPROVED
SECTION 106 - NOT APPROVED
AGREEMENTS PENDING. ALL CONSTRUCTION WORKS
AT DEVELOPERS RISK.

C3	30.07.26	Date asterisks removed	RT	EP
C2	10.06.26	Lux contours added to key	RT	EP
C1	29.01.26	Updated to construction issue	LB	EP
P2	18.09.25	Substructures added & minor drawing amendments.	SR	EP
REV. No.	DATE	DESCRIPTION	DRAWN	CHECKED
Client				
Project		MJA CONSULTING CIVIL & STRUCTURAL ENGINEERS Ipswich Court, 24 The Quadrant, Abingdon Science Park, Abingdon Oxon, OX14 3YB Tel: 01235 555173 Email: mail@mjaconsulting.co.uk		
Title		Scale: 1:250 @ A0	Status: CONSTRUCTION	
Private Street Lighting Layout Sheet 1		Drawn: SR Project Engineer: EP Project No: 7371	Date: 15/07/2025	Rev: C3