
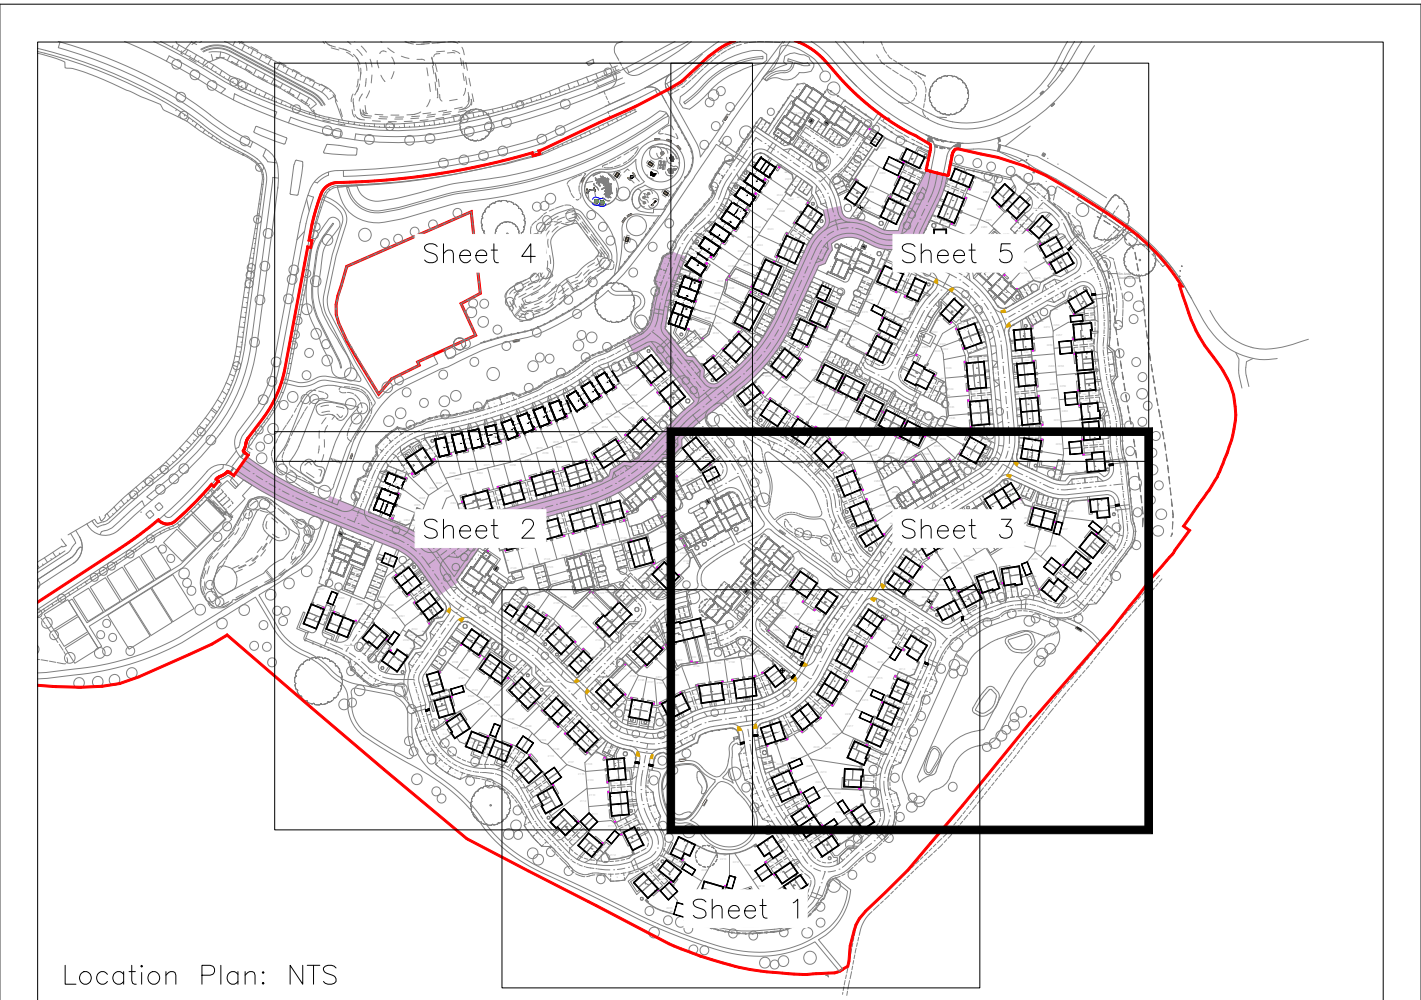


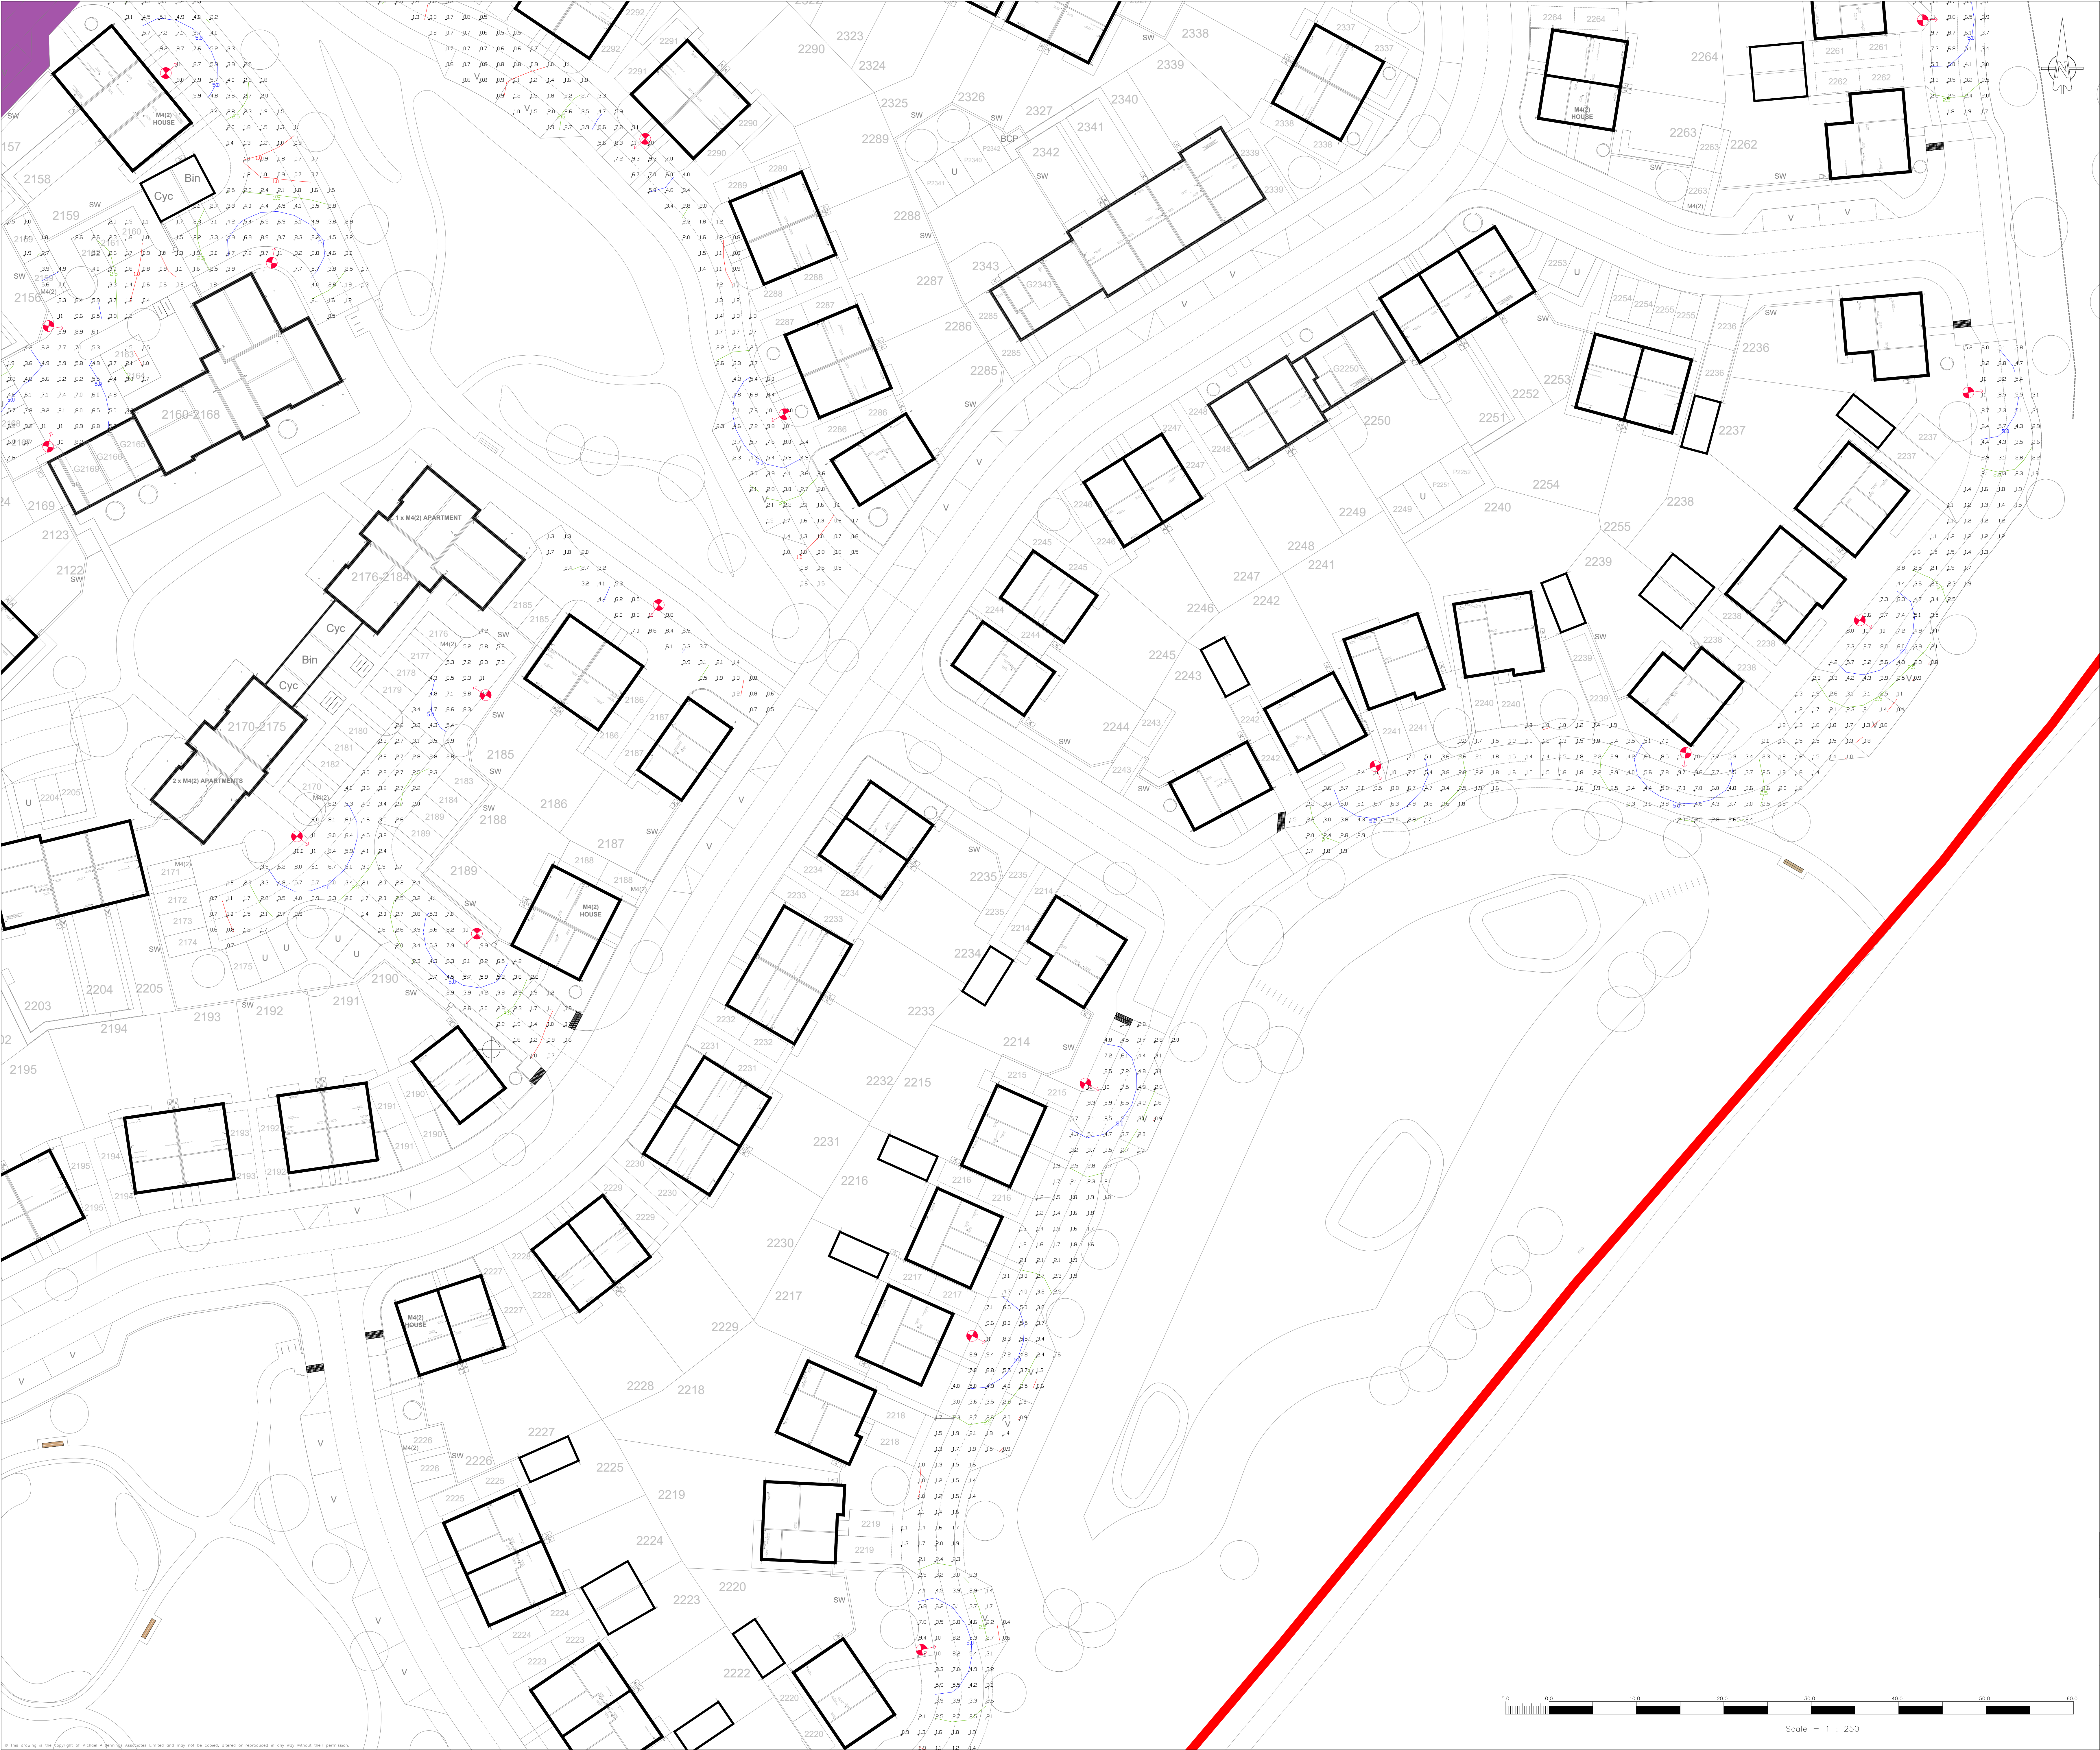

- Notes:
1. Do not scale from this drawing.
 2. All dimensions in metres.
 3. All levels relate to ordnance datum.
 4. This drawing shall be read in conjunction with all other contract documents.
 6. Any discrepancies with the drawings shall be reported to the Engineer.
 7. For a full list of scheme specific notes, please refer to drawing number 000.

LIGHTING KEY

Proposed street lighting column
Columns: 6.0m height, c/w integral bracket, 3.0' max incl:
0.3m projection
Lanterns: Philips Luma Gen2 Micro BGP702 DM10. Lamp
LED-HB 5.25 740

5.0 Lux Contour
2.5 Lux Contour
1.0 Lux Contour

SECTION 38 - NOT APPROVED
SECTION 104 - APPROVED
SECTION 106 - NOT APPROVED
AGREEMENTS PENDING. ALL CONSTRUCTION WORKS
AT DEVELOPERS RISK.

C3	30.07.26	Gate asterisks removed	RT	EP
C2	10.06.26	Lux contours added to key	RT	EP
C1	29.01.26	Updated to construction issue	LB	EP
P3	20.10.25	Updated to new layout	SR	EP
P2	18.09.25	Substructures added & minor drawing amendments.	SR	EP
REV. No.	DATE	DESCRIPTION	DRAWN	CHECKED
Client				
Project		South Wokingham Phase R11		
Title		Private Street Lighting Layout Sheet 3		
Scale:		1:250 @ A0	Status:	CONSTRUCTION
Drawn:		SR	Project Engineer:	MJA Project No:
Drawing Number:		7371-MJA-R11-XX-DR-C-702	Date:	15/07/2025
			Rev:	C3