


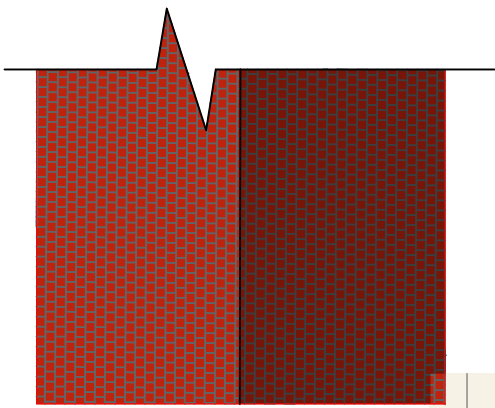


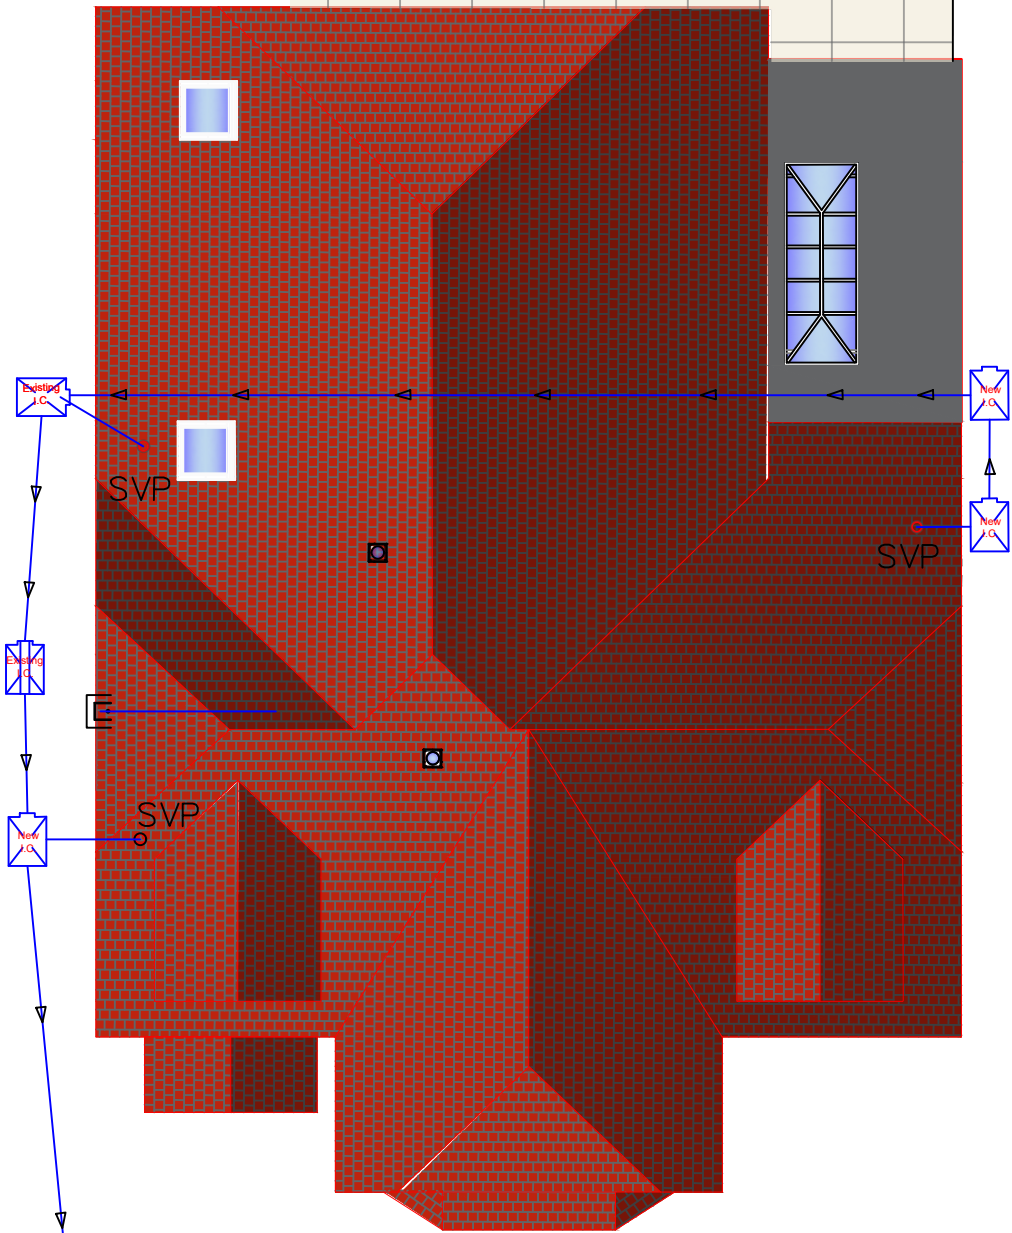

rwp to connect to new
soakaway located min
5m from building

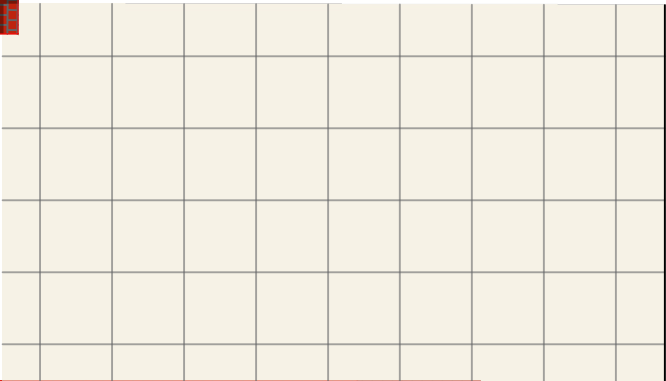

rwp to connect to new
soakaway located min
5m from building

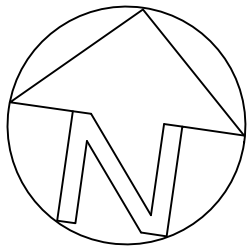

Direction of existing
underground foul pipe to
the mains drain

0m 2m 4m 6m 8m 10m

SCALE 1:100 @ A3

DRG. NO. PP012	REV A	SCALE 1:100@A3	DATE MARCH 2025	DRAWN BY TRISH BARSON
DRG. TITLE ROOF AND DRAINAGE PLAN		PROJECT ADDRESS 59 EVENDONS LANE, WOKINGHAM		



Trish Barson
Designs

Tel: 07947 919717
Email: trish@trishbarsondesigns.co.uk
Web: www.trishbarsondesigns.co.uk