

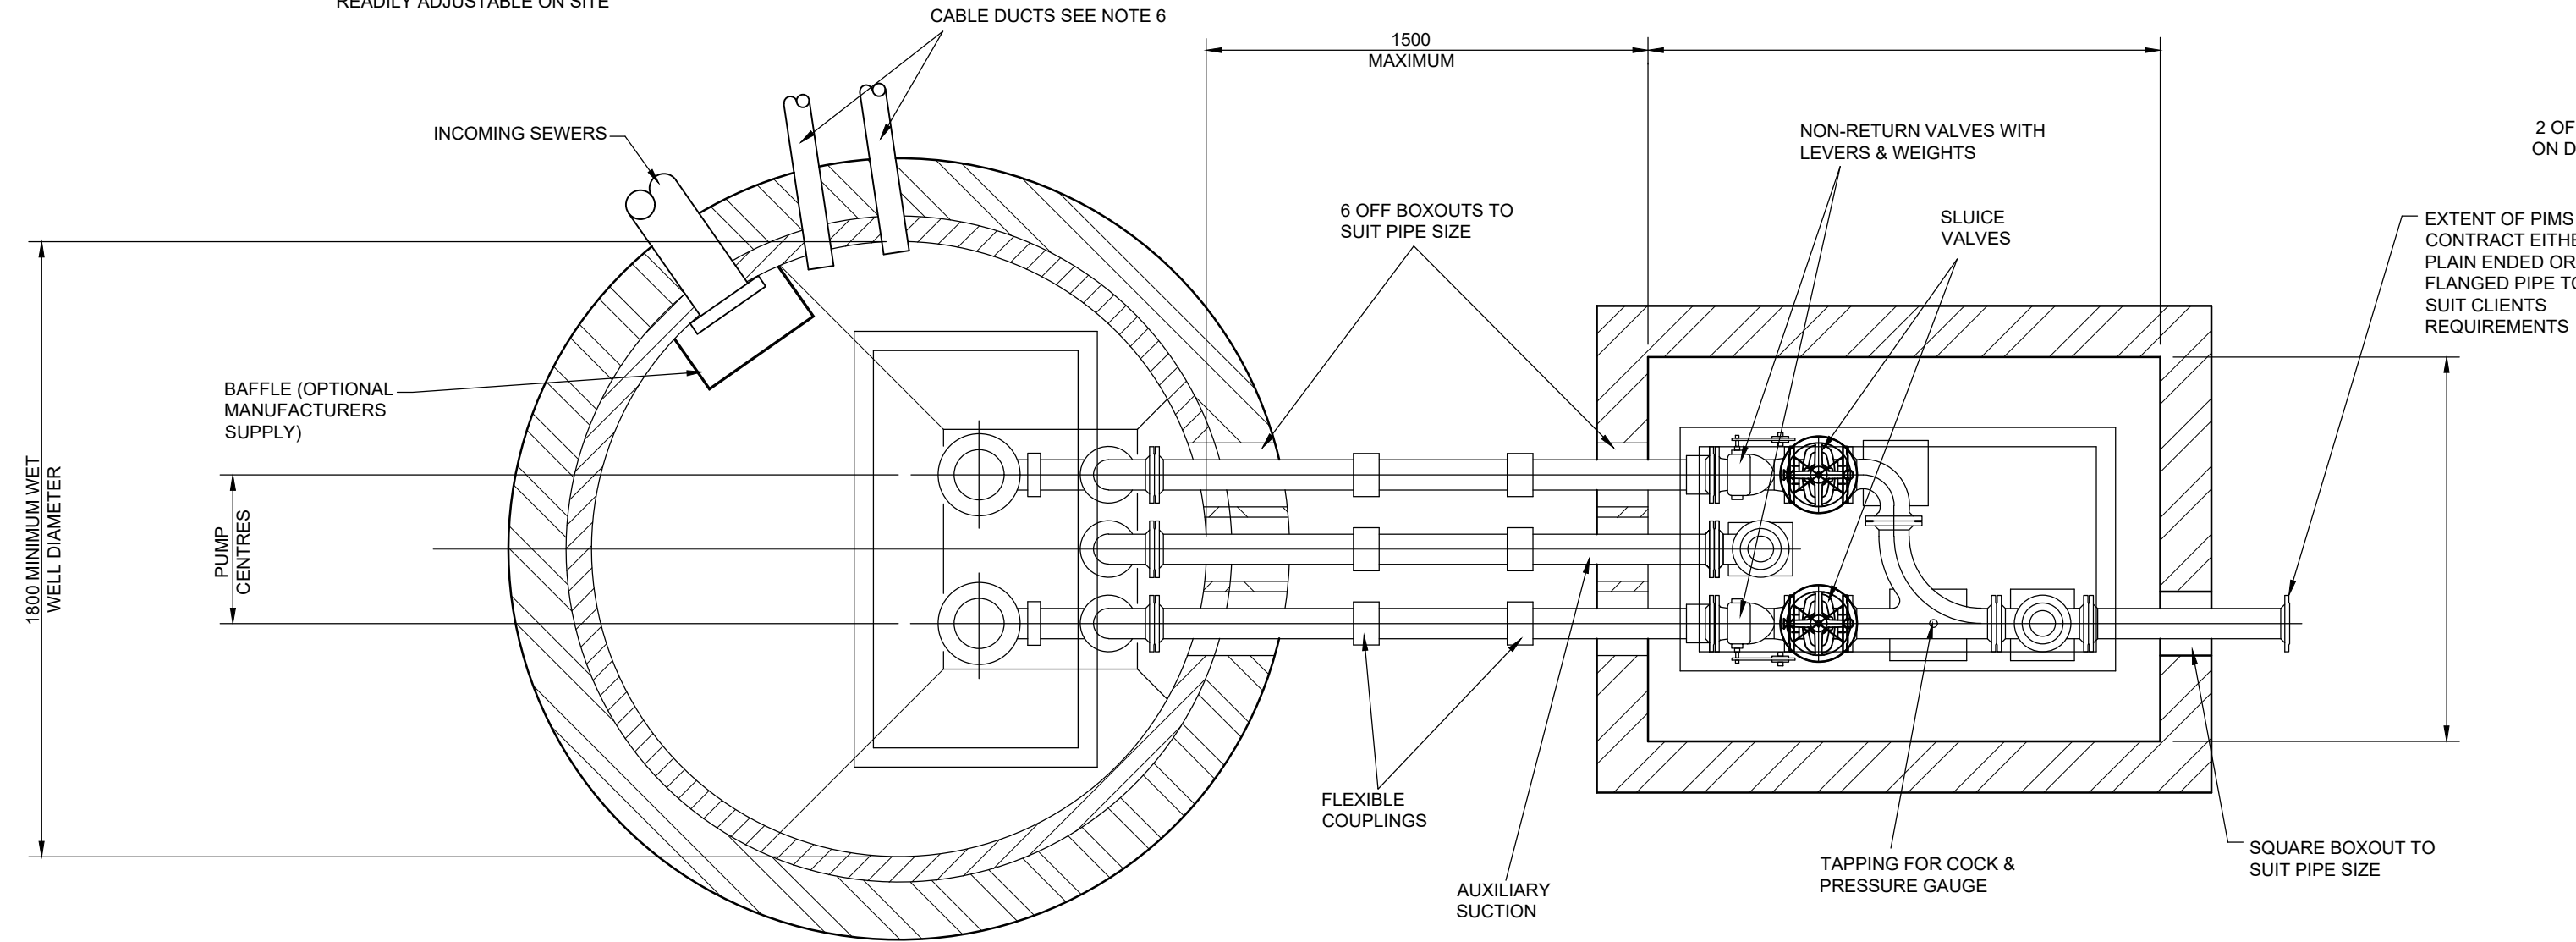


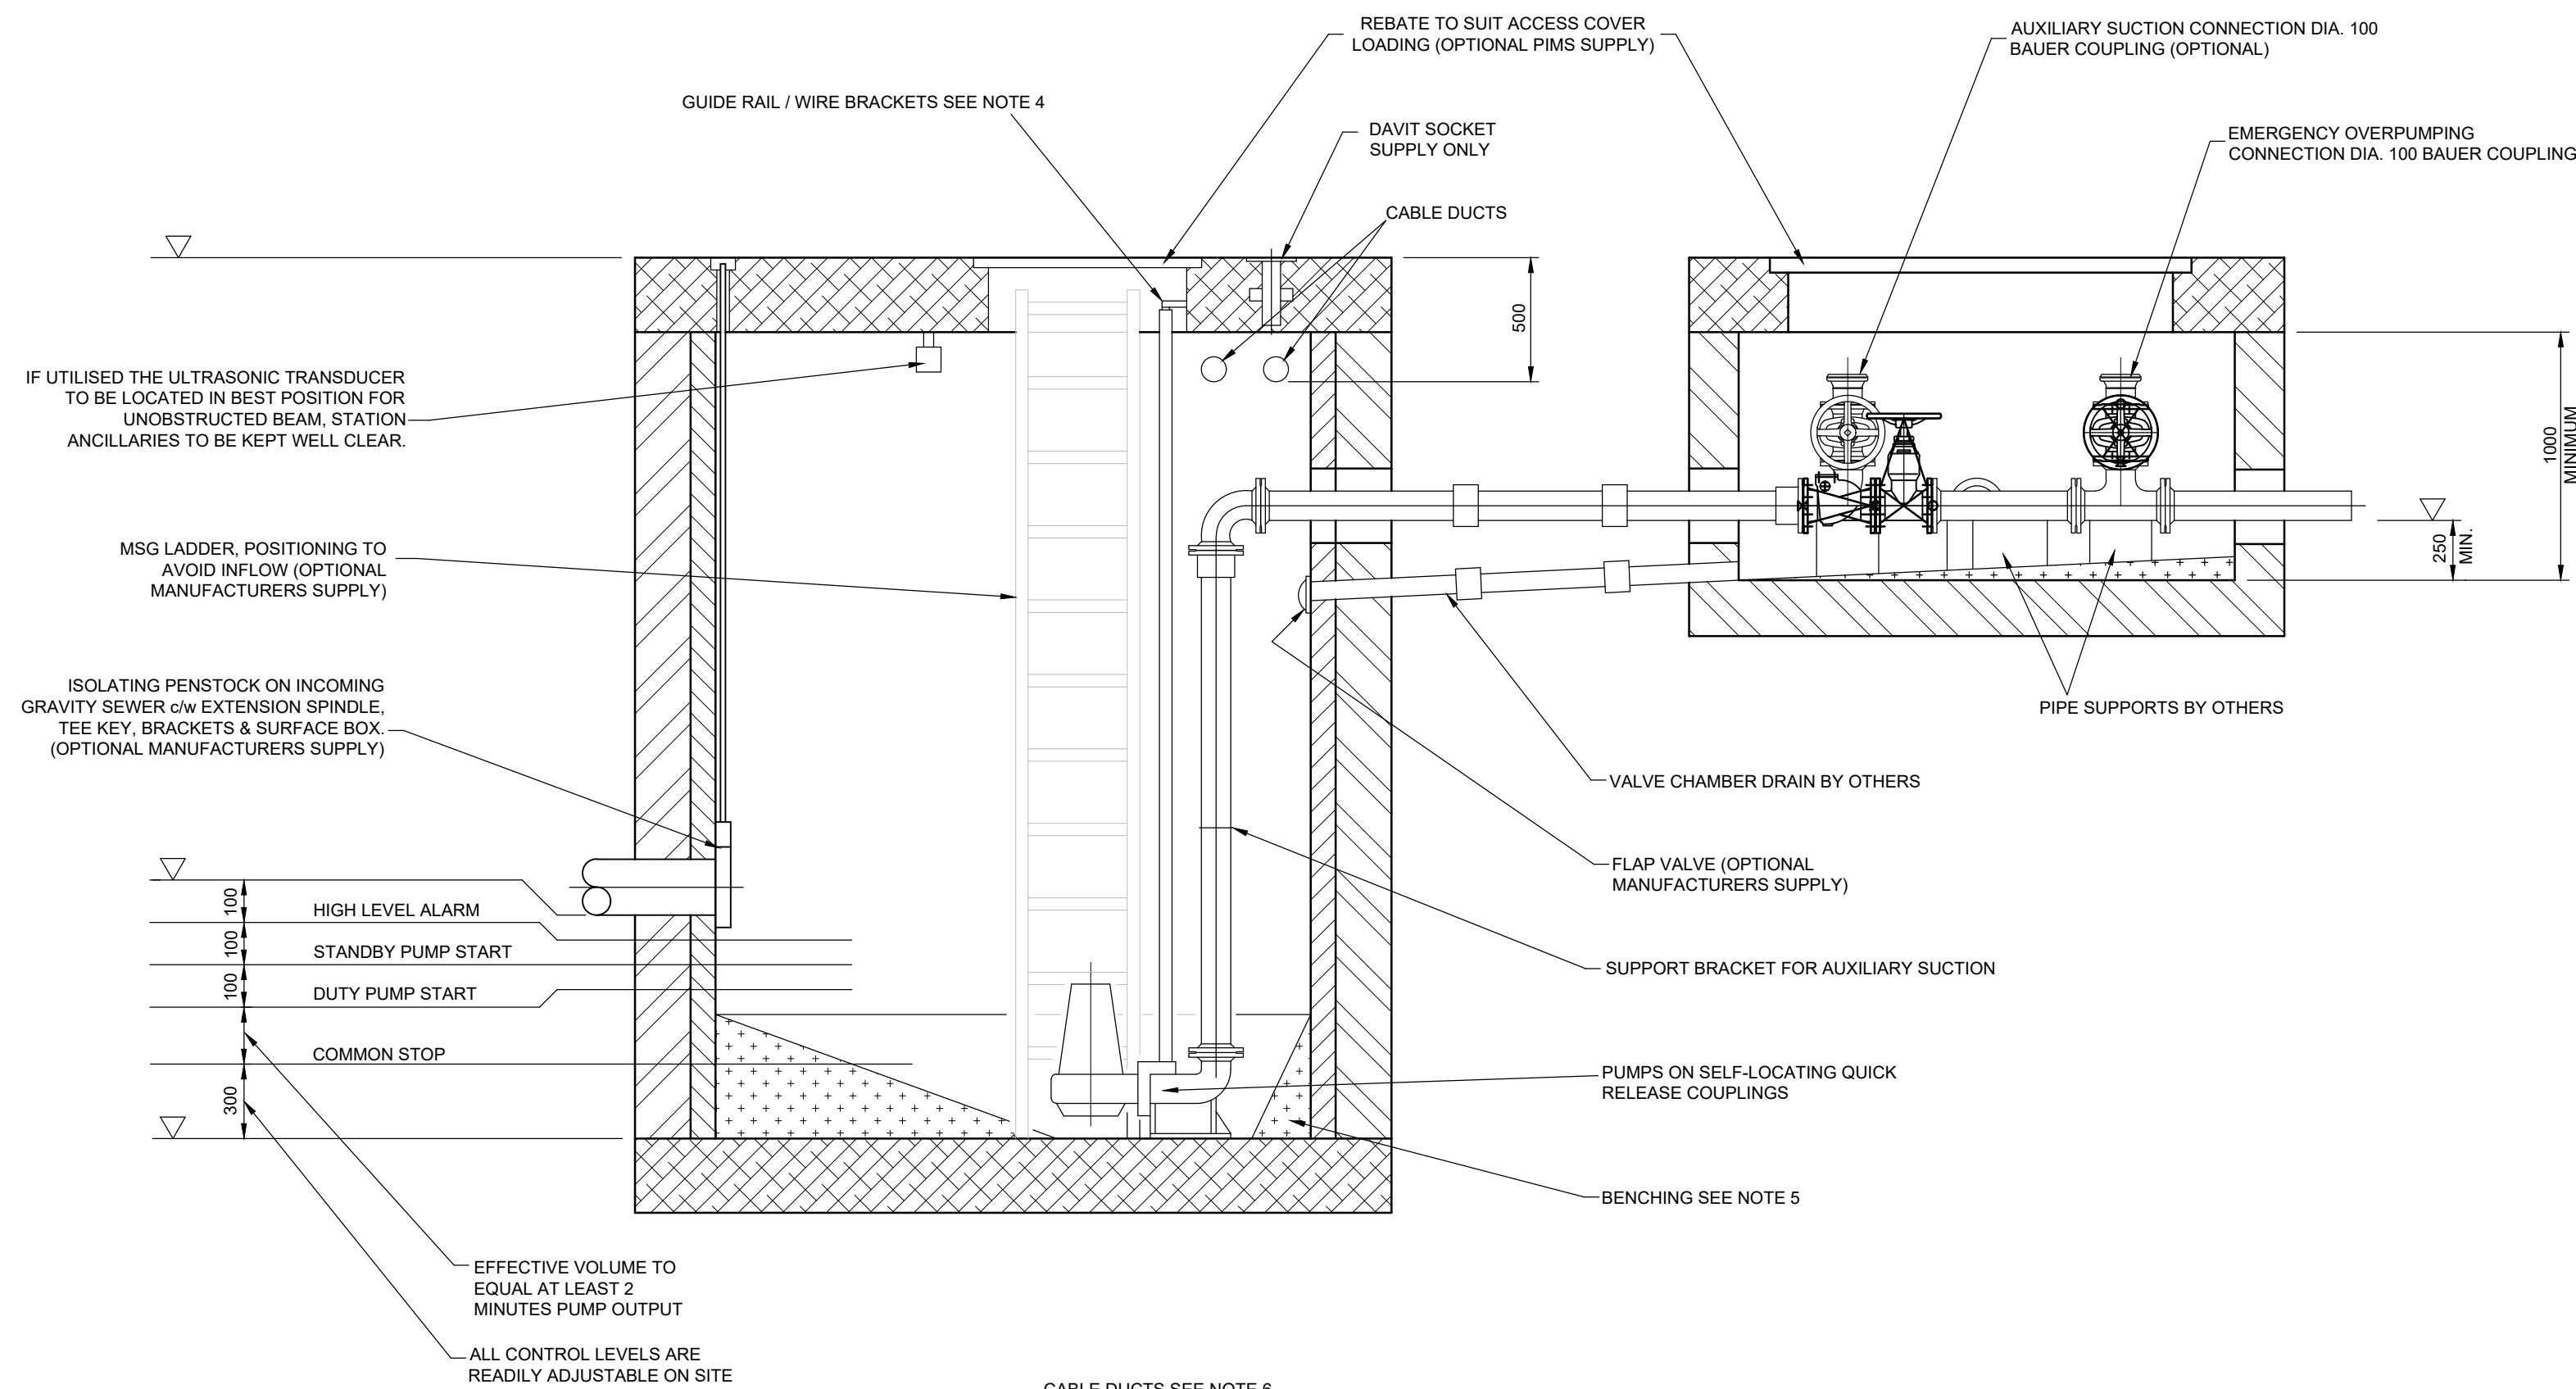


TYPICAL PUMPING STATION LAYOUT


SPECIFIC PUMPING STATION DETAILS TO BE CONFIRMED OBTAINED BY MANUFACTURER
PUMP STATION IN ABEYANCE PENDING DESIGN

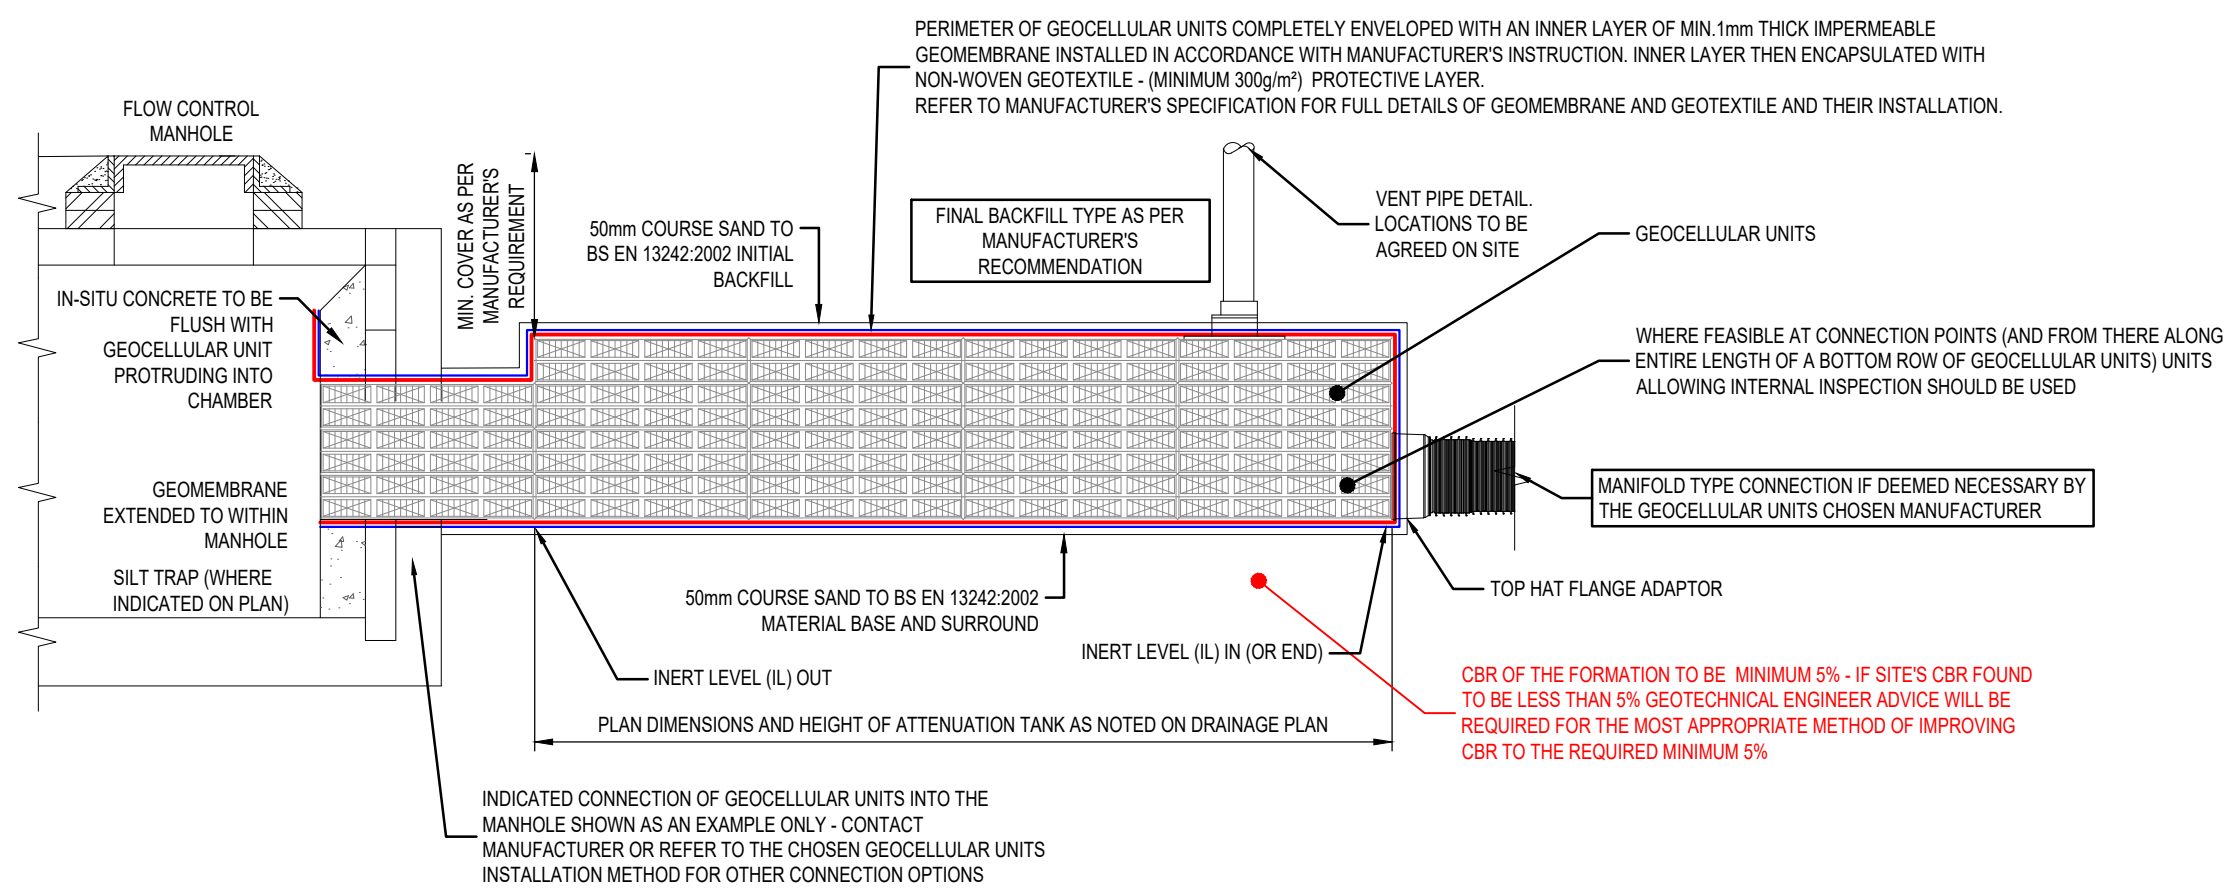


TYPICAL SECTION THROUGH GEOCELLULAR STORAGE ATTENUATION TANK

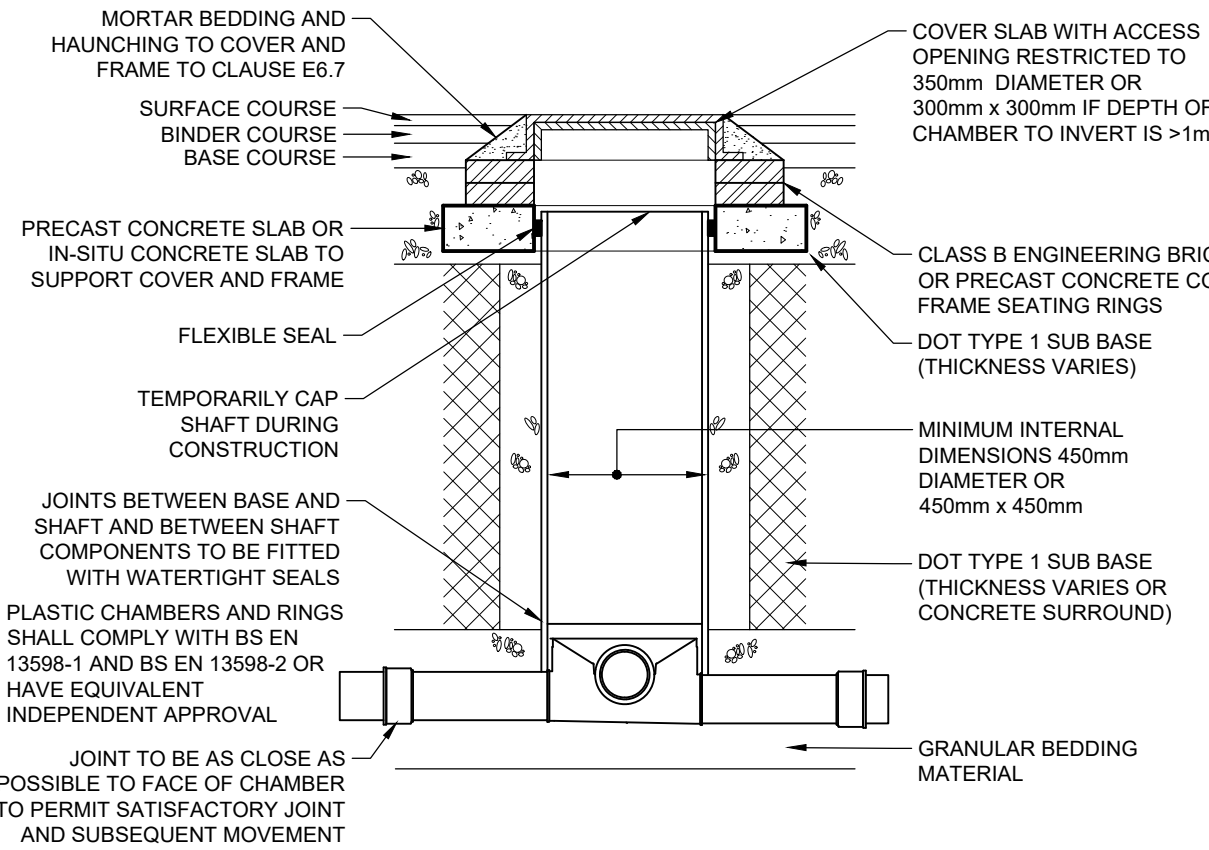

TYPICAL INSPECTION CHAMBER DETAIL - TYPE 3
(FLEXIBLE MATERIAL DETAIL) MAXIMUM DEPTH FROM COVER LEVEL TO SOFFIT OF PIPE IN AREAS SUBJECT TO VEHICLE LOADING 3m, NON-ENTRY

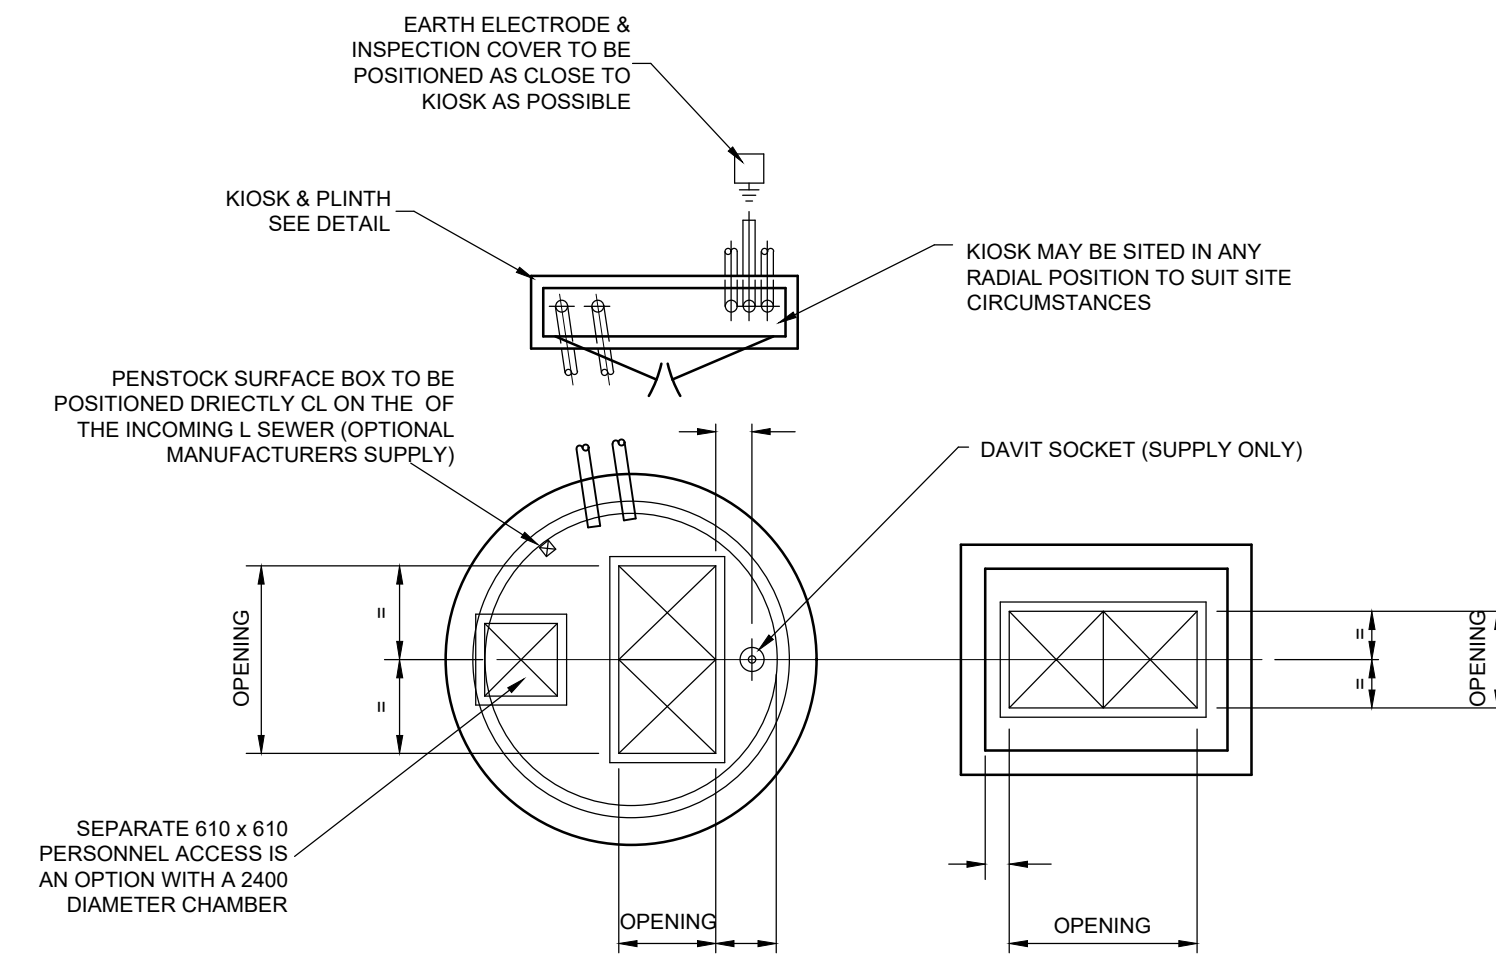

PART SITE PLAN (TYPICAL)

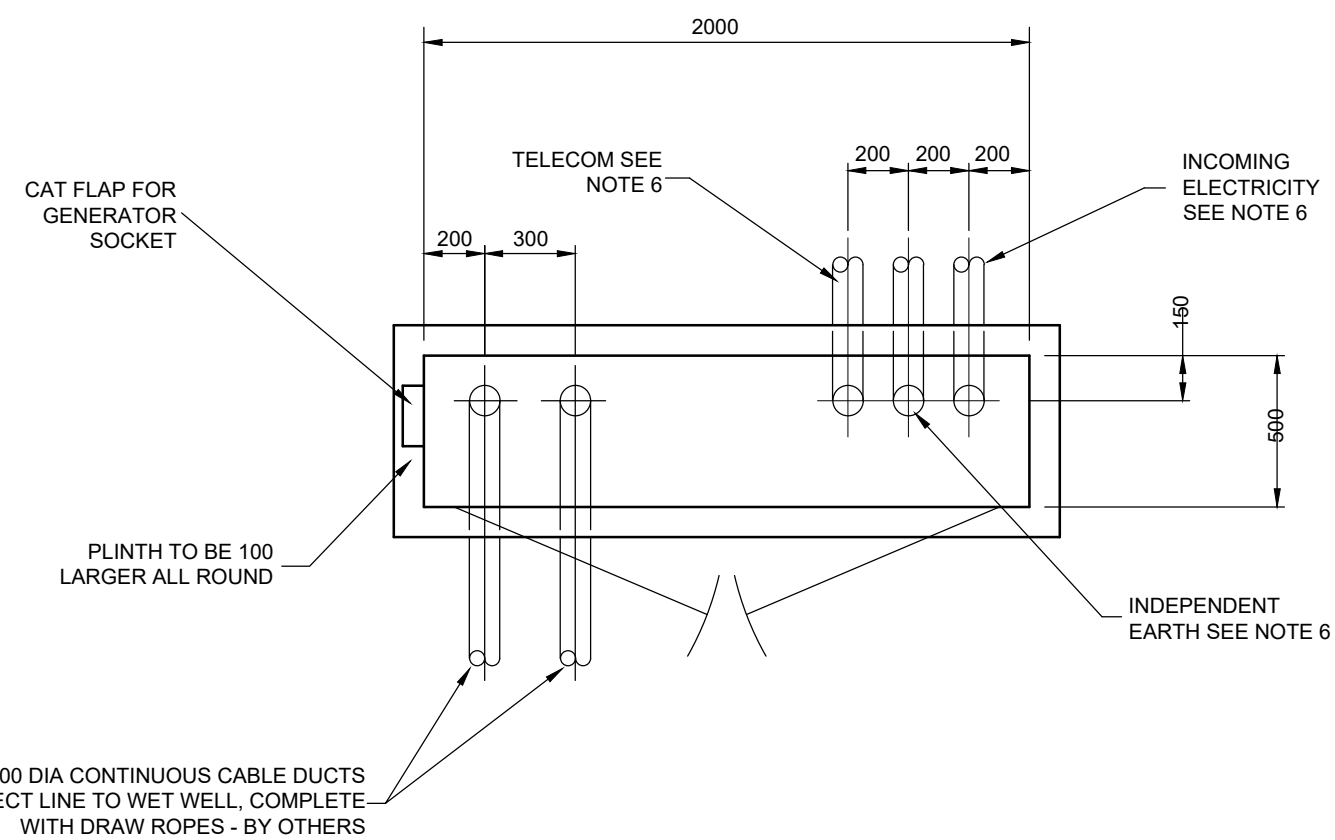

KIOSK & PLINTH DETAIL (TYPICAL)
1750H x 2000W x 500D

NOTES

1. ALL DIMENSIONS IN MILLIMETRES, UNLESS OTHERWISE STATED.
2. ALL CIVIL WORK BY OTHERS INCLUDING MAKING GOOD AROUND PIPES AFTER INSTALLATION, BENCHING, FIXING ALL STATION STEELWORK AND LAYING CABLE DUCTS.
3. ALL DUCTS 100 DIA. MIN. COMPLETE WITH DRAW ROPES AND AVOIDING ACUTE CHANGES OF DIRECTION.
4. REINFORCING BARS TO BE 75mm MIN. BELOW SURFACE.
5. BENCHING TO BE AS STEEP AS PRACTICABLE AND TO BE FORMED AFTER PUMP INSTALLATION.
6. DIRECTION OF DUCTS SHOWN DIAGRAMMATICAL - ALL DUCTS TO BE LAID ON MOST DIRECT LINE TO SUIT SERVICE BEING CARRIED.
7. SITE PLAN ILLUSTRATIVE IF NO SPECIFIC DETAILS PREVIOUSLY PROVIDED.
8. STRUCTURAL DETAIL ILLUSTRATIVE ONLY, MAY BE WORKED TO FOR DIMENSIONS BUT PIMS HAVE NO DESIGN DETAIL INVOLVEMENT.

FOR CONSTRUCTION -
SUBJECT TO APPROVAL

B	ISSUE FOR CONSTRUCTION	EW	LG	BAC	14.03.25
A	DETAILS UPDATED TO LATEST ANTLER HOMES SITE LAYOUT AMENDMENTS	LG	SW	SW	22.02.24
Rev	Amendments	Dm	Chk	App	Date

ODYSSEY

Unit 1 Pucknall Farm
Dore Lane
Brighthelm
Romey SO51 0QJ

Telephone: 01794 537880
Fax: 01266 331134
E: info@odysseyconsult.co.uk
W: www.odysseyconsult.co.uk

Job Title	ST ANNE'S DRIVE WOKINGHAM				
Drawing Title	DRAINAGE CONSTRUCTION DETAILS SHEET 2 OF 4				
Client	ANTLER HOMES				
Scale	1:20 @A1	Date	JAN 24	Designed	LG
Drawn	RML	Checked	SW	Approved	SW
Job No	23-190	Drawing No	23-190-236	Rev	B