


Rev:	Description:	By:	Date:
------	--------------	-----	-------

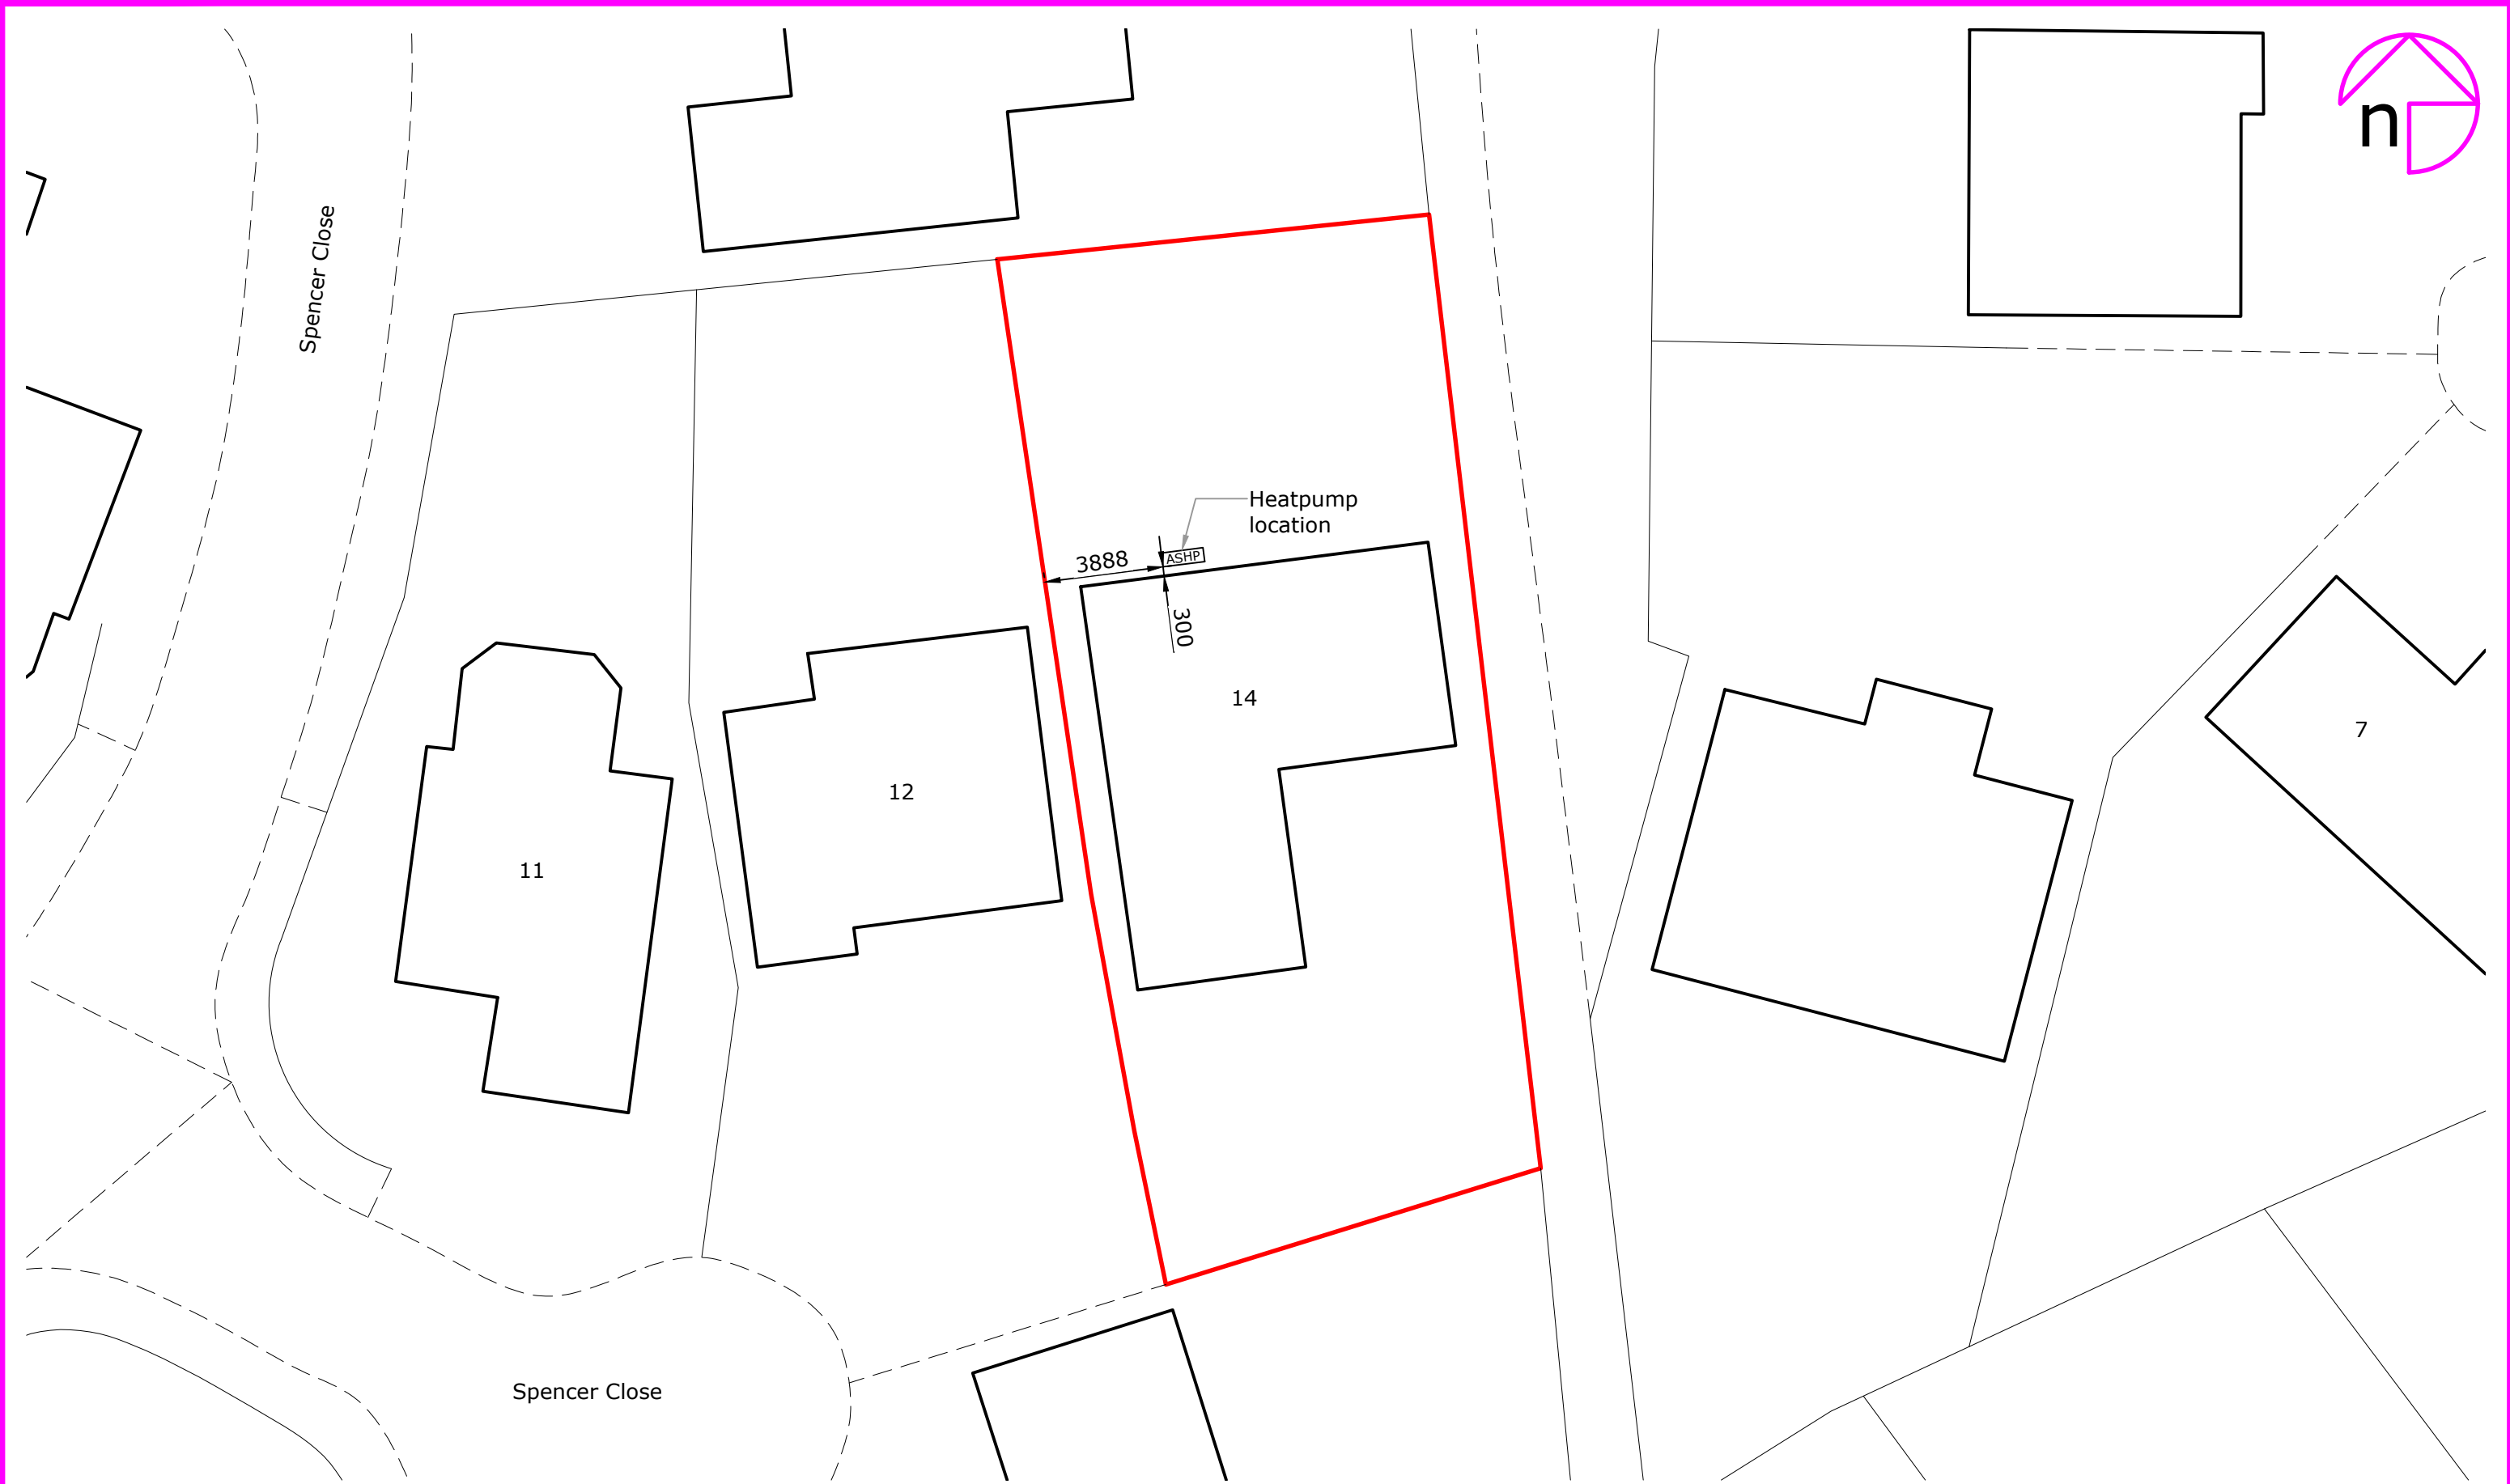

Accredited by:


Client/Project: Diane Cox, 14 Spencer Close, Wokingham, Berkshire, RG41 3BW	Project status: PLANNING (installation of air source heat pump)
	Drawing title: Site plan as proposed

Scale: 1:200	Paper Size: A3	Drawn: A Walton	Checked: E Blakesley
Project ID: J-E1EC2CAB	Drawing No: 03	Revision:	Date: 30.09.2024