


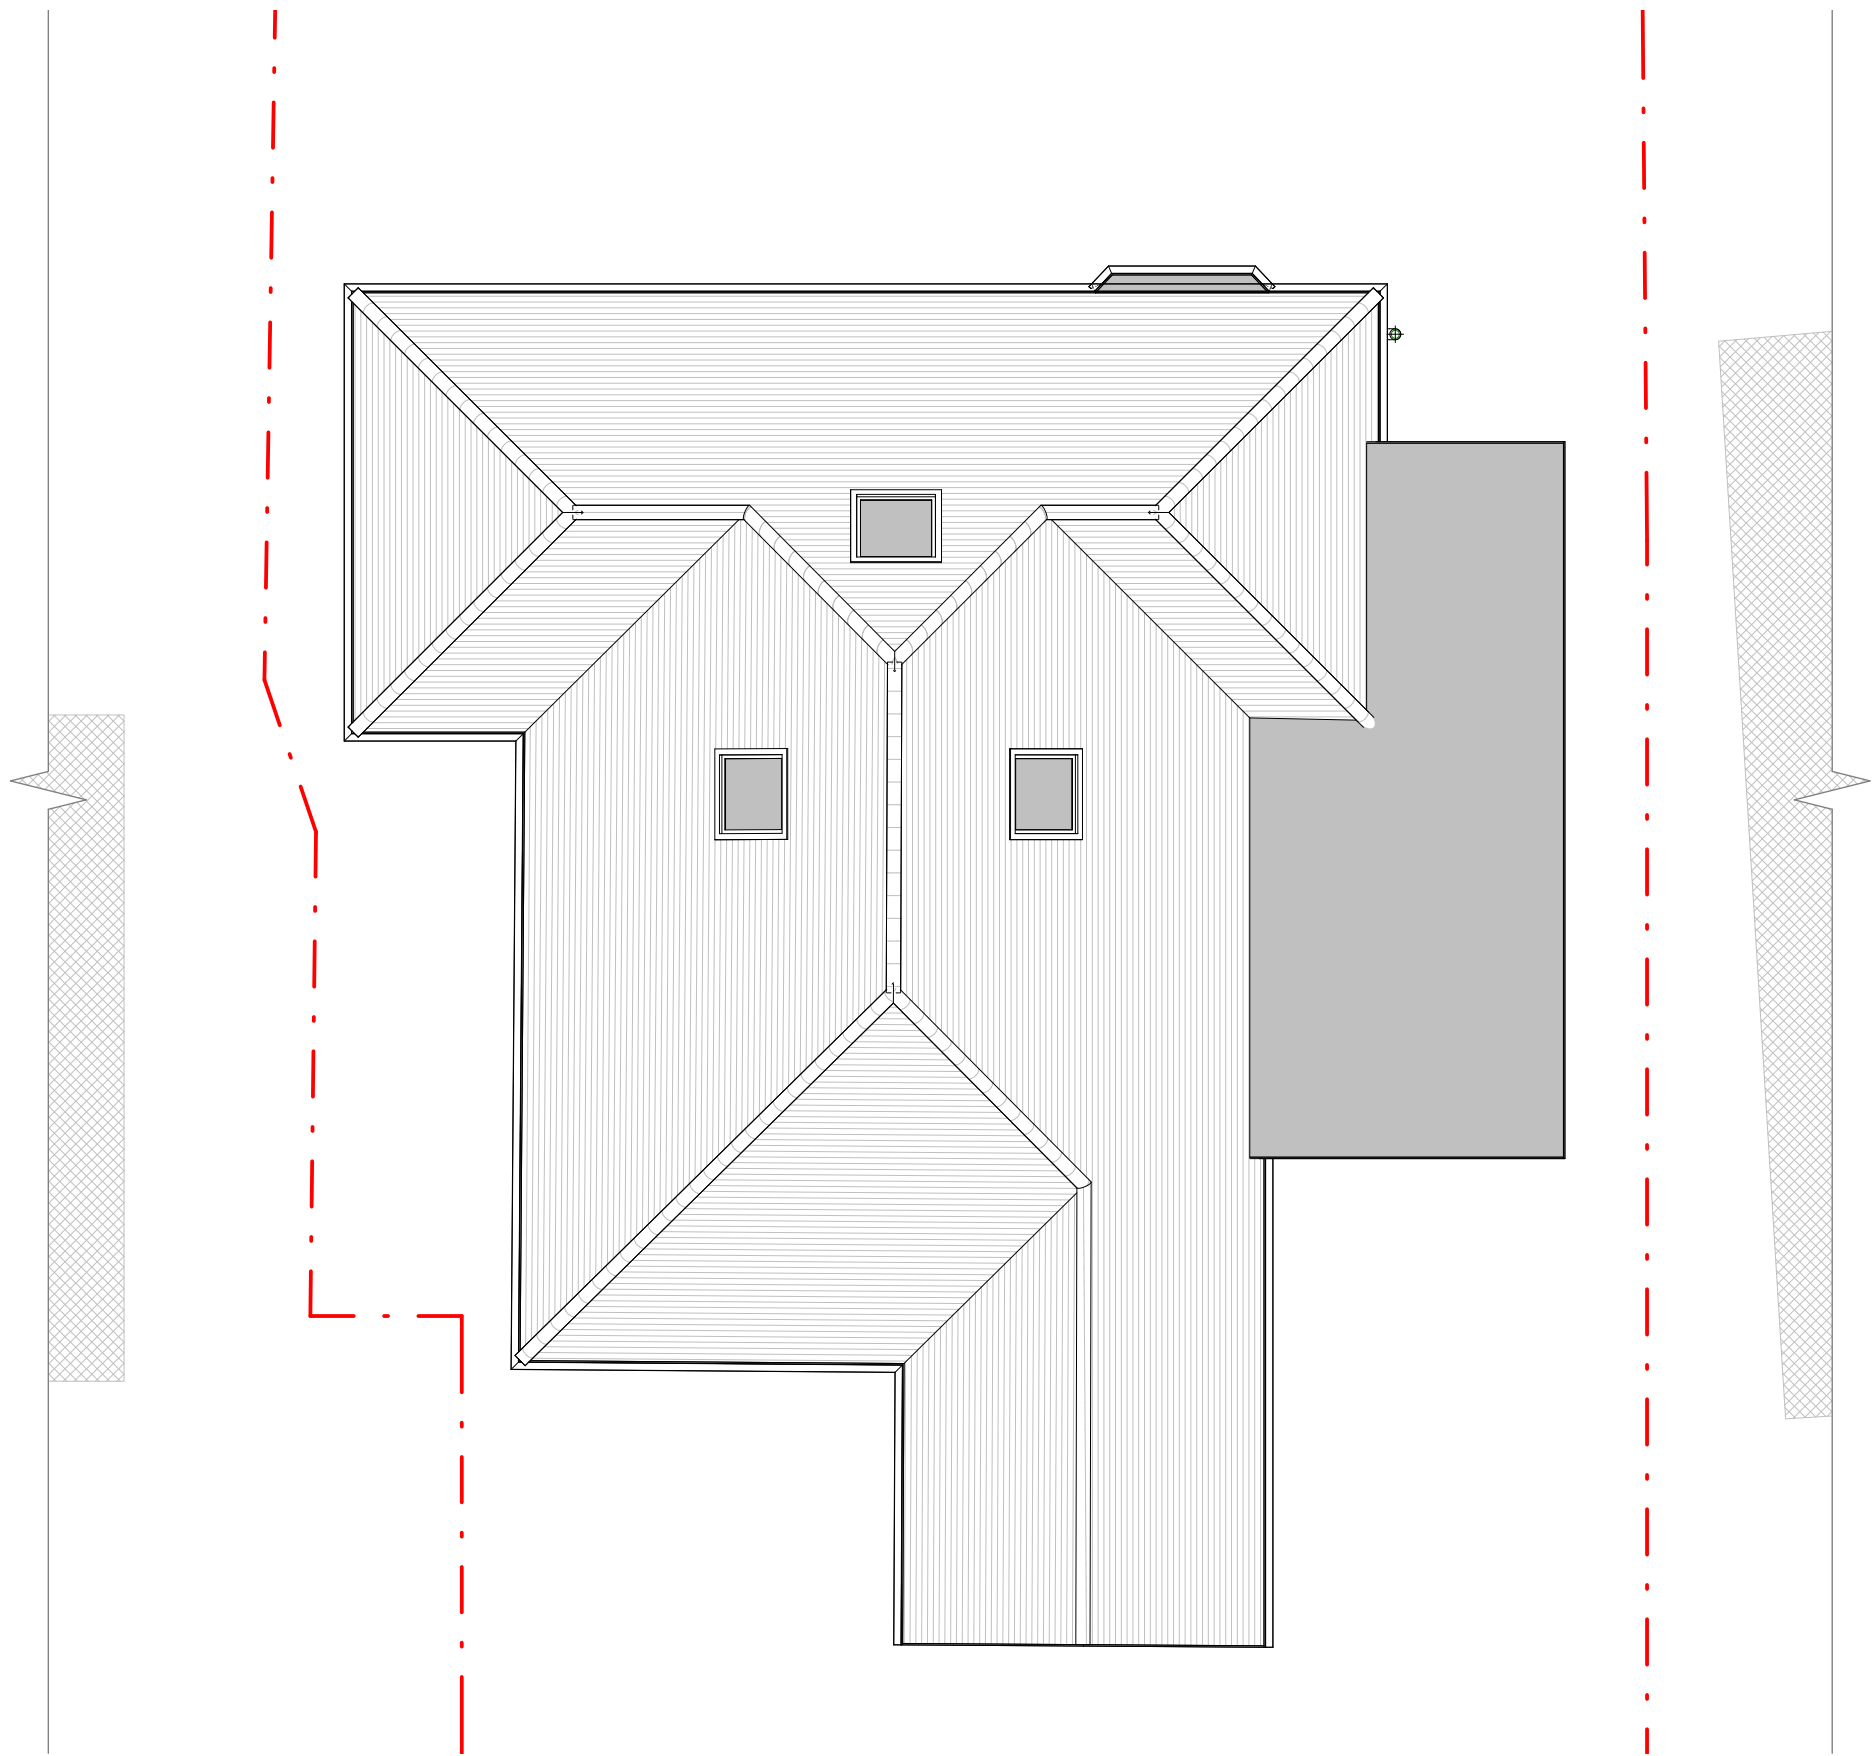

Roof Plan

 FLUENT ARCHITECTURAL DESIGN SERVICES TEL: 0800 043 8838 E-MAIL: INFO@FLUENT-ADS.CO.UK WEB: FLUENT-ADS.CO.UK	204 London Road Wokingham	Scale @ A3 1 : 100	Drawing number P.M.202	Key: Existing Proposed SVP Existing drainage Proposed drainage Overhead 0 1 2 3 4 5 10 GRAPHIC SCALE: 1:100	No.	Description	Date
	Existing Roof Plan	Date 26.08.25	Project number 2407		0	First Draft	26.08.25
		Drawn by S.G	Rev 0				