


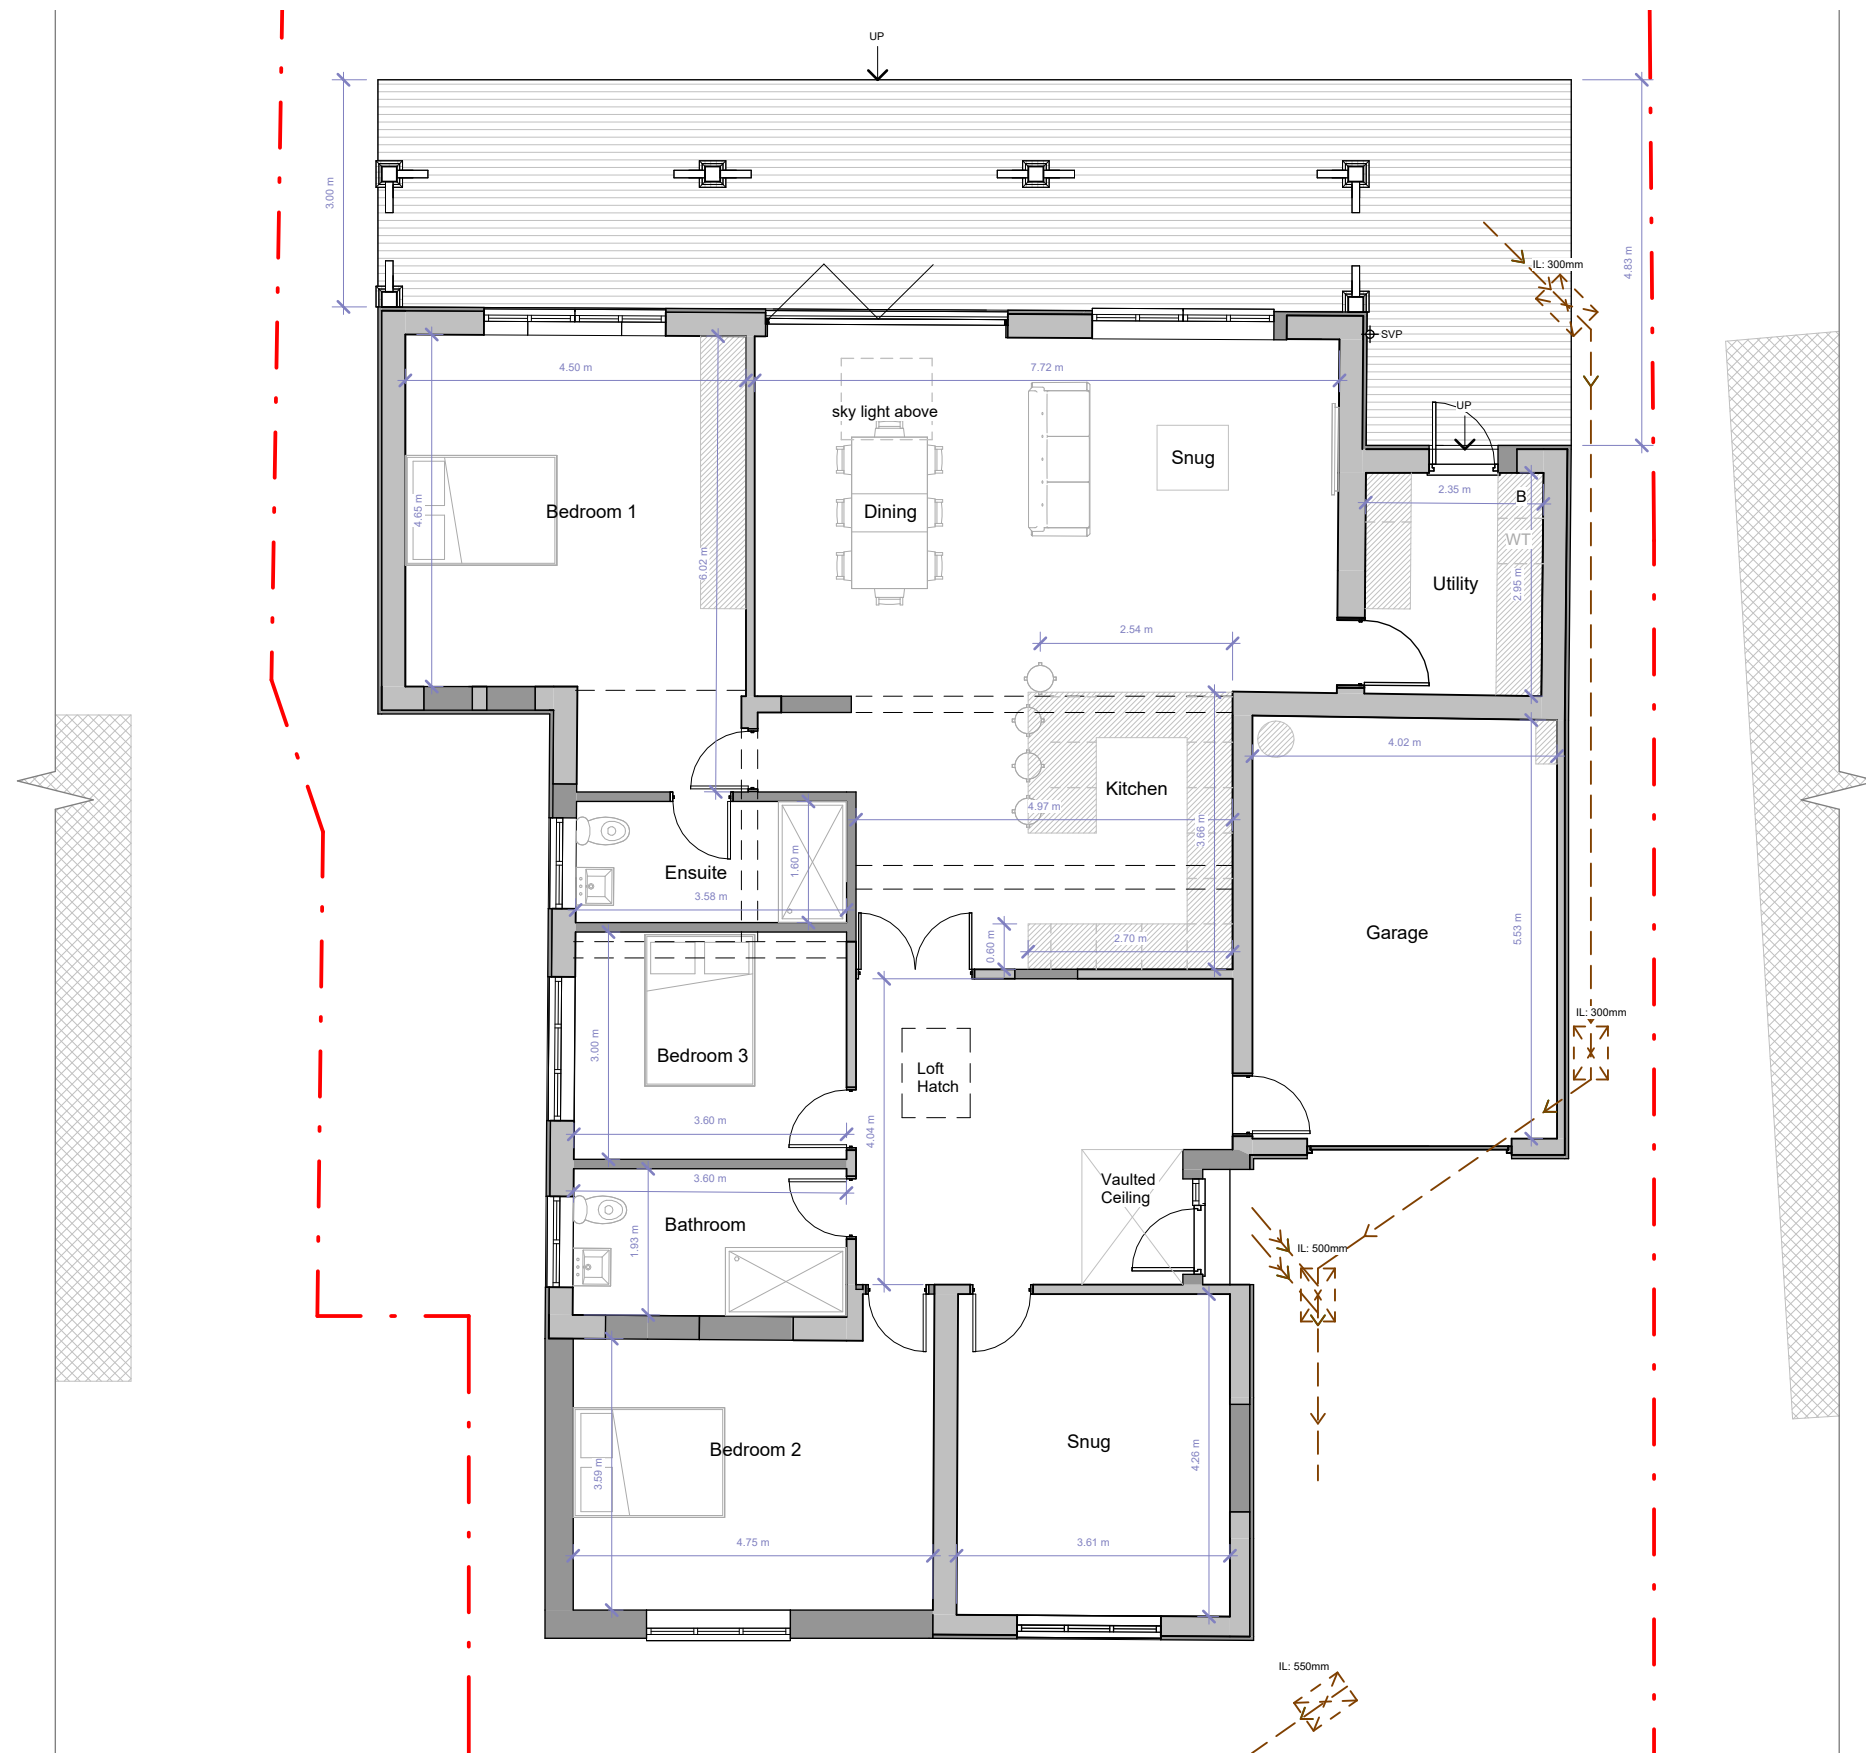

Ground Floor



**FLUENT**  
ARCHITECTURAL DESIGN SERVICES  
TEL: 0800 043 8838  
E-MAIL: INFO@FLUENT-ADS.CO.UK  
WEB: FLUENT-ADS.CO.UK

204 London Road Wokingham

Proposed Ground Floor Plan

Scale @ A3  
1 : 100

Date  
26.08.25

Drawn by  
S.G

 
Drawing number  
P.M.500

Project number  
2407

Rev  
H

Key:

Existing Proposed SVP Boundary line  
Existing drainage Proposed drainage Overhead



| No. | Description     | Date     |
|-----|-----------------|----------|
| B   | Drawing amended | 16.01.26 |
| C   | Drawing amended | 08.06.26 |
| D   | Revision 8      | 08.06.26 |
| E   | Revision 9      | 12.06.26 |
| F   | Revision 10     | 15.06.26 |
| G   | Revision 11     | 24.06.26 |
| H   | Revision 12     | 10.09.26 |