




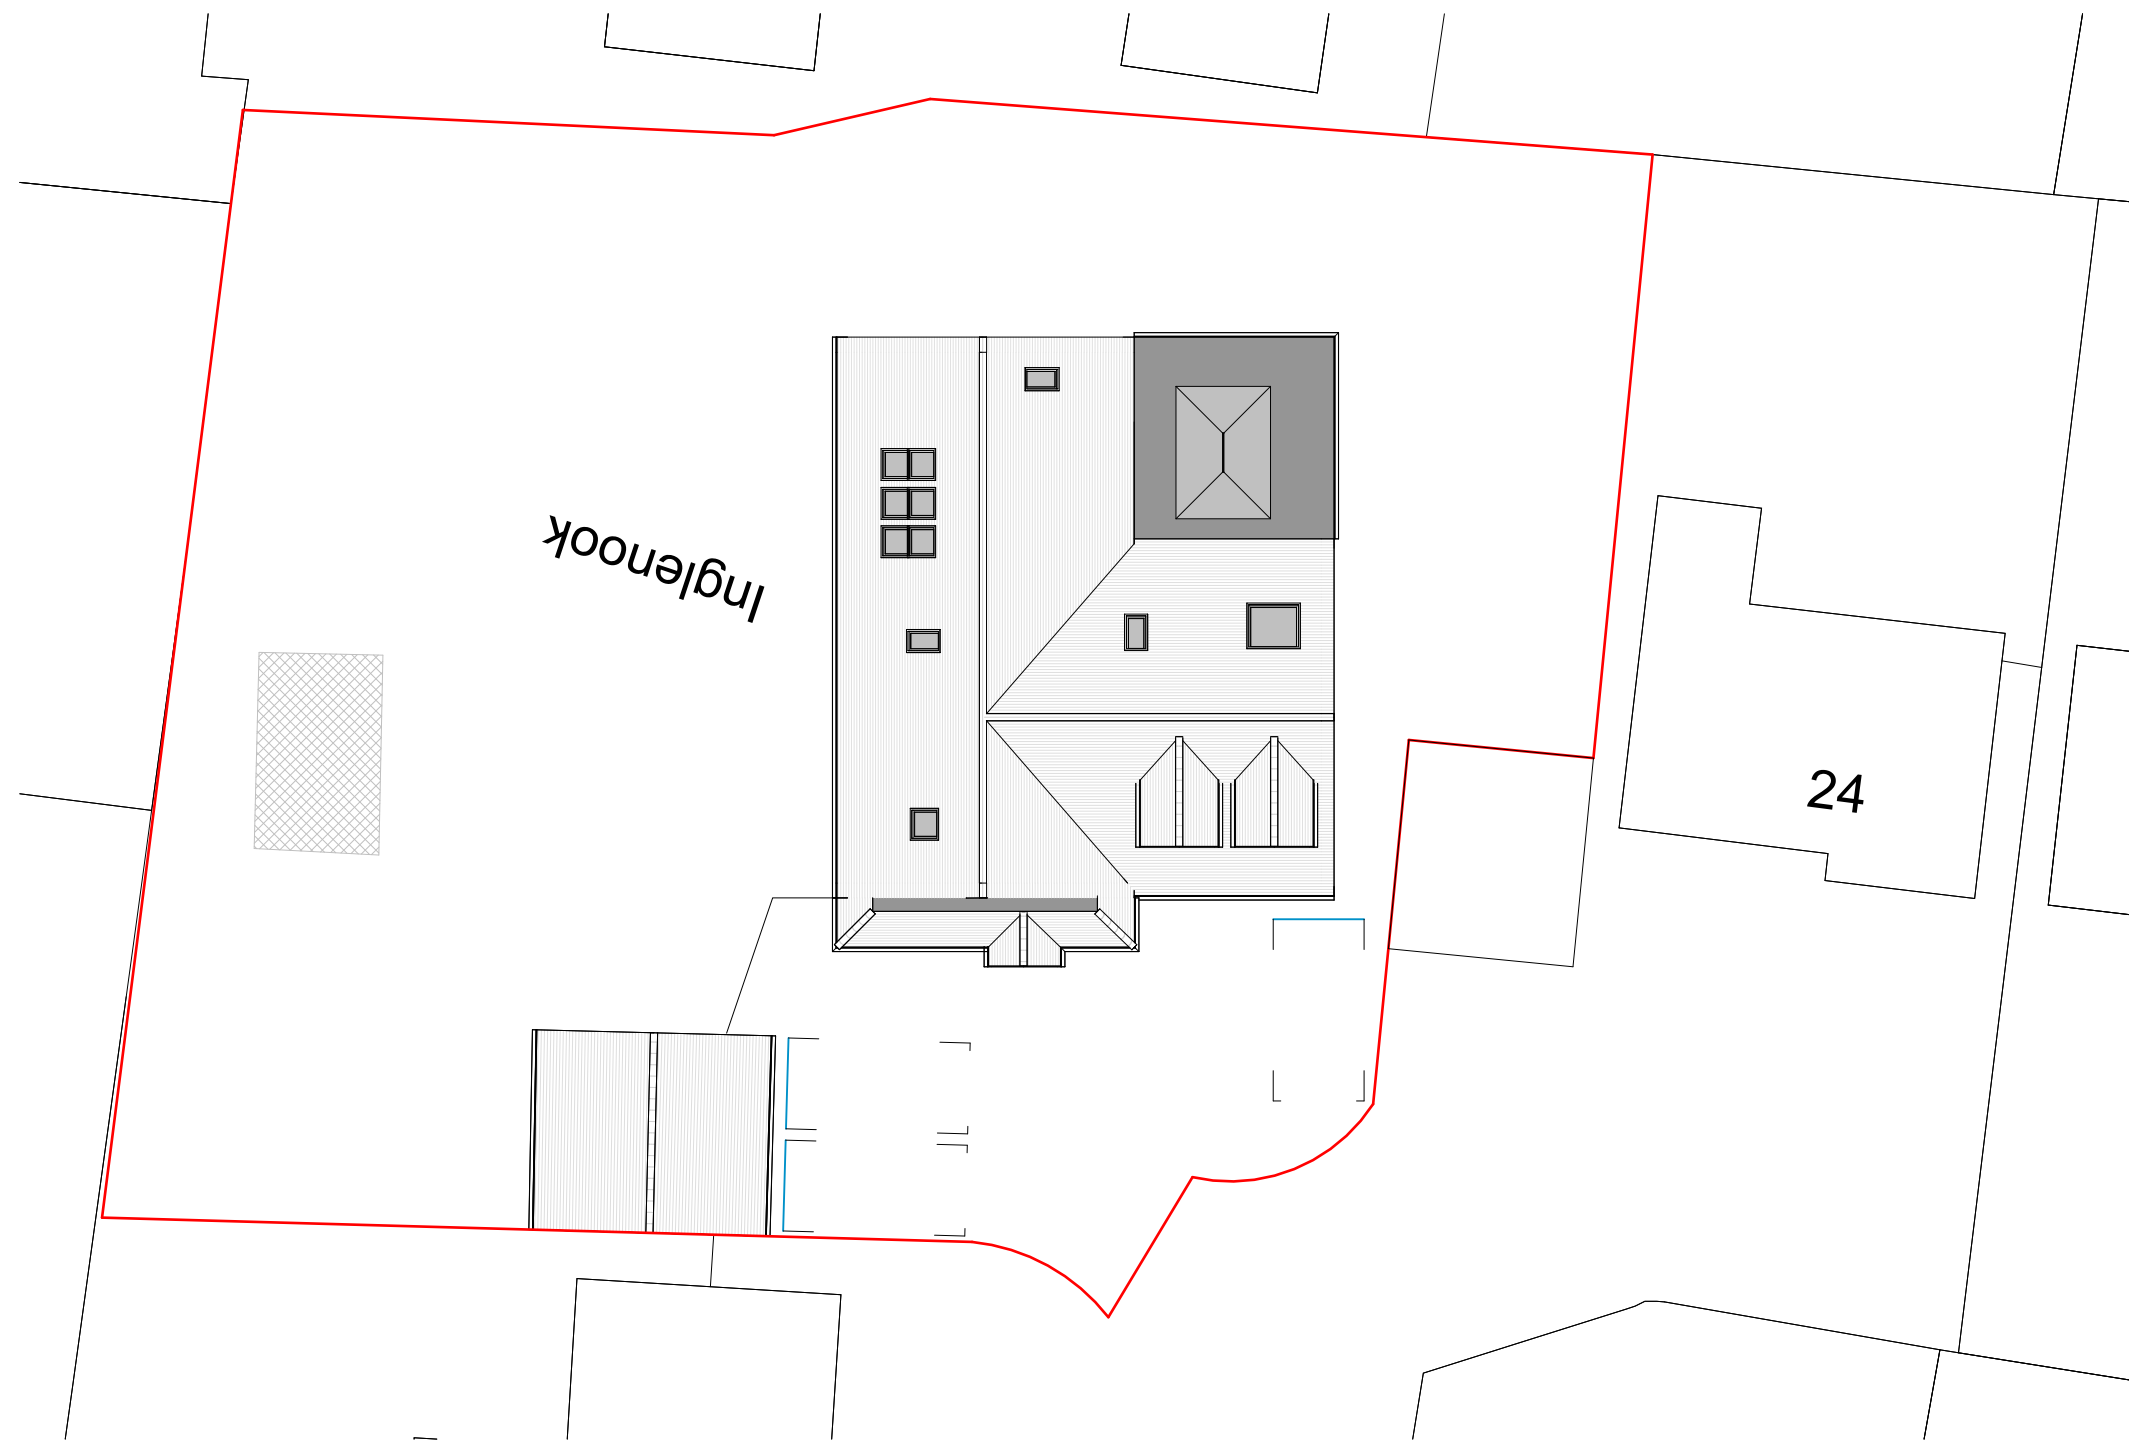

Site Plan

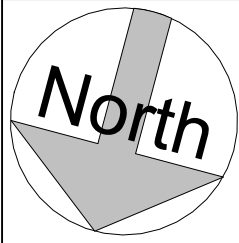

3D View 1

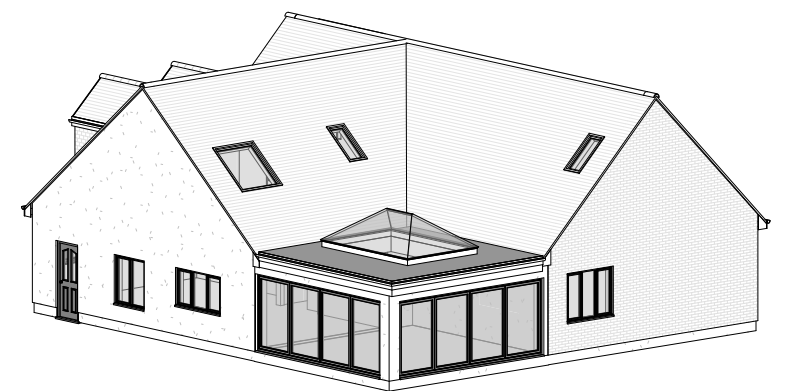

3D View 2



FLUENT
ARCHITECTURAL DESIGN SERVICES
TEL: 0800 043 8838
E-MAIL: INFO@FLUENT-ADS.CO.UK
WEB: FLUENT-ADS.CO.UK

Inglenook, Springdale, Finchampstead

Proposed Site Plan and 3D Views

Scale @ A3
1 : 200

Date
13.04.26

Drawn by
S.G

 
Drawing number
P.M.400

Project number
2554

Rev
B

Key:

Existing Proposed SVP Boundary line
Existing drainage Proposed drainage Overhead



No.	Description	Date
0	First Draft	13.04.26
A	Client's comments (1)	24.04.26
B	Client's comments (2)	29.04.26