



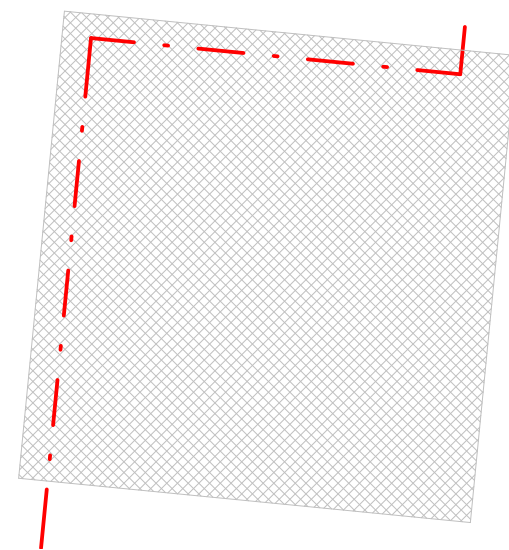

Roof Plan

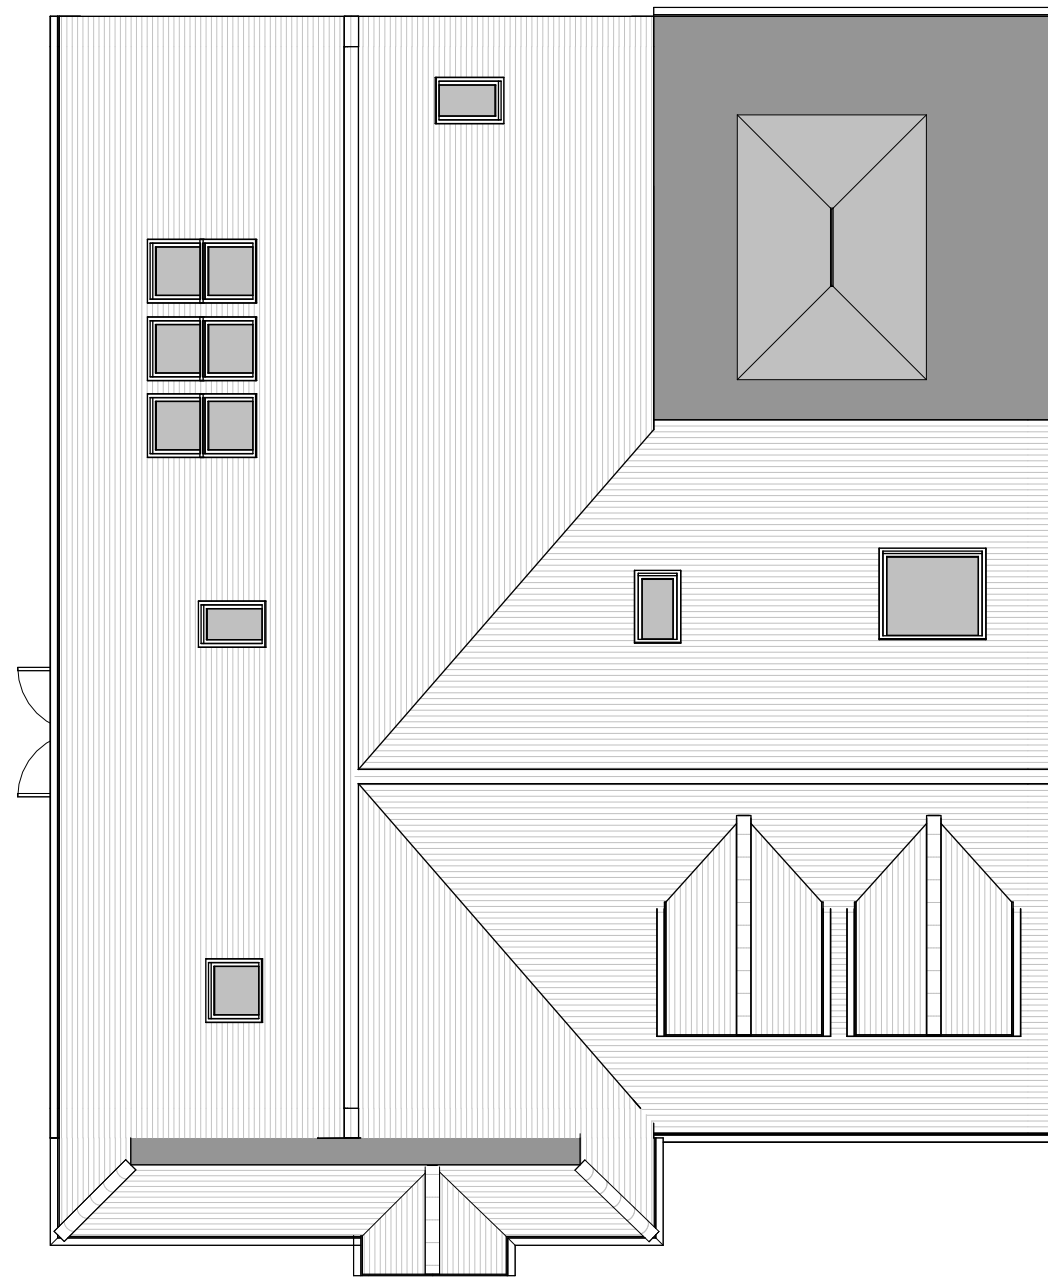

FLUENT
ARCHITECTURAL DESIGN SERVICES
TEL: 0800 043 8838
E-MAIL: INFO@FLUENT-ADS.CO.UK
WEB: FLUENT-ADS.CO.UK

Inglenook, Springdale, Finchampstead	Scale @ A3 1 : 100	Drawing number P.M.502	Key: Existing Proposed SVP Boundary line Existing drainage Proposed drainage Overhead 01234510 GRAPHIC SCALE: 1:100
	Date 13.04.26	Project number 2554	
	Drawn by S.G	Rev A	
Proposed Roof Plan			No. Description Date 0First Draft13.04.26 AClient's comments (1)24.04.26