


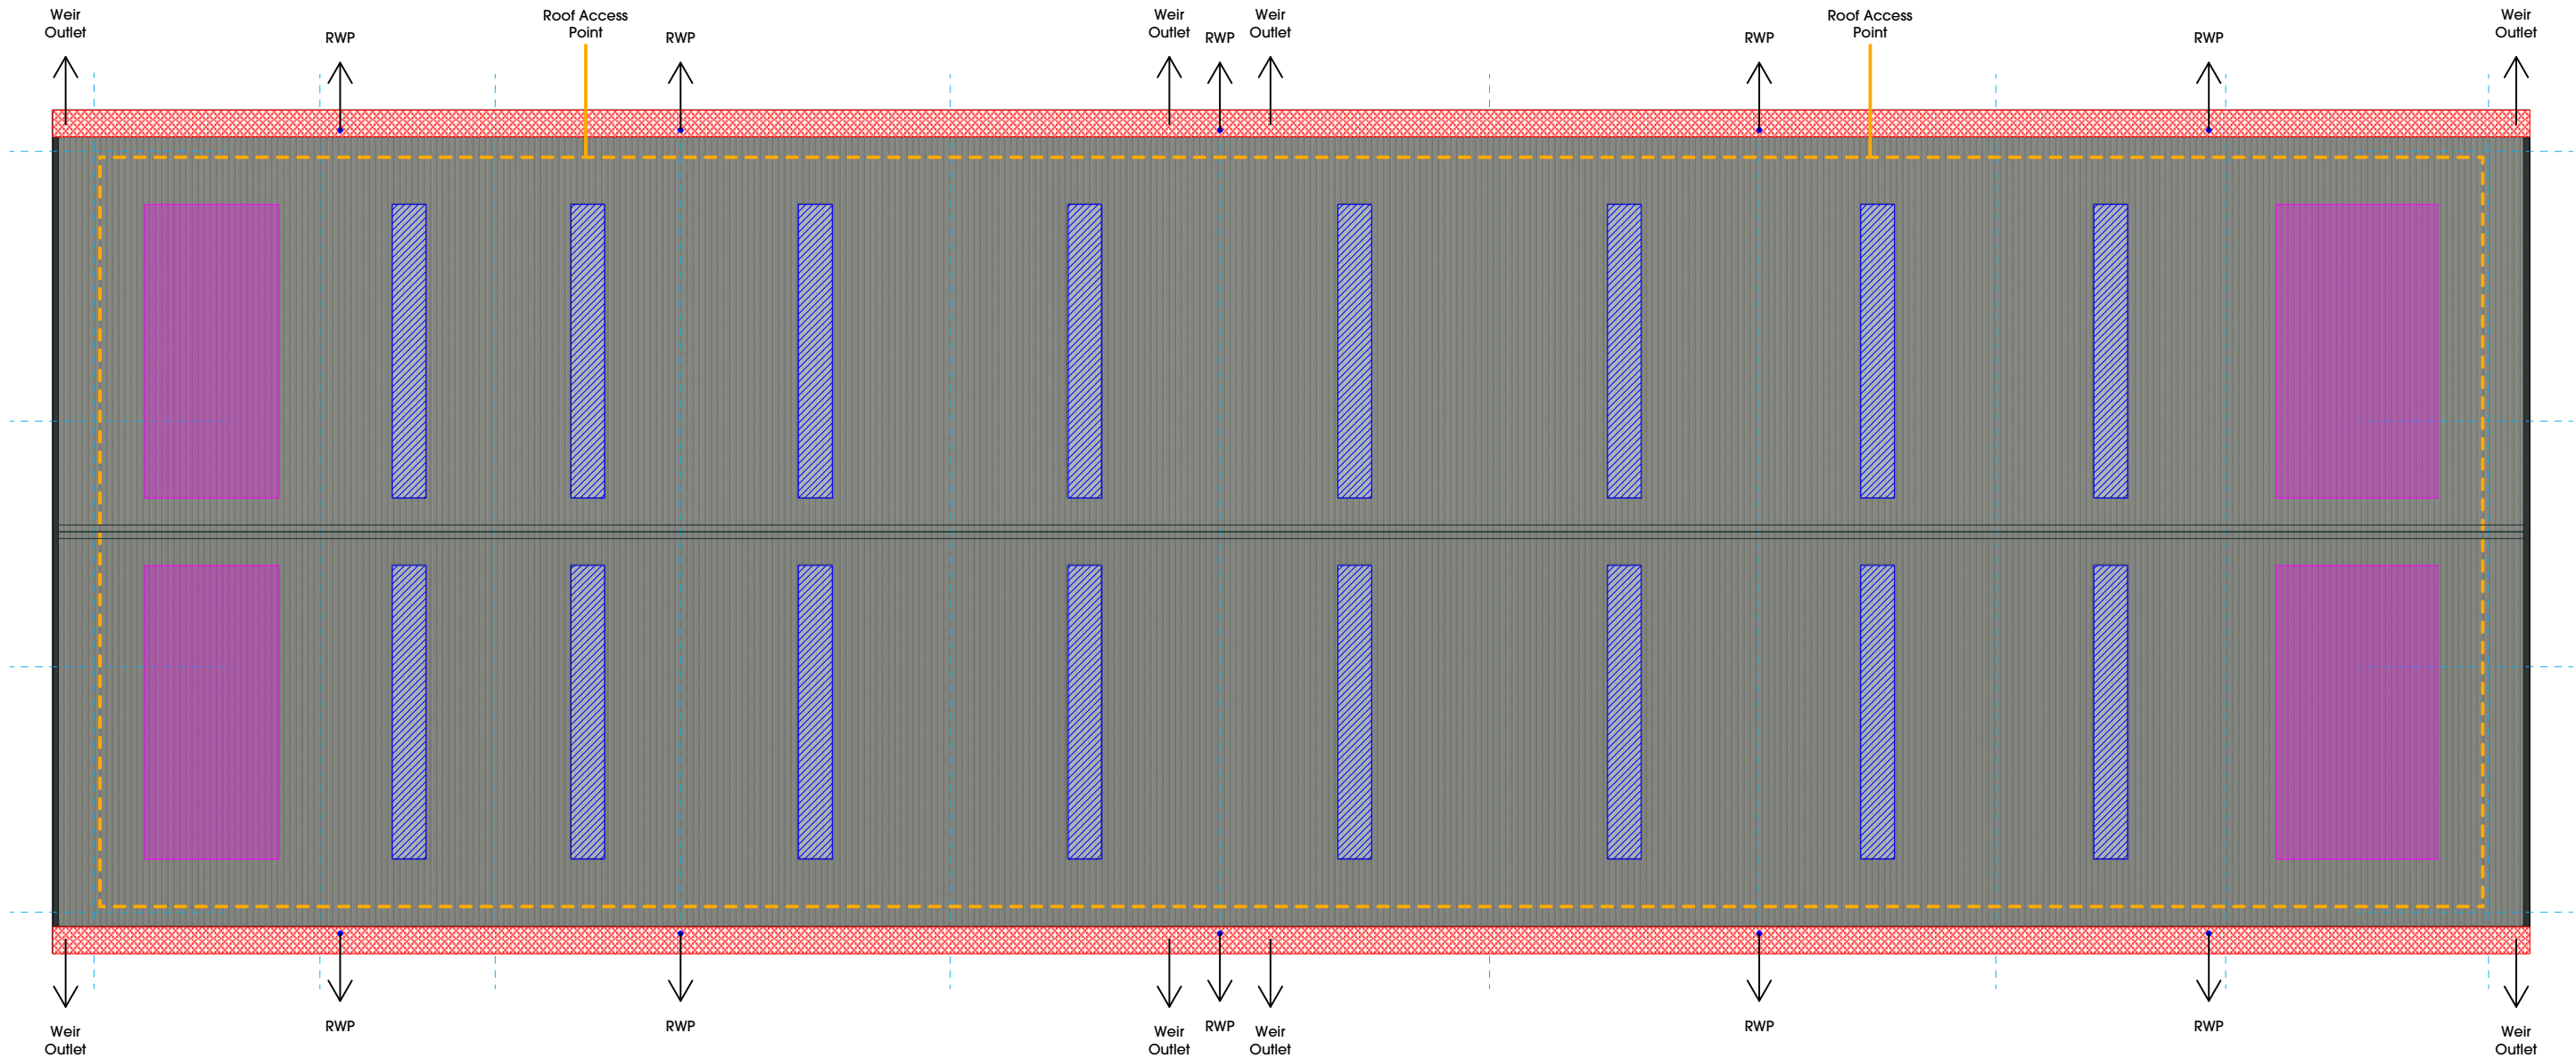

1 **UNIT 4-5 ROOF PLAN**
Scale: 1:200

NOTES

Built up roof. Colour - GOOSEWING GREY RAL 7038

Allowance for 10% GRP style rooflights.

Proprietary mansafe / Fall protection system to be installed as appropriate subject to PV installation requirements. If installed mansafe to be extended to provide safe access to all areas - details tbc.

Indicative pv zones. Requirement for pv panels and setting out tbc. Information required from specialist. Indicative locations highlighted on roof plan.

Roof to be drained via rainwater pipes - final location TBC

