



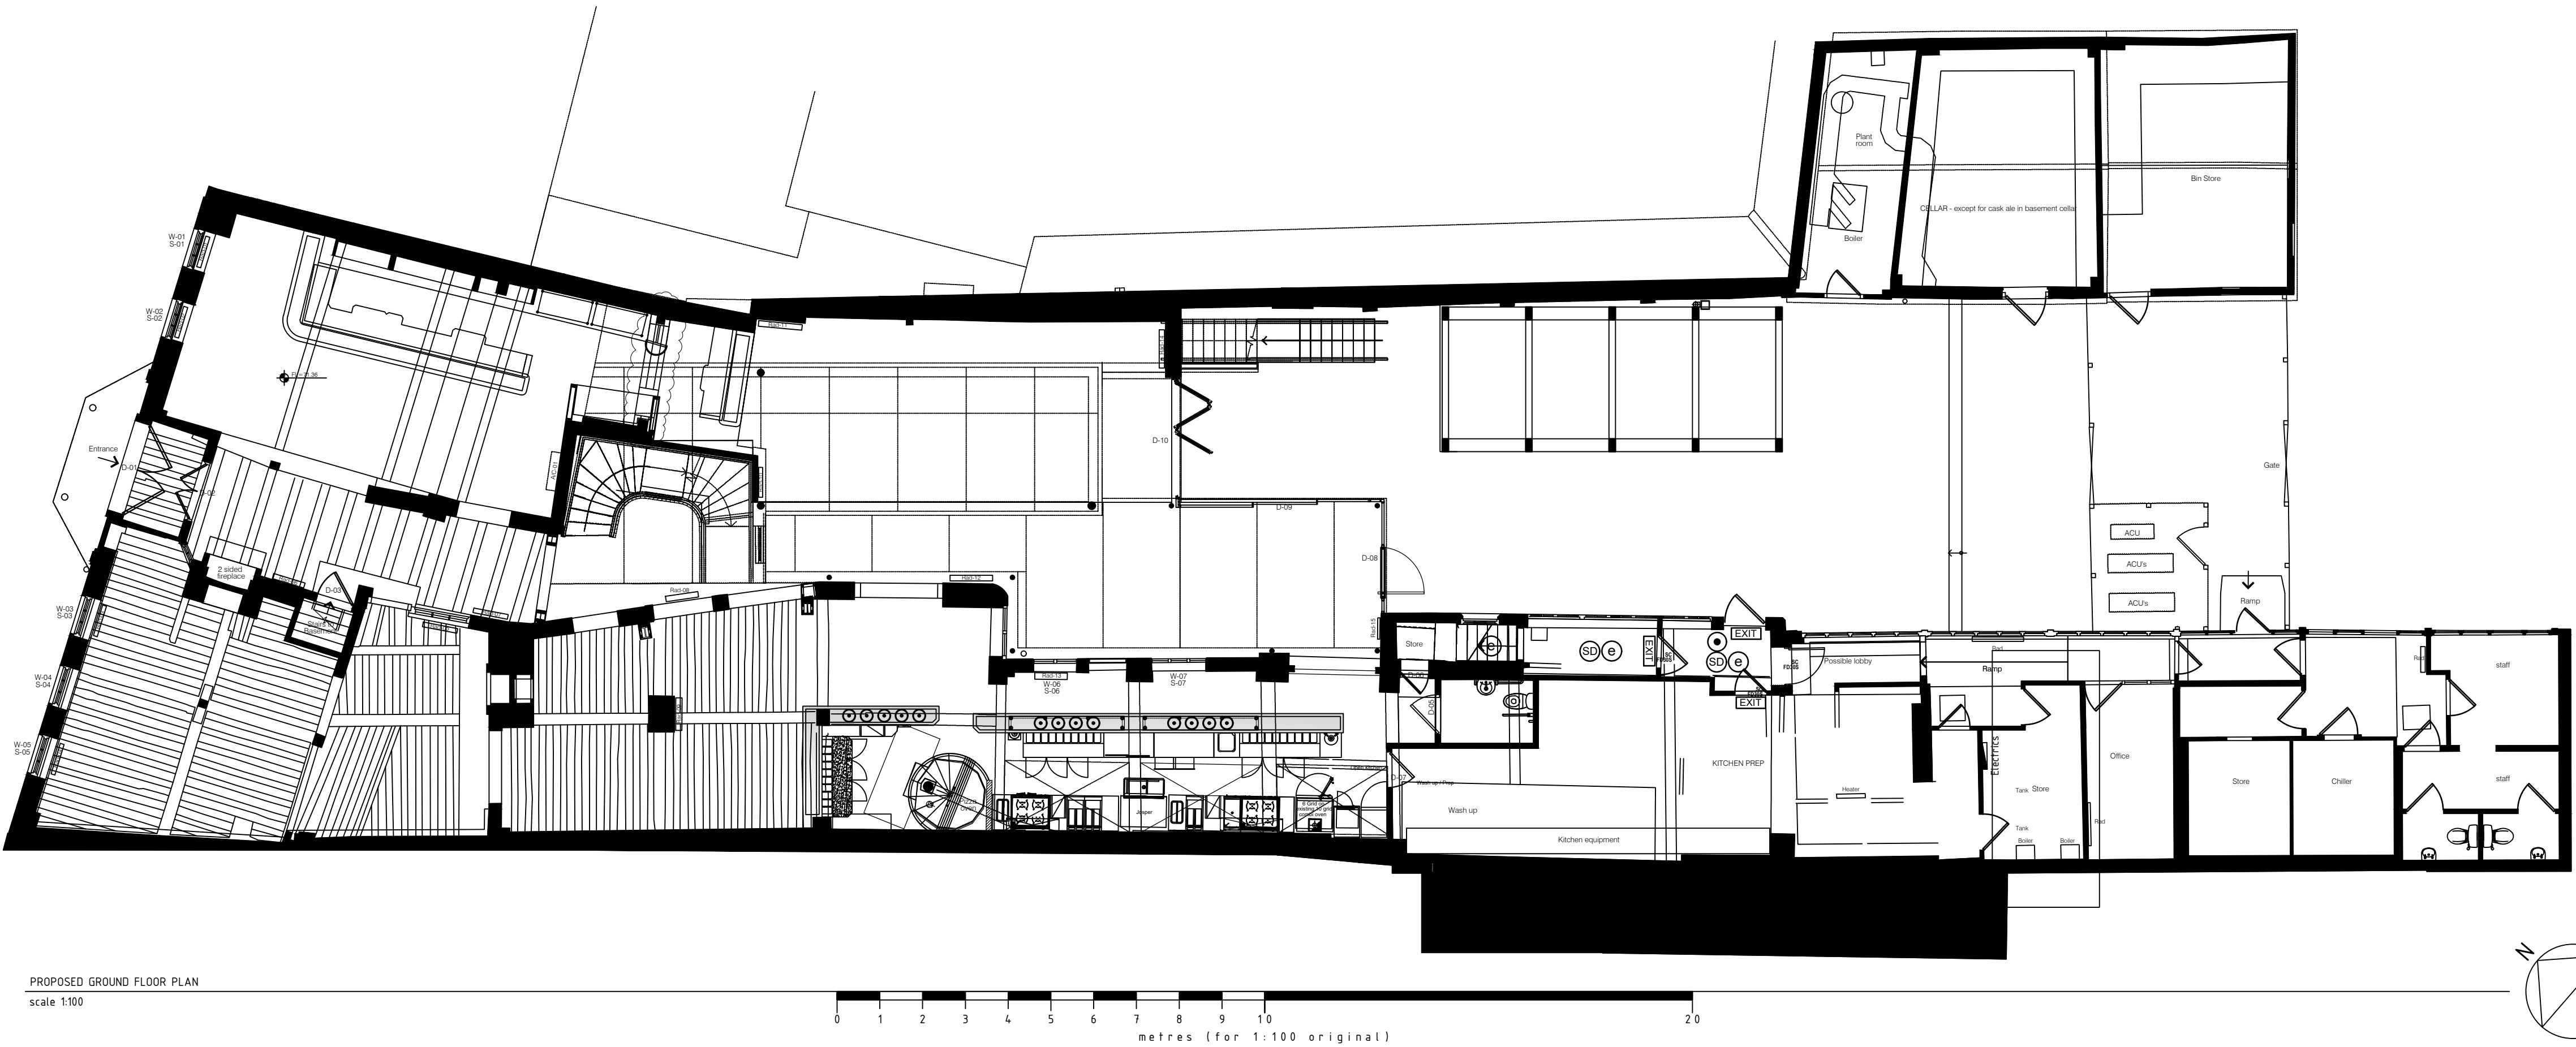

ref	key	description	reference	Quan.
		fire alarm panel •To be linked back to existing fire alarm panel	Main Contractor to supply unit, provide power & fit	
		internally illuminated 'fire exit' or graphic equivalent - 75mm high letters (bs 5499) arrow indicates directional	Main Contractor to supply unit, provide power & fit	
		area covered by visible warning indicator & sounder at high level - (bs 5839)	Main Contractor to supply unit, provide power & fit	
		Area to covered by non-maintained emergency luminaire (bs 5266)	Main Contractor to supply unit, provide power & fit	
		area covered by smoke detector (bs 5839)	Main Contractor to supply unit, provide power & fit	
ref	key	description	reference	Quan.
		manual call point (bs 5839)	Main Contractor to supply unit, provide power & fit	
		area covered by heat detector (bs 5839)	Main Contractor to supply unit, provide power & fit	
		Push bar or single action fastening to be available when the premises are in use	Main Contractor to supply & fit	
		self closing - opening force limited to 20 newtons to comply with Building Regulations Doc. M	Main Contractor to supply & fit	
		30 min fire resistant doorset with intumescent strip, smoke seal & self closer.	Main Contractor to supply & fit	
ref	key	description	reference	Quan.
		Vision panel - refer to FD30 / FD650's specifications.	Main Contractor to supply & fit	
		magnetic door holder to be inter linked with fire alarm system	Main Contractor to supply unit, provide power & fit	

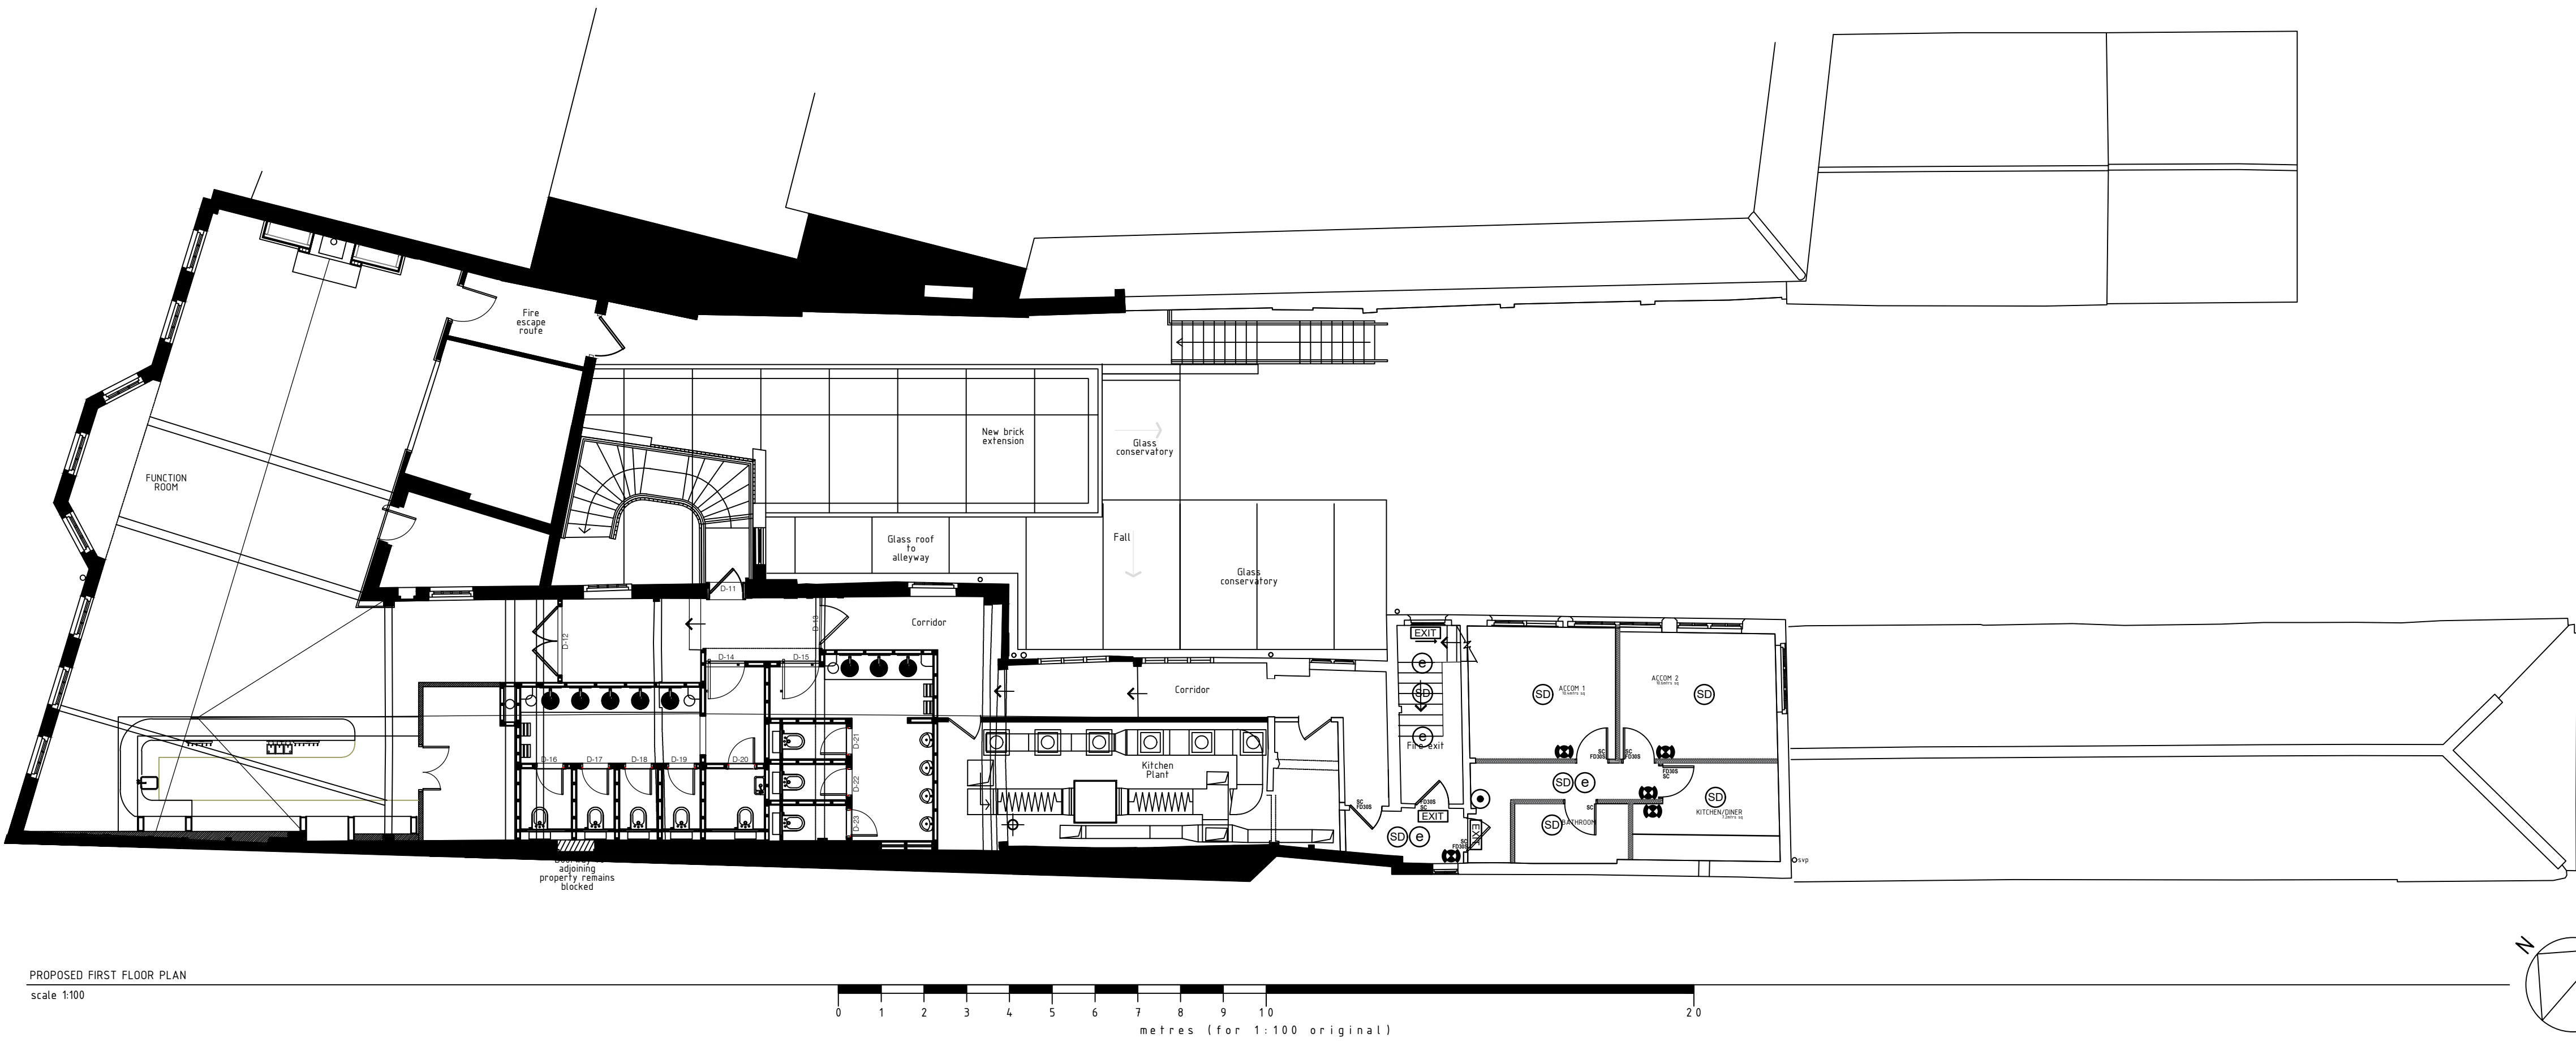

KEEN

AS
mustard
design studio

The Studio, 22 Darley Park Road, Darley Abbey, Derby, DE22 1DB
T 07496 34 00 50 email: studio@keenasmustarddesign.com

Client
MCMULLENS

Project
THE ROSE INN
30 MARKET PLACE
WOKINGHAM, RG40 1AP

Drawing
PROPOSED FIRE STRATEGY PLAN

Scale	Size	Drawn	Date
1:100	A1	DK	12.01.25

Drawing No. **633-05** Rev **A**

© KEEN AS MUSTARD DESIGN STUDIO

- PLANNING ☒
- PRELIMINARY ☐
- TENDER ☐
- CONSTRUCTION ☐
- AS BUILT ☐