
 


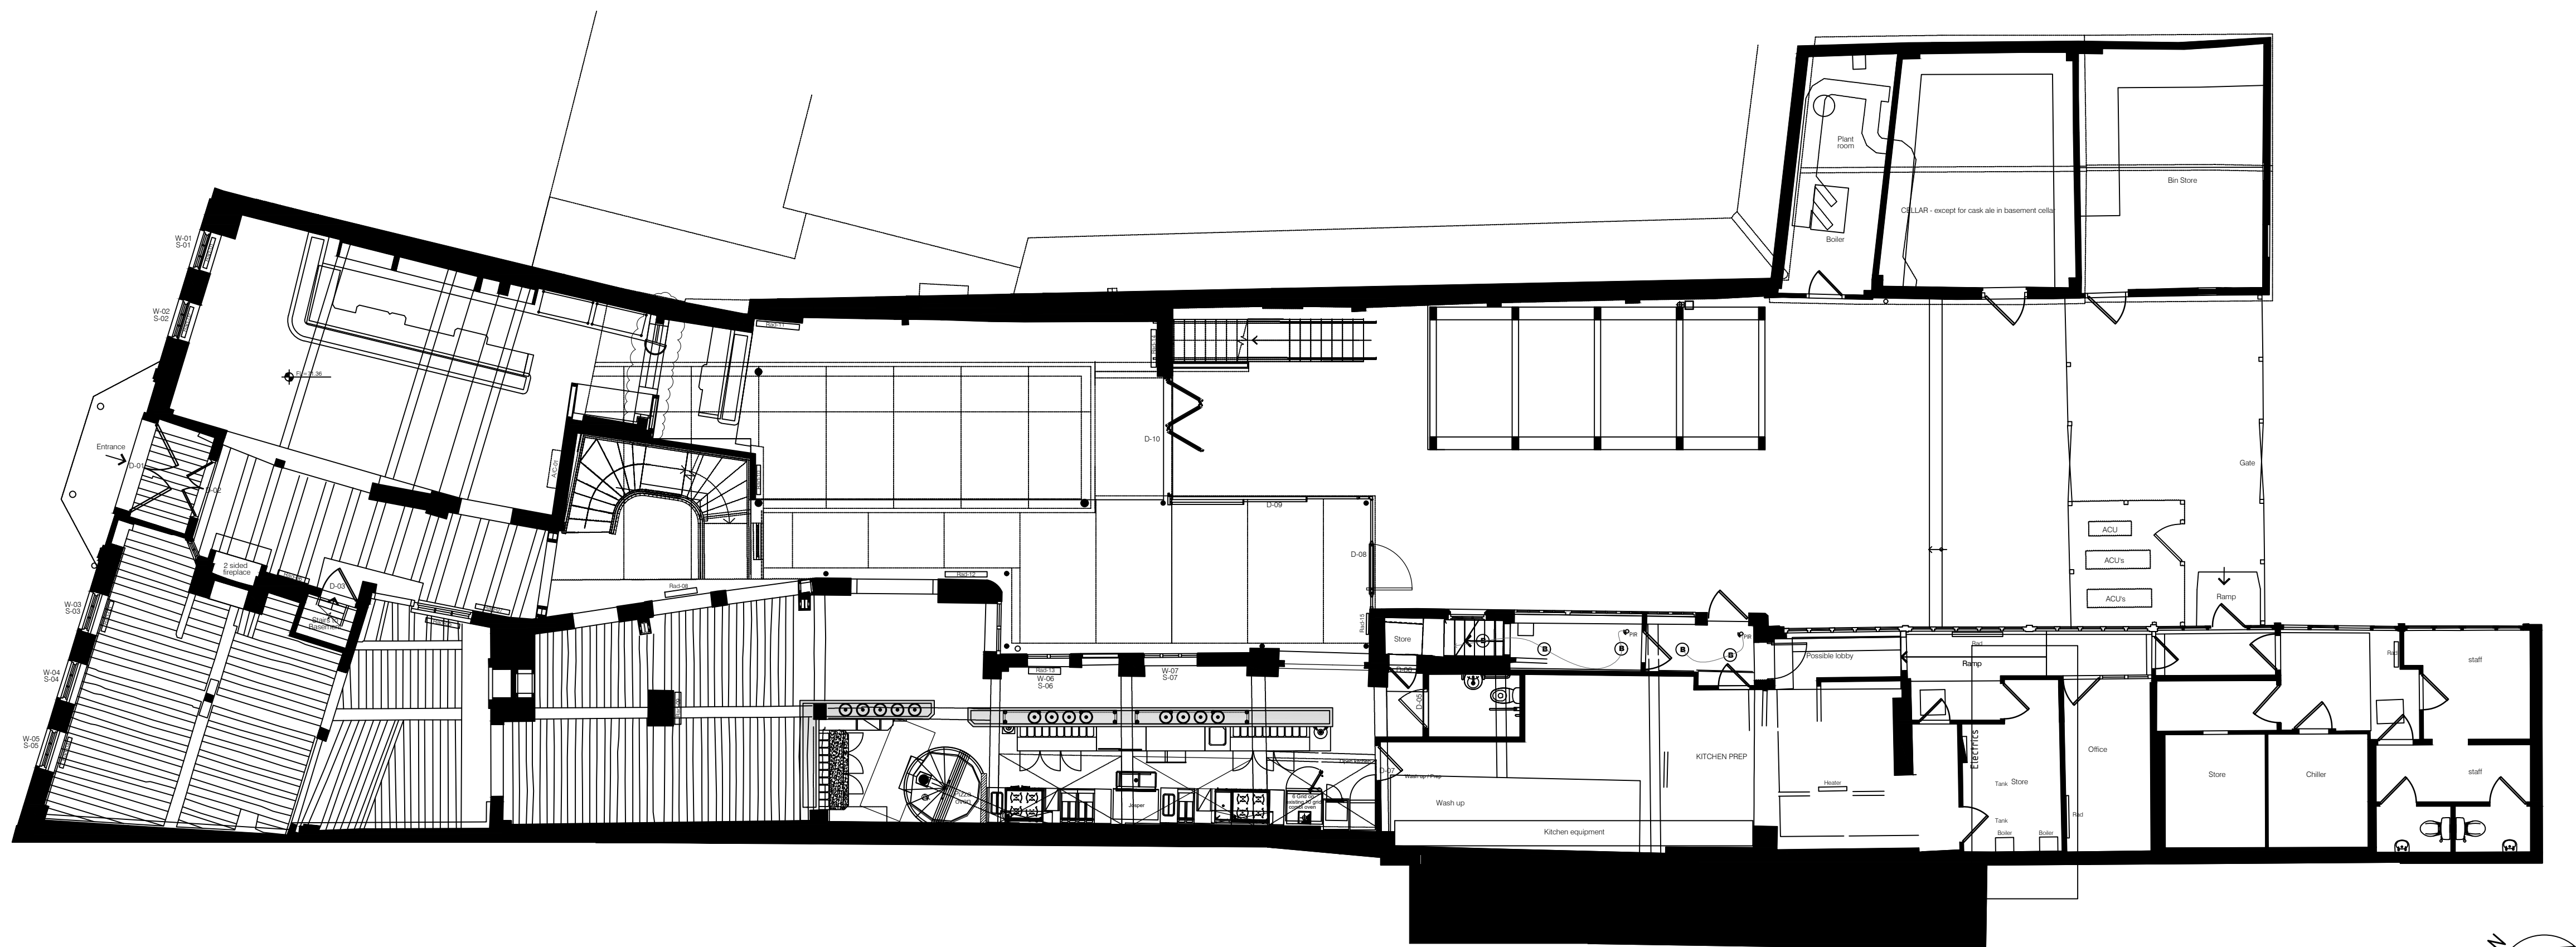


PROPOSED GROUND FLOOR PLAN
scale 1:100




ref	key	description	reference	Q
		new fush fitting ceiling insulated ventilation Warning: open to all fans use control wiring to PR operation	Main Contractor to supply, provide power & fit	
		Heated electric towel radiator point - specific Finished in Chrome	Main Contractor to supply, provide power & fit	

Ref	Key	Description	Reference	Units
		1. See the following description for the 150-151B LITELITE LED work white 74 LED 10' reel.		
		LED light tape 4' x 1/2" or 1" x 1/2" or 2" x 1/2"	Plan Contractor to provide panel & LED light tape	1.0
		LED light tape 4' x 1/2" or 1" x 1/2" or 2" x 1/2"	Plan Contractor to provide panel & LED light tape	1.0
ref	description	reference	Qm
	Single or double A 350 after a short period (about 10-12) minutes - Offsets PFI to be used - Offsets PFI for floor mounted	Non-Captain to supply unit, process power & 50	
	CAT 5 data points OFFED	To be supplied & installed by data centre to 50 data units	
	Signal (x-4 per sec) @ 1000ms PFI to be used - Offsets PFI Non-Captain, after a short 8-10 sec delay to the point (PFI) for debug	To be supplied & installed by data centre to 50 data units	
	IP of IP address (server) / external power	Non-Captain to supply unit, process power & 50	
	1000 base T, ports connected to be used - Offsets PFI to be used - Offsets PFI	Non-Captain to supply unit, process & 50	
	Emergency Phase - Data point only to be used - Offsets PFI	To be supplied & installed by data centre to 50 data units	
	Wi-Fi (802.11n) - Data point only to be used - Offsets PFI	To be supplied & installed by data centre to 50 data units	

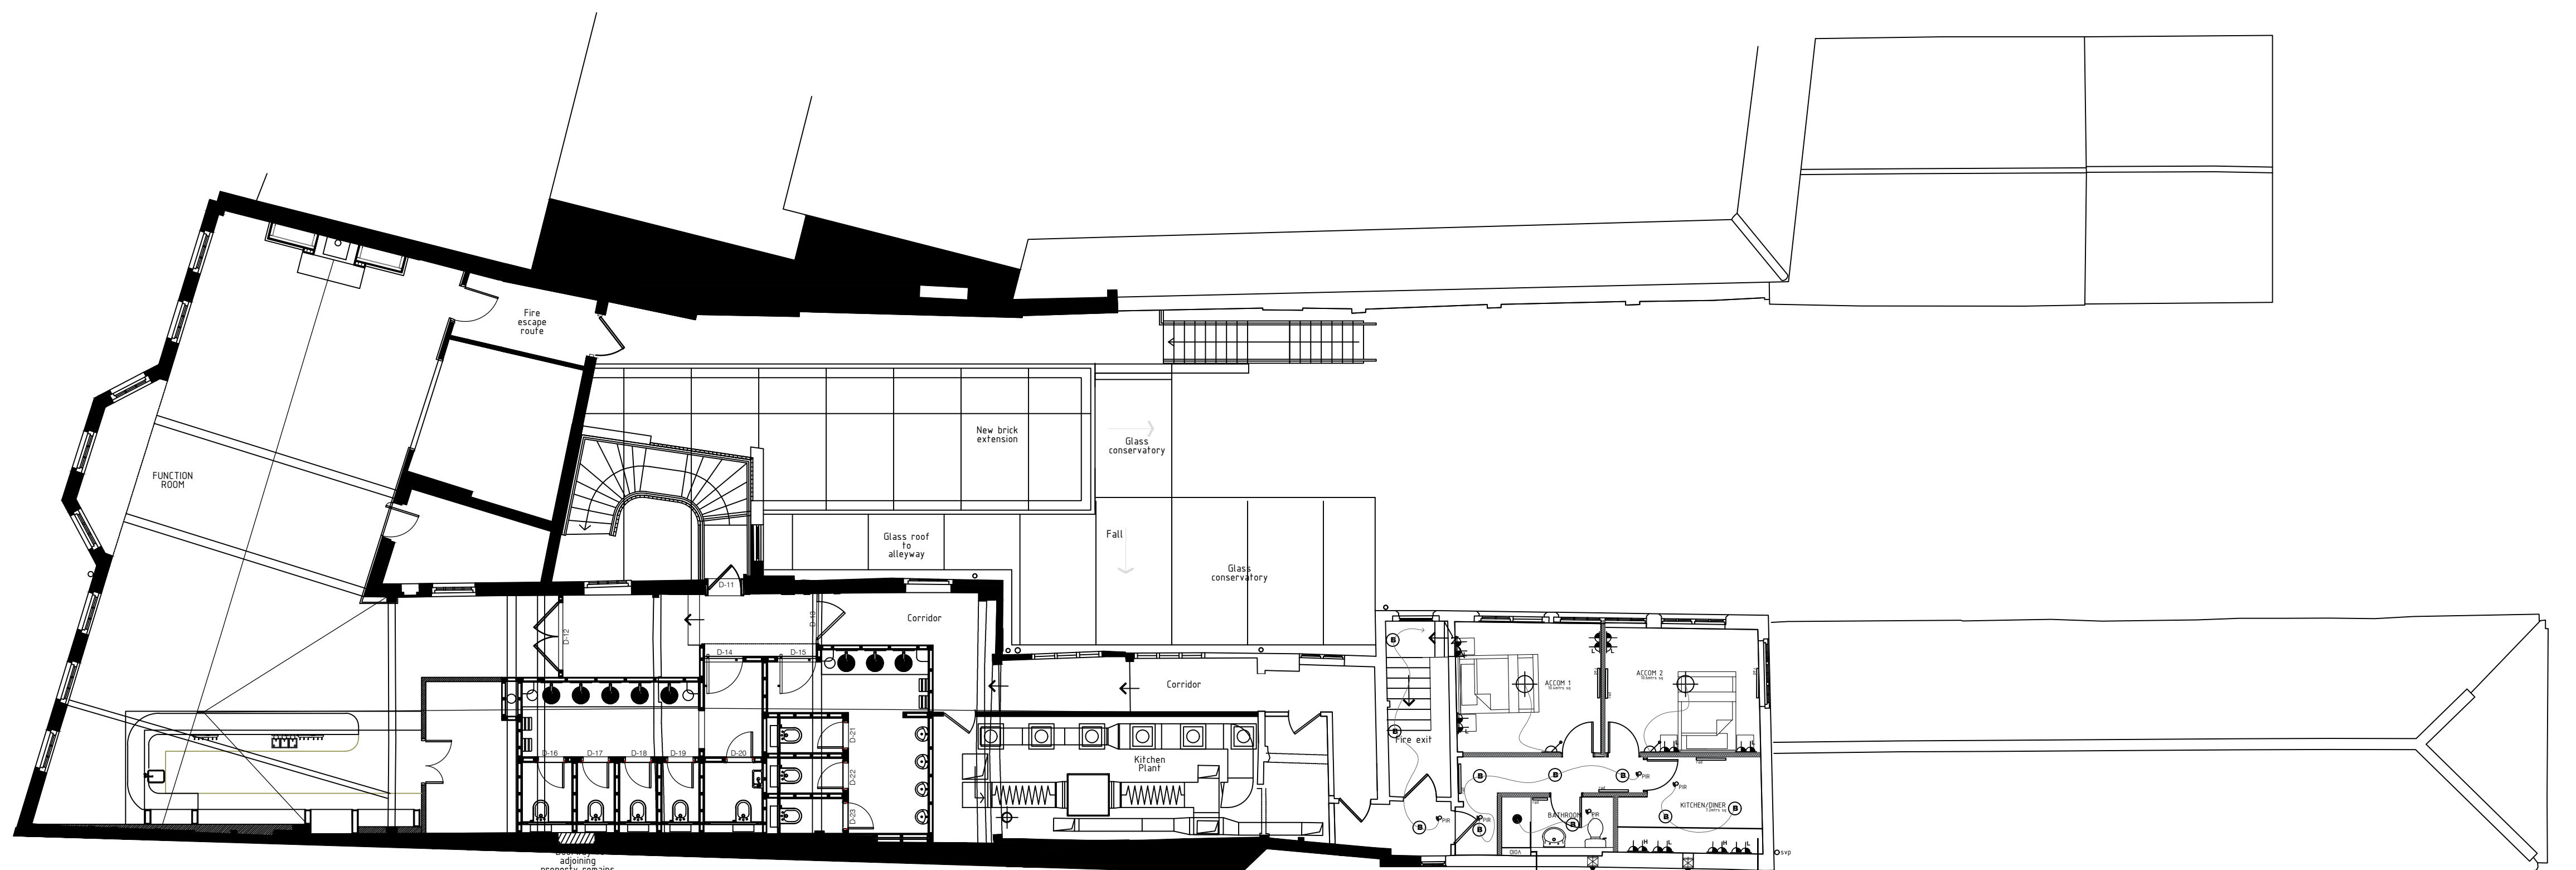

PROPOSED FIRST FLOOR PLAN
scale 1:100

 

- ALLOW TO SUPPLY AND INSTALL NEW MECHANICAL FAN TO NEW BATHROOM AREA
- ALLOW TO SUPPLY AND INSTALL NEW MECHANICAL FAN TO DOMESTIC KITCHEN AREA
- STAND ALONG ELECTRIC OVEN
 - COOKER
 - KETTLE
 - TOASTER
 - MICROWAVE
 - 1NO 13AMP FUSED SPIUR FOR KITCHEN VENT HOOD

PLANNING ☒

PRELIMINARY ☐

TENDER ☐

CONSTRUCTION ☐

AS BUILT ☐

KEEN
AS mustard
design studio

The Studio, 22 Darley Park Road, Darley Abbey, Derby. DE22 1DB
T 07496 34 00 50 email:studio@keenasmustarddesign.com

Client
MCMULLEN

Project
THE ROSE INN
30 MARKET PLACE
WOKINGHAM. RG40 1AP

Drawing
PROPOSED LIGHTING AND SMALL POWER
PLANS

Drawing No.	Rev
633-08	A

Scale	Size	Drawn	Date
1:100	A1	DK	12.01.25

ALL DIMENSIONS, SETTING OUT AND LEVELS MUST BE CHECKED ON SITE AND NOT
SCALED OFF THIS DRAWING BEFORE ORDERING AND STARTING WORK ON SITE

© KEEN AS MUSTARD DESIGN STUDIO