



Chimney and external structure shown, titleblock updated		AW	13/10/25
Rev:	Description:	By:	Date:

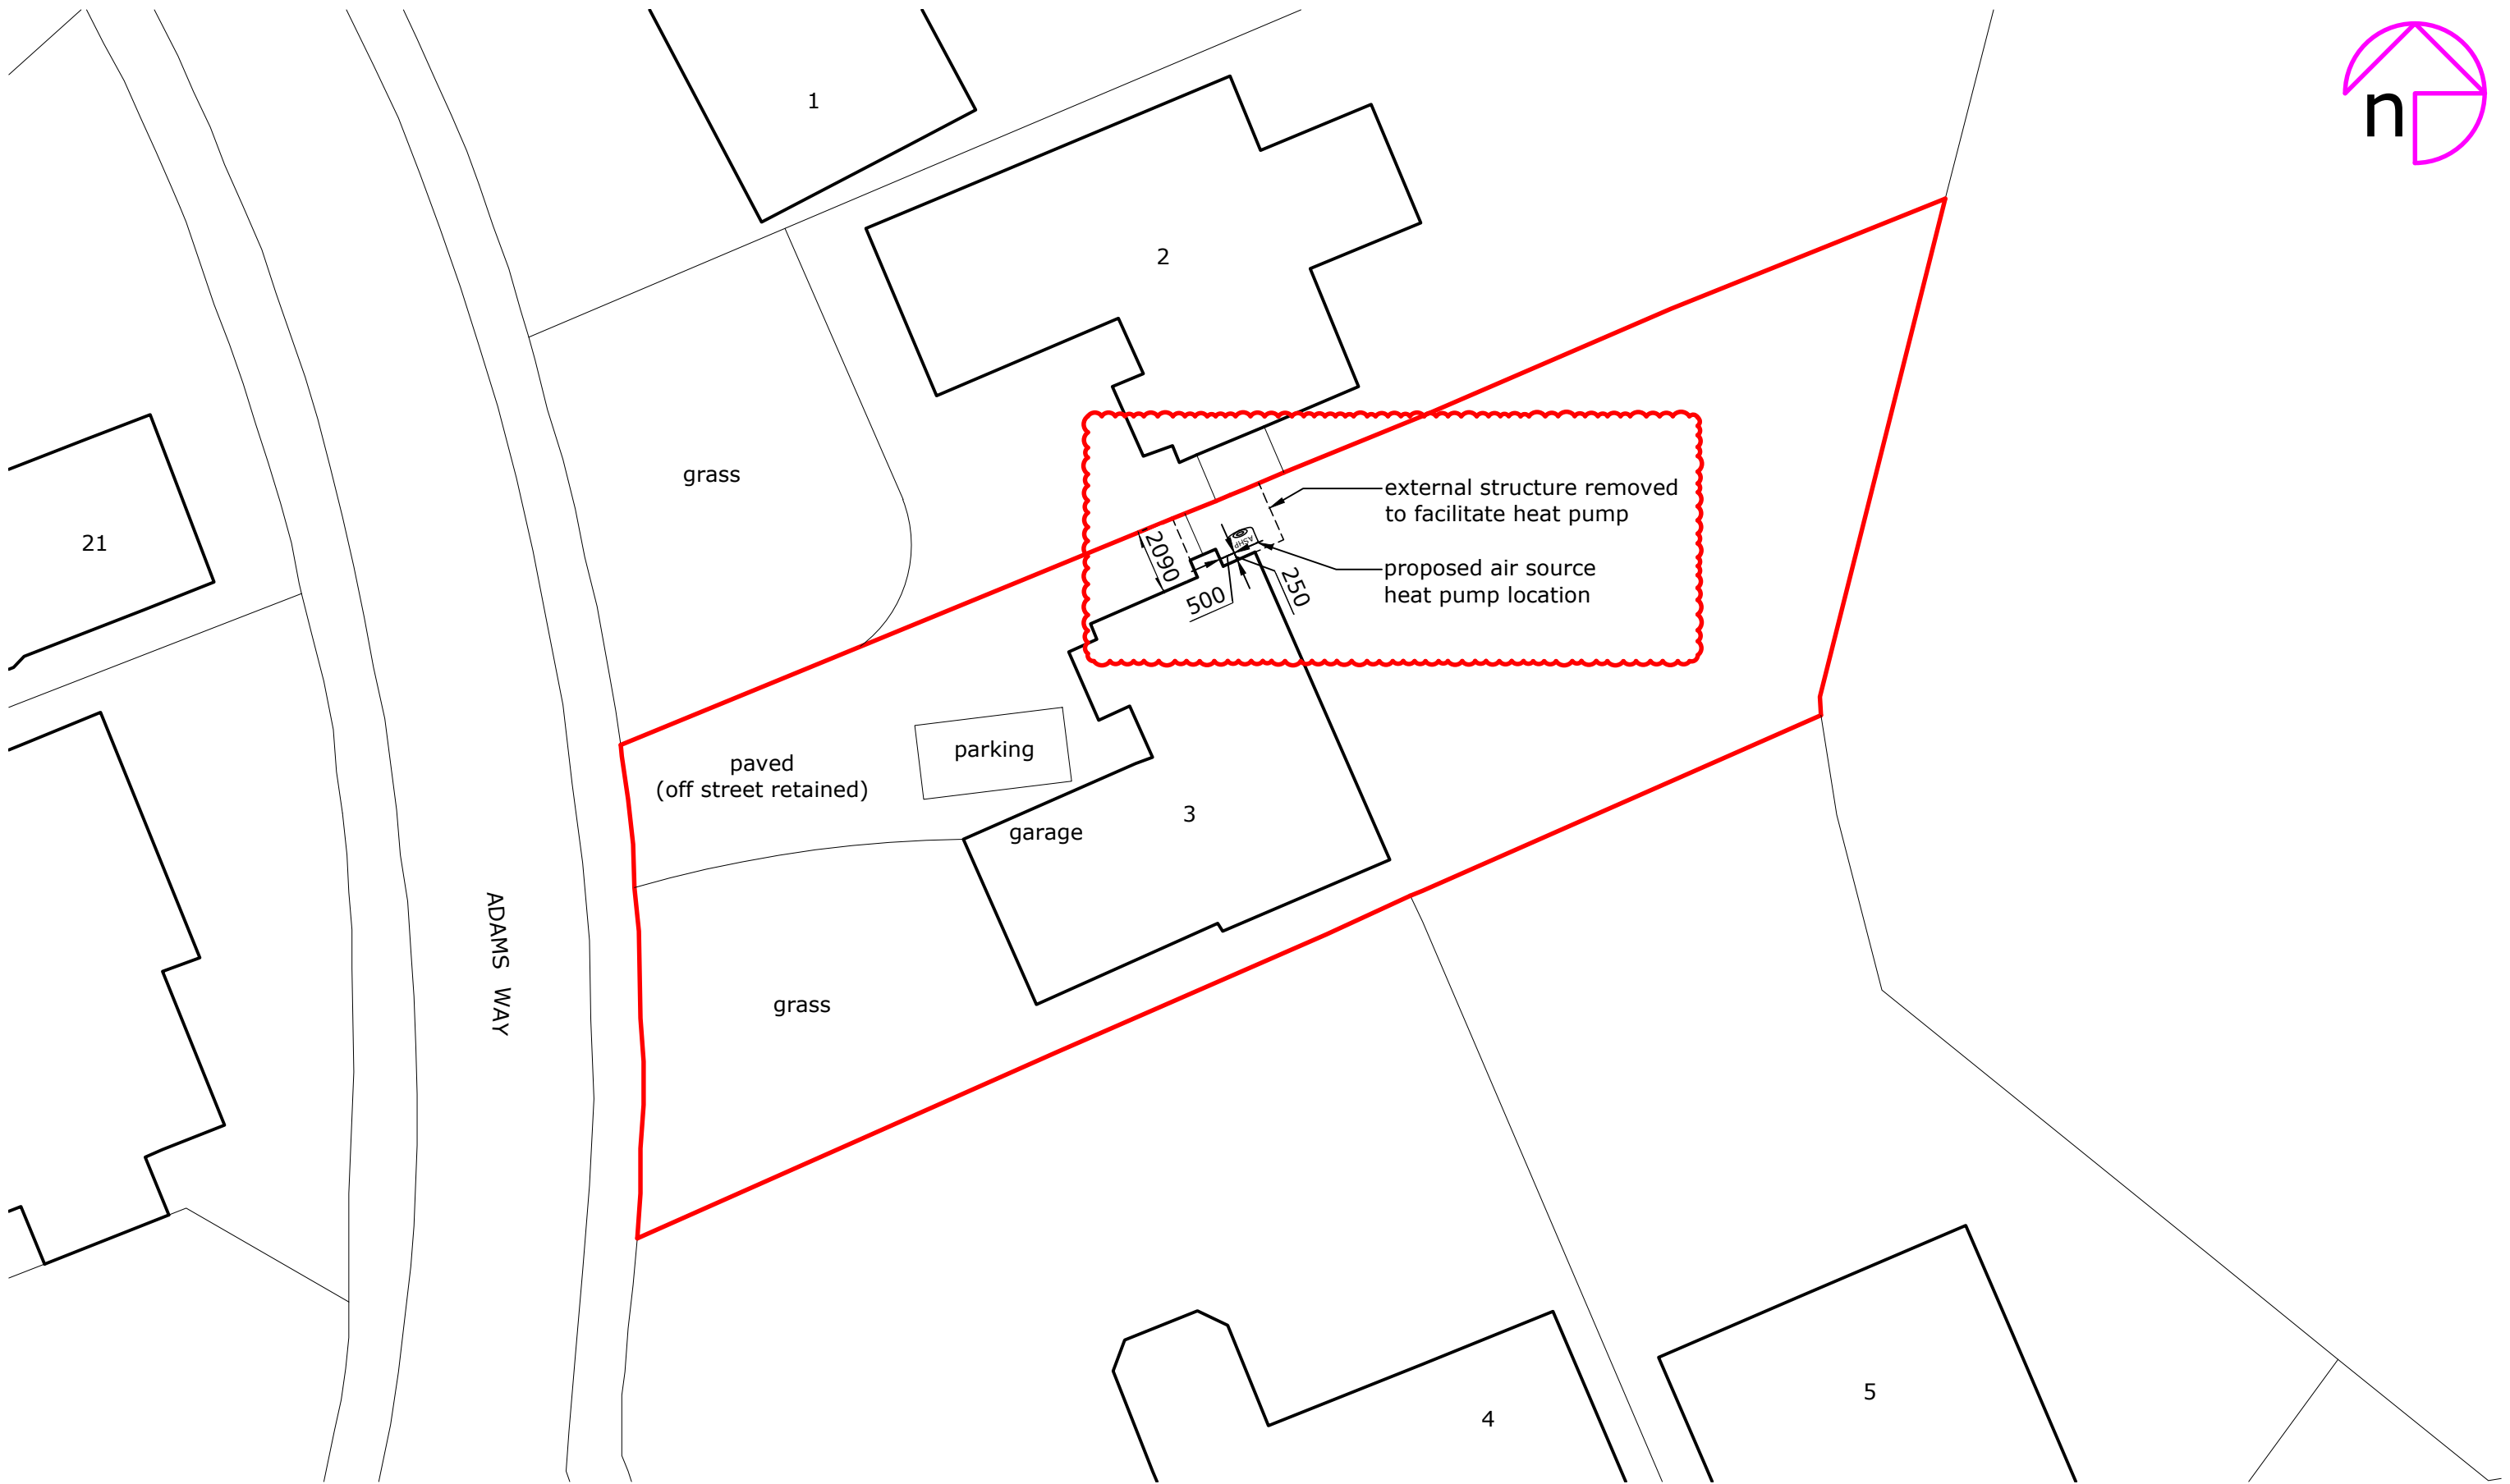

octopusenergy
services

Approved by:

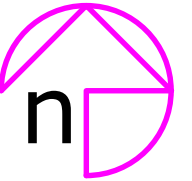

Client/Project: Raymond Barclay, 3, Adams Way, Earley, RG6 5UT	Project status: PLANNING (installation of air source heat pump)
	Drawing title: Site plan as proposed

Scale: 1:200	Paper Size: A3	Drawn: A Walton	Checked: ...
Project ID: J-8A751857	Drawing No: 03	Revision:	Date: 29.09.2025