

 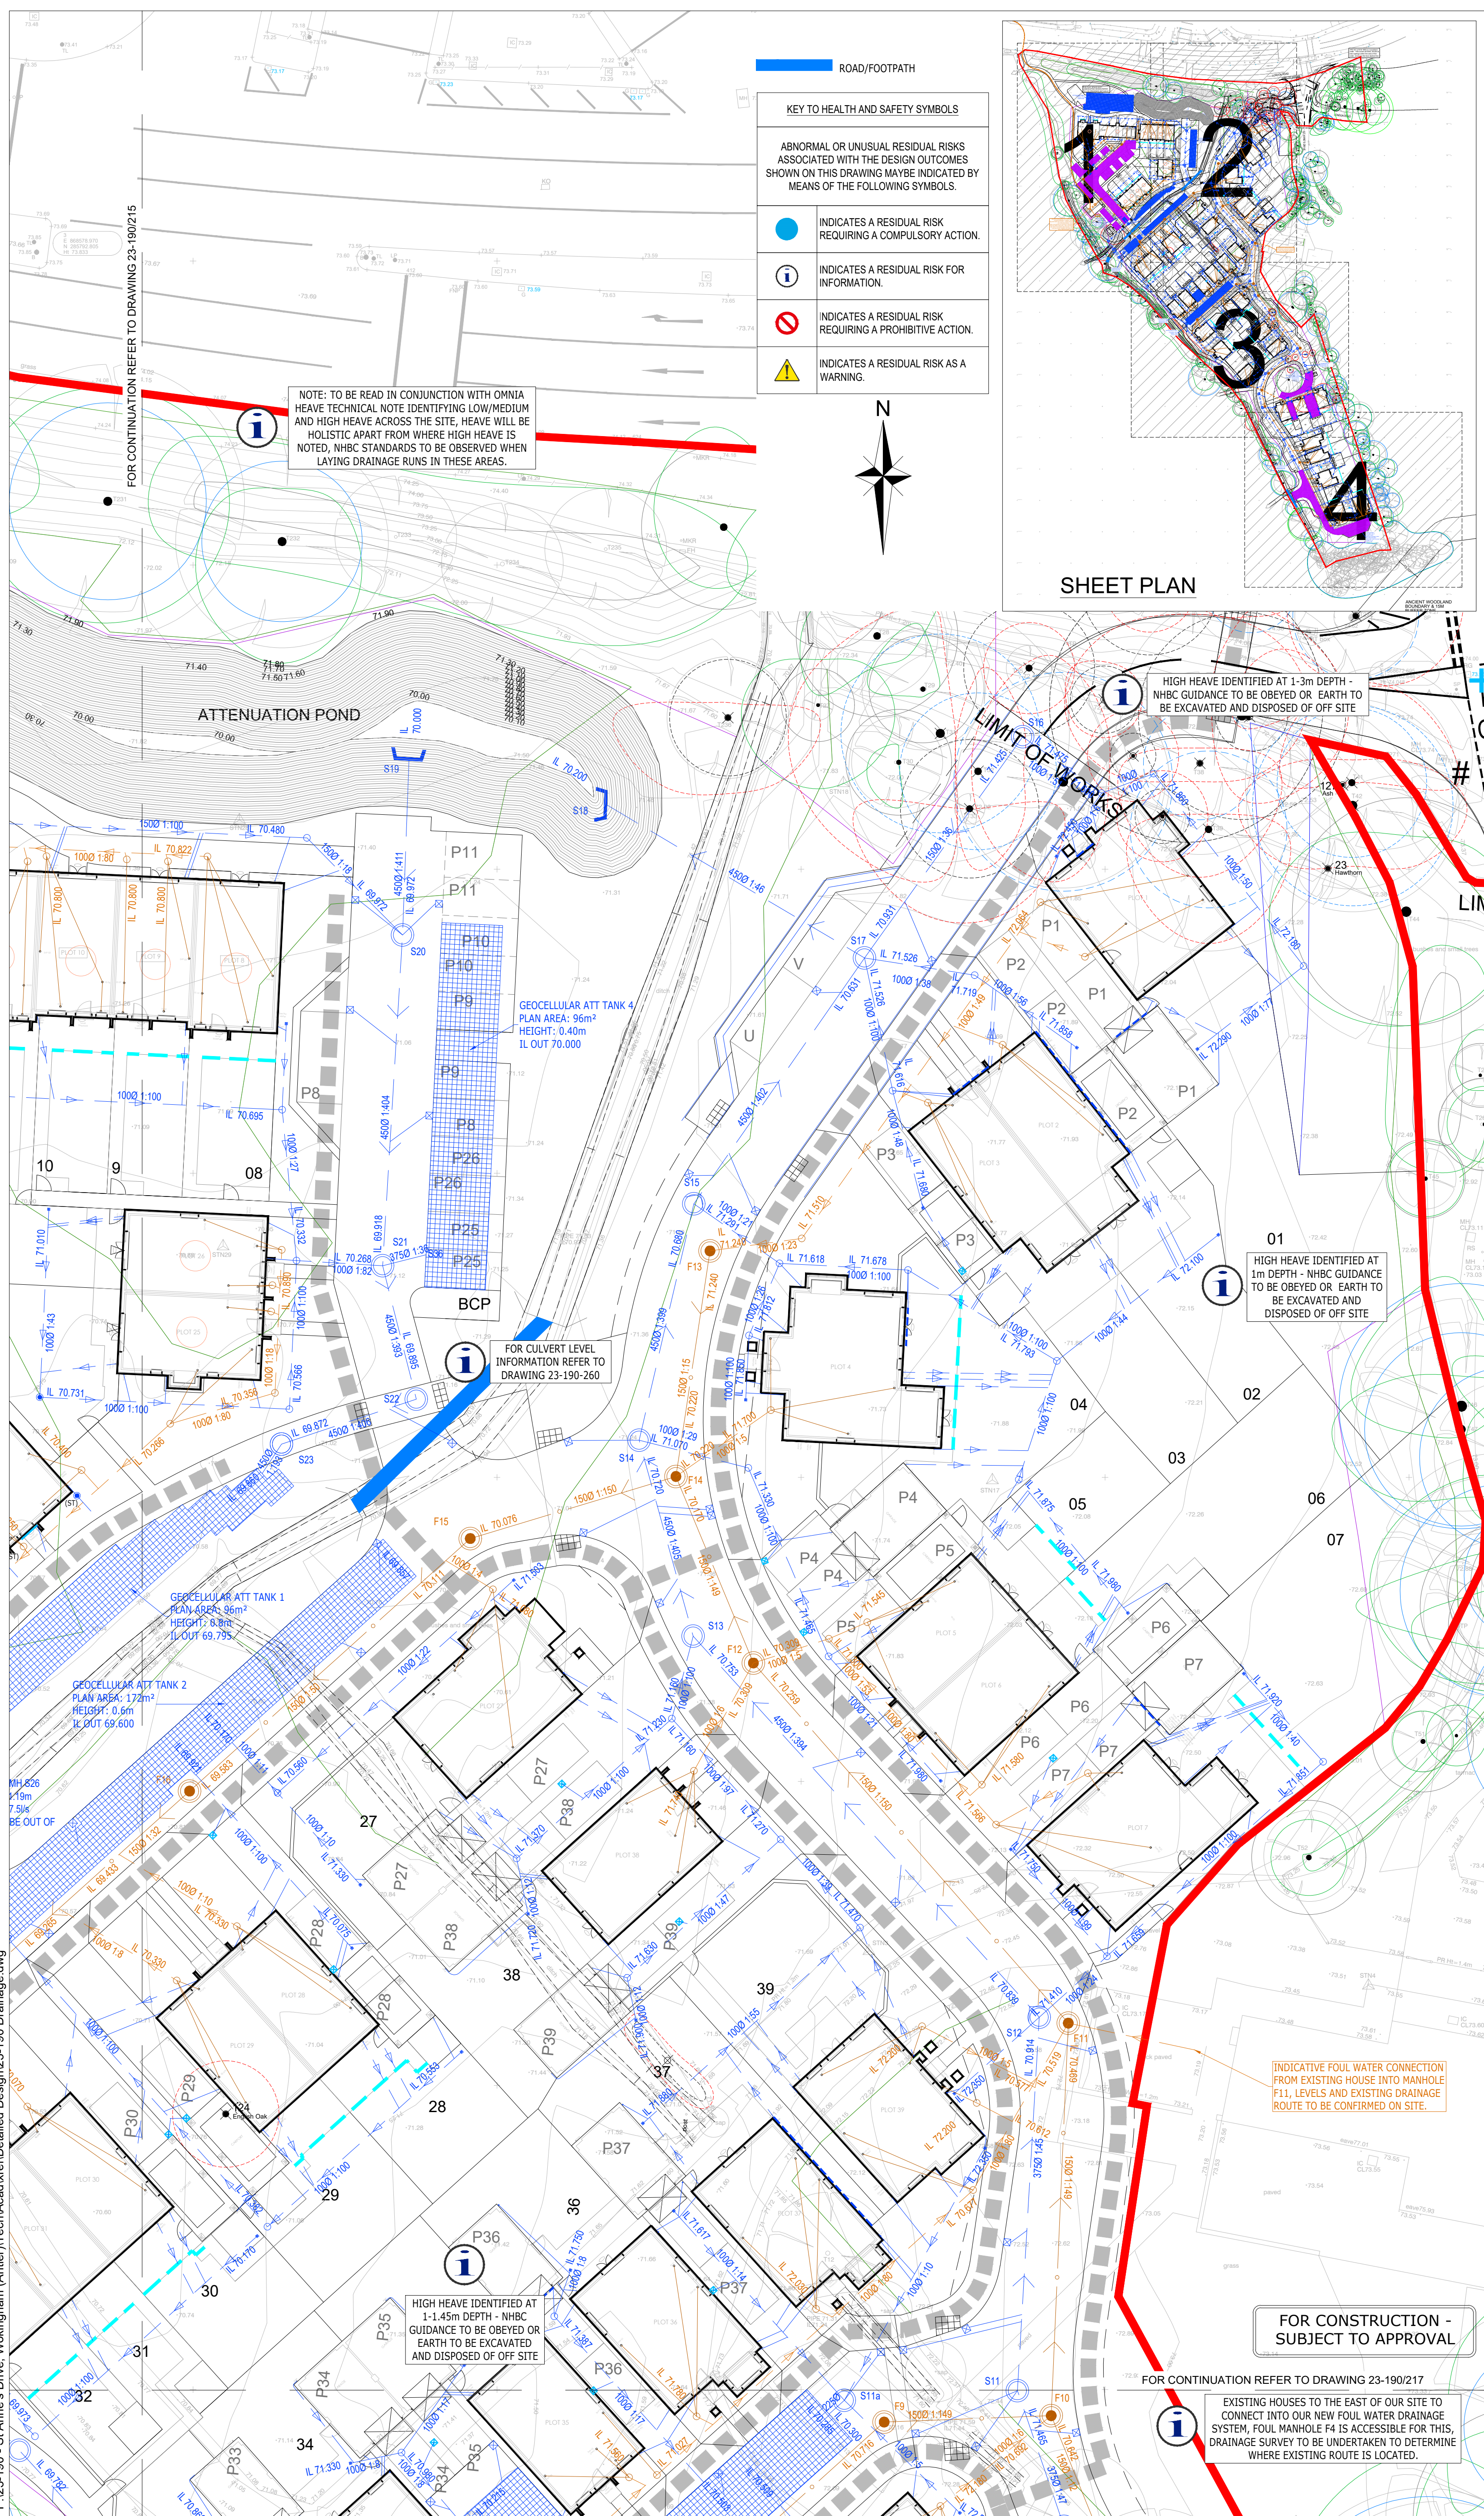


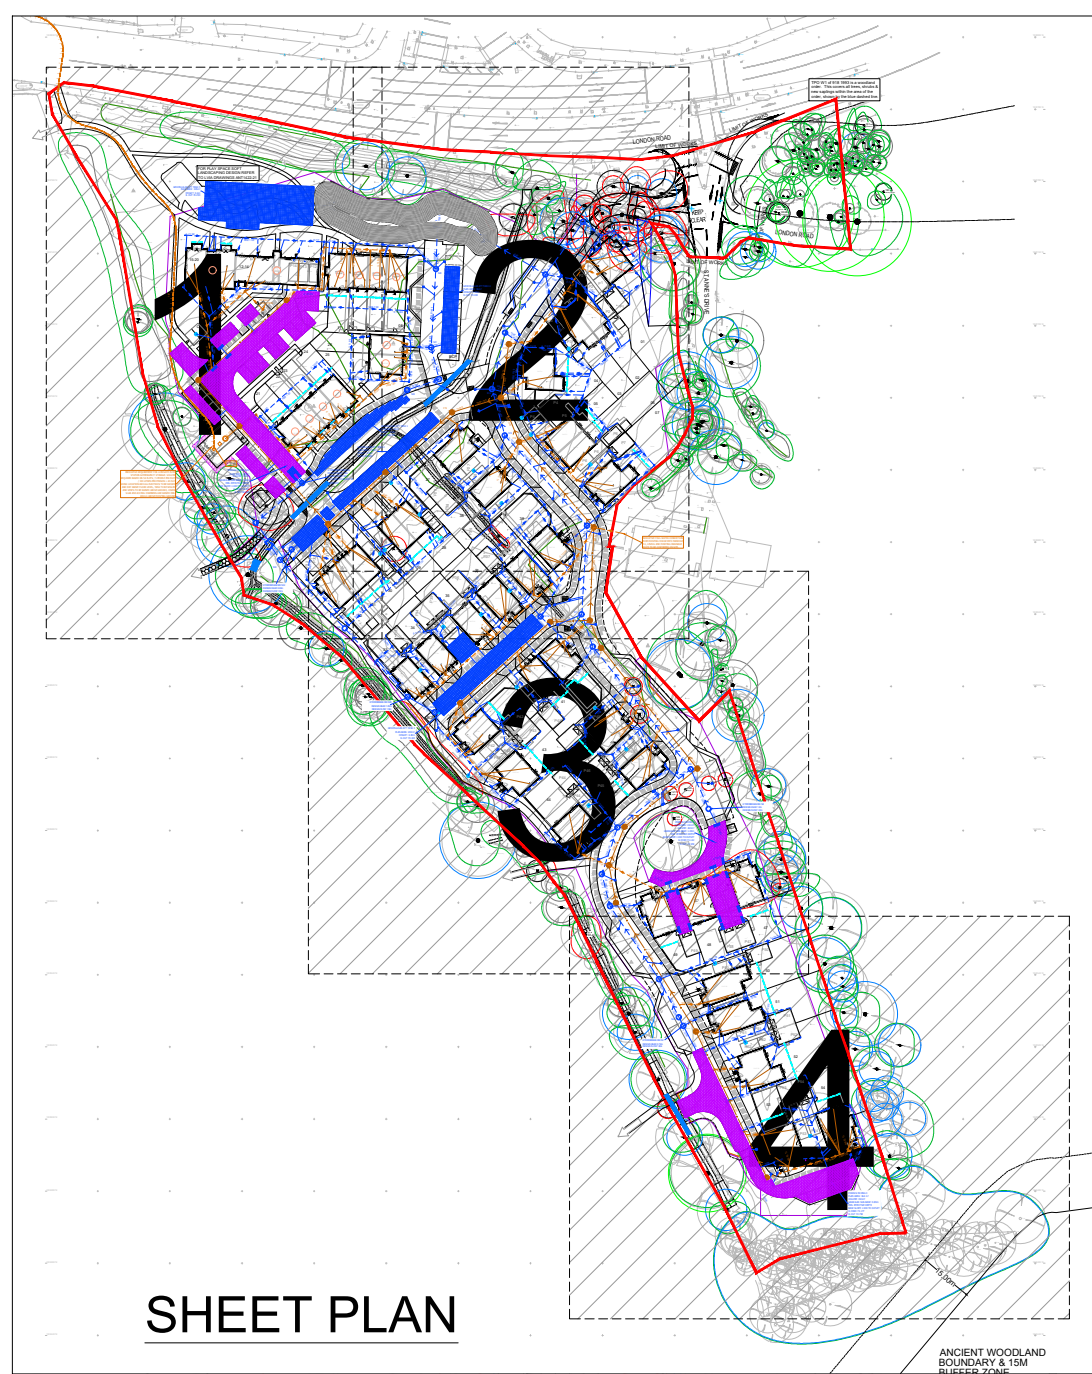

ROAD/FOOTPATH	
KEY TO HEALTH AND SAFETY SYMBOLS	
ABNORMAL OR UNUSUAL RESIDUAL RISKS ASSOCIATED WITH THE DESIGN OUTCOMES SHOWN ON THIS DRAWING MAYBE INDICATED BY MEANS OF THE FOLLOWING SYMBOLS.	
	INDICATES A RESIDUAL RISK REQUIRING A COMPULSORY ACTION.
	INDICATES A RESIDUAL RISK FOR INFORMATION.
	INDICATES A RESIDUAL RISK REQUIRING A PROHIBITIVE ACTION.
	INDICATES A RESIDUAL RISK AS A WARNING.



NOTES

- | | |
|---|---|
|  | SITE BOUNDARY |
|  | EXISTING PUBLIC Foul WATER SEWER |
|  | Foul WATER HIGHWAY SEWER |
|  | SURFACE WATER HIGHWAY SEWER |
|  | FWMH - PRIVATE FOUL WATER MANHOLE (PCC RINGS) |
|  | FW-TYPE3 - PRIVATE FOUL WATER MH - MIN 0.60m DIA |
|  | FW-IC3 - PRIVATE FOUL WATER INSPECTION CHAMBER - MIN 0.45m DIA |
|  | SWMH - PRIVATE SURFACE WATER MANHOLE (PCC RINGS) |
|  | SW-IC3 - PRIVATE SURFACE WATER INSPECTION CHAMBER - MIN 0.45m DIA |
|  | SILT TRAP |
|  | ROAD GULLY |
|  | YARD GULLY |
|  | RODDING EYE |
|  | DIFFUSER UNIT BETWEEN PIPED DRAINAGE AND PERMEABLE PAVING |
|  | PRIVATE FOUL WATER DRAINAGE |
|  | PRIVATE SURFACE WATER DRAINAGE |
|  | FOUL WATER LATERAL |
|  | PROPOSED PRIVATE CHANNEL BY ACO OR SIMILAR APPROVED |
|  | PRIVATE SURFACE WATER FILTER DRAIN - PERFORATED PIPE Laid FLAT DISCHARGING TO GROUND NOT TO BE CONNECTED TO THE SW SYSTEM |
|  | THRESHOLD SLOT DRAIN TO MANUFACTURERS SPECIFICATION |
|  | Foul WATER RISING MAIN |
|  | PERMEABLE PAVING |
|  | PERFORATED UNDER-DRAIN |
|  | LINED POROUS PAVING WITH 600mm (OR AS NOTED) MIN. EFFECTIVE DEPTH |
|  | ATTENUATION TANK (GEOCELLULAR UNITS) |
|  | INDICATIVE SERVICE CORRIDOR - REFER TO SERVICES DRAWINGS FOR SERVICE LOCATIONS |
|  | 1m PROTECTION ZONE AROUND PUMP STATION |
|  | ROOTLOCK HEADWALL - TYPE TO BE AGREED WITH OWC |
|  | CULVERT AND HEADWALL CROSSING ROAD/FOOTPATH |

 **ODYSSEY**

Unit 1 Pucknall Farm
Dores Lane
Brassfield
Romsey SO51 0QJ

Telephone: 01794 537980
Fax: 01256 331134
E: info@odysseyconsult.co.uk
W: www.odysseyconsult.co.uk

Job Title

Drawing Title

DRAINAGE LAYOUT
SHEET 2 OF 4

Scale 1:200 @A1	Date JAN 24	Designed LG	
Drawn LG	Checked SW	Approved SW	
Job No 23-190	Drawing No 23-190-216		Rev G