

GENERAL NOTES :-

ALL LEVELS ARE IN METRES RELATED TO AN ASSUMED DATUM LOCATED ON PK NAIL ST01
AS SHOWN ON DRAWING 37392/1. (value 100.00m).

THIS DRAWING HAS BEEN PRODUCED WITH A PLOT SCALE ACCURACY OF 1:50

BUILDING SURVEY KEY :-

② = room height
 1/3 = floor boards
 p = plaster damer
 a/b = air brick
 a/c = arch head height
 b/c = arch depth
 b/c = brick - brick
 c/c = corner
 c/c = cable wire
 d/c = door height
 d/c = door depth
 e/m/r = electricity metre
 e/c = electricity cable
 f/b = fire place
 f/c = floor level
 f/c = floor to ceiling
 f/m/r = gas metre
 h/c = hand dryer
 h/c = hot water tank
 i/c = inspection cover
 i/c = inside level
 m/h = movable cover
 m/h = entrance survey bench mark
 u/s/m = survey line
 u/s/m = survey line
 r = roof light
 w/c = water pipe
 w/c = wall chomber
 w/c = wall height
 w/c = arch springing point height
 w/c = window
 w/c = suspended ceiling
 w/c = wall vent pipe
 w/c = door level
 w/c = electricity bench mark
 t/c = threshold level
 t/c = threshold
 t/c = top of pipe
 t/c = top of floor
 u/c = underside height
 u/c = unable to sight
 v/c = vent pipe
 w/c = water running
 w/c = water filter chomber
 w/c = waste pipe

SERVICES KEY :

	stop light		alarm keypad
	light		intercom
	wall light		speaker
	emergency light		control
	bullet		projector
	pull cord		closed circuit
	ventilator		sensor
	light switch		network port
	fused switch		closed alarm
	isolator switch		alarm detector
	circuit switch		heat detector
	fuse		tamper
	single socket		no alarm
	double socket		water the extinguisher
	cable lock/alarm		water the extinguisher
	alarm		water the extinguisher
	alarm control panel		alarm control panel
	emergency door		alarm control panel



MIDLAND SURVEY LTD

HEAD OFFICE
Cromwell House, Westfield Road, Southam, Warwickshire, CV47 0JH.
Tel: 01926 810511 Fax 01926 810512
E-Mail: mail@midlandsurvey.co.uk
www.midlandsurvey.co.uk

Client	JSA ARCHITECTS
--------	----------------

Project STOKES FARM, WOKINGHAM, RG40 5PR

Title	GROUND FLOOR PLAN AND ROOF PLAN
-------	---------------------------------

Date	NOVEMBER 2020	Revisions
------	---------------	-----------

Score	1:50:40
-------	---------

Dwg No 37392/2

Surveyor J.M.P.

TOPOGRAPHICAL (LAND) SURVEYORS / UTILITY SURVEYORS
BUILDING MEASUREMENT SURVEYORS / 3D LASER SCANNING

 INTERNATIONAL LABOUR ORGANIZATION • UNITED NATIONS • THE SURVEY

© Copyright Midland Survey Ltd. Reproduction of this information is prohibited without written authorisation from Midland Survey Ltd.

ALL LEVELS ARE IN METRES RELATED TO AN ASSUMED DATUM LOCATED ON PK NAIL ST01
AS SHOWN ON DRAWING 37322/1. (value 100.00m).

THIS DRAWING HAS BEEN PRODUCED WITH A PLOT SCALE ACCURACY OF 1:50

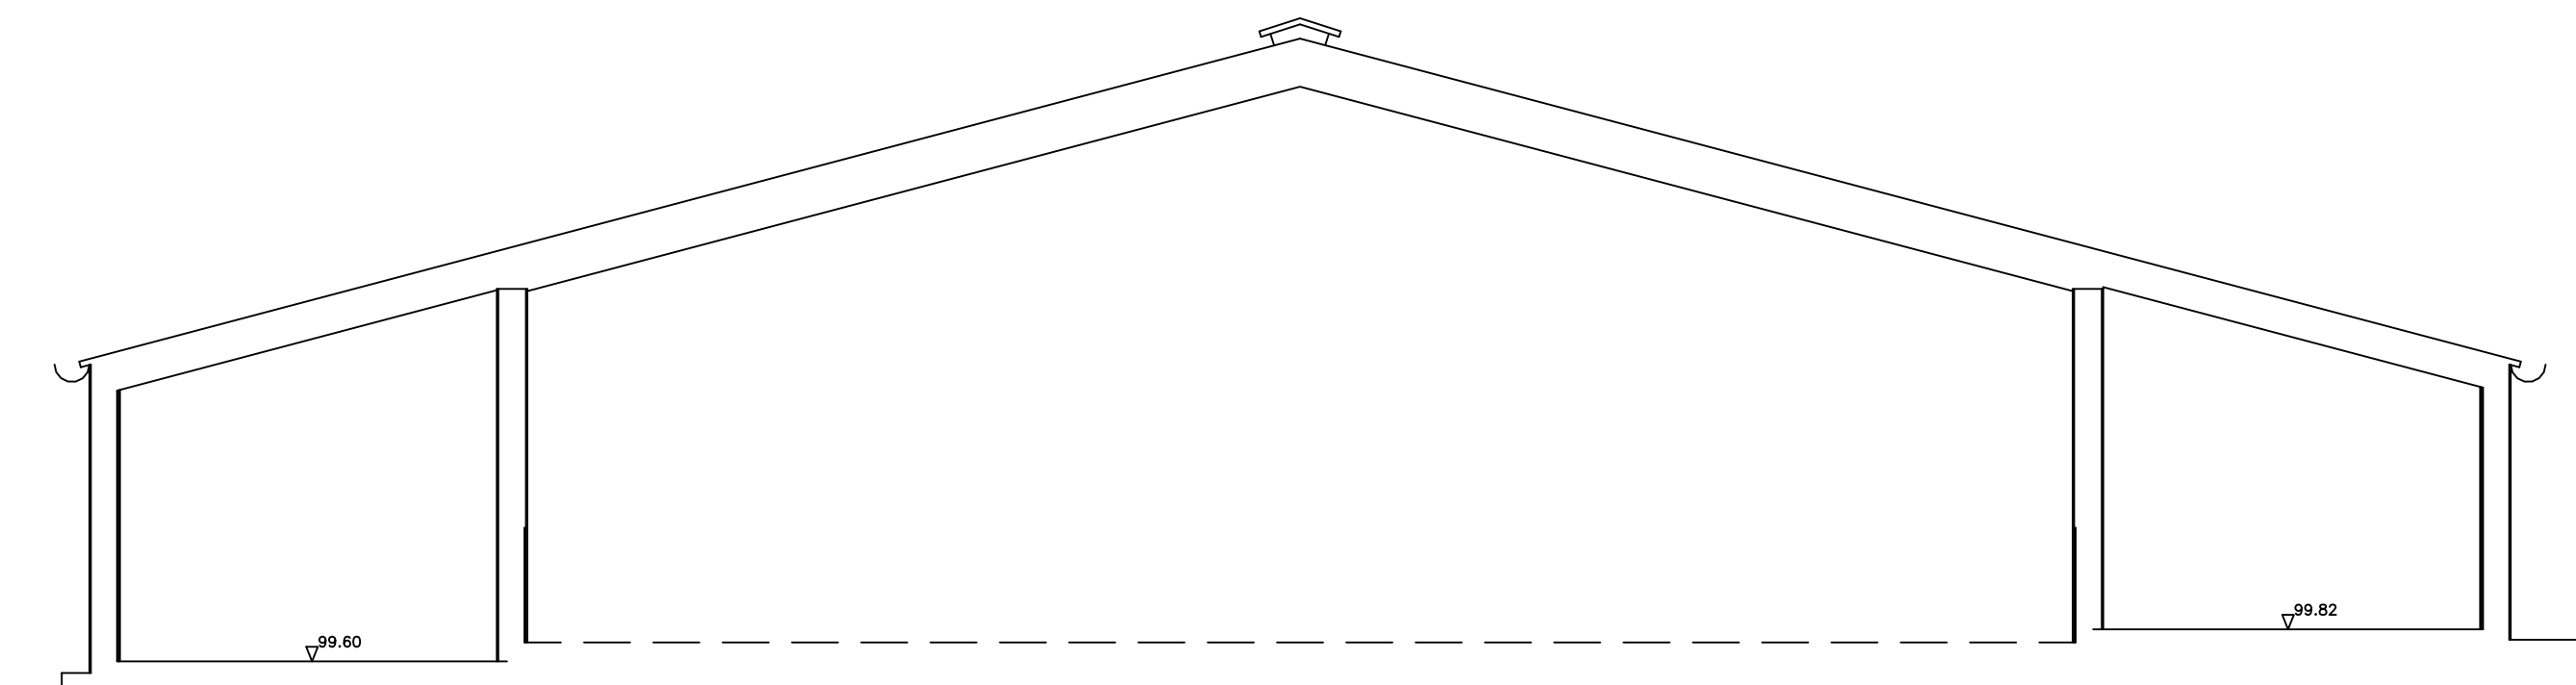
BUILDING SURVEY KEY :-

12 - room height
1/2 - floor boards
- pipe diameter
a/b - on brick
a/b - on ash
a/b - arch head timber
a/b - arch head stone
bk - brick
c/c - concrete
c/c - copper liner
c/c - copper roof
d/b - door height
d/c - door width
e/mtr - electricity metre
e/mtr - electricity
f/p - fire place
f/p - floor head height
f - floor level
f - floor all height
g/mtr - gas metre
h - hand over
h - hand over

het - hot water tank
i - inspection cover
ins - insulation
m/s - manhole cover
m/s - manhole
m/s - survey bench mark
m/s - gully ties
n - nail
n - roof light
n - roof light
n - roof water pipe
s/s - ss steel chamber
s/s - ss floor all height
s/s - arch springing point height
s/s - arch springing
s/s - suspended ceiling
s/s - vent pipe
t/rd - treadboard level rail
t/rd - temporary bench mark
t - treadboard level
t - top of core
t/p - top of pipe
t/p - top of frame
t/p - upside height
t/p - unable to lift
v - vent pipe
w - water
w/s - water filter
w/s - water flood chamber
w/s - waste pipe

DRICES KEY :

	mist light		alarm keypad
	night light		intercom
	night light with bell		control panel
	night light with bell and star		projector
	pull cord		closed circuit
	webmaster		sensor
	light switch		network panel
	fused switch		cable panel
	indicator switch		smoke detector
	circuit switch		heat detector
	fire alarm		alarm station
	fire control		fire alarm
	single outlet		fire extinguisher
	cable outlet		fire blanket
	switch outlet with switch		fire alarm
	fire alarm		fire alarm
	fire alarm		fire alarm
Return 90.02m

SECTION B - B



Output 18.2Cov

SECTION A - A



HEAD OFFICE

Fromwell House, Westfield Road, Southern, Warwickshire, CV47 0JH.
Tel: 01926 810811 Fax 01926 810812
E-Mail: mail@midlandsurvey.co.uk
www.midlandsurvey.co.uk

Client JSA ARCHITECTS

Project STOKES FARM, WOKINGHAM, RG40 5PR

Title SECTIONS

Date _____

scale 1

Year	No.	%
1990	10	100
1991	10	100
1992	10	100
2100	10	100

It is well understood that

Checked ☐

1999, 2000, 2001, 2002, 2003, 2004

BUILDING

CONSTRUCTION HEALTH & SAFETY

© Copyright 1999

ALL LEVELS ARE IN METRES RELATED TO AN ASSUMED DATUM LOCATED ON PK NAIL ST01 AS SHOWN ON DRAWING 37322/1. (value 100.00m).


THIS DRAWING HAS BEEN PRODUCED WITH A PLOT SCALE ACCURACY OF 1:50

BUILDING SURVEY KEY :-

[illegible]


SERVICES KEY :—

	stop light		alarm klipped
	left light		intercom
	emergency light		alarm control panel
	spot light		projector
	put cord		closed circuit
	ventilator		sensor
	switch		remotes point
	light switch		cable door
	fused switch		smoke detector
	isolator switch		fire detector
	control switch		five alarm train
	fuse		fire extinguisher
	blender socket		fire sprinkler
	single socket		fire blanket
	double socket		fire fighting equipment
	automatic fire detection device		fire extinguisher
	fireproofed		fire extinguisher
	card access point (pinhole) card		fire extinguisher
	emergency door release		fire extinguisher

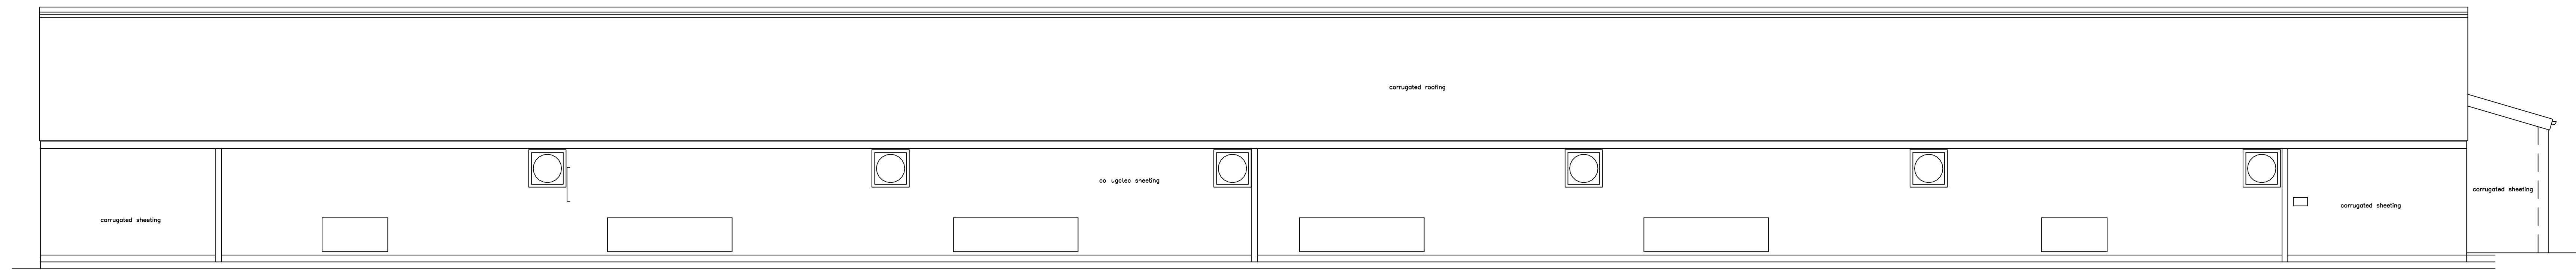


Datum 88.20m

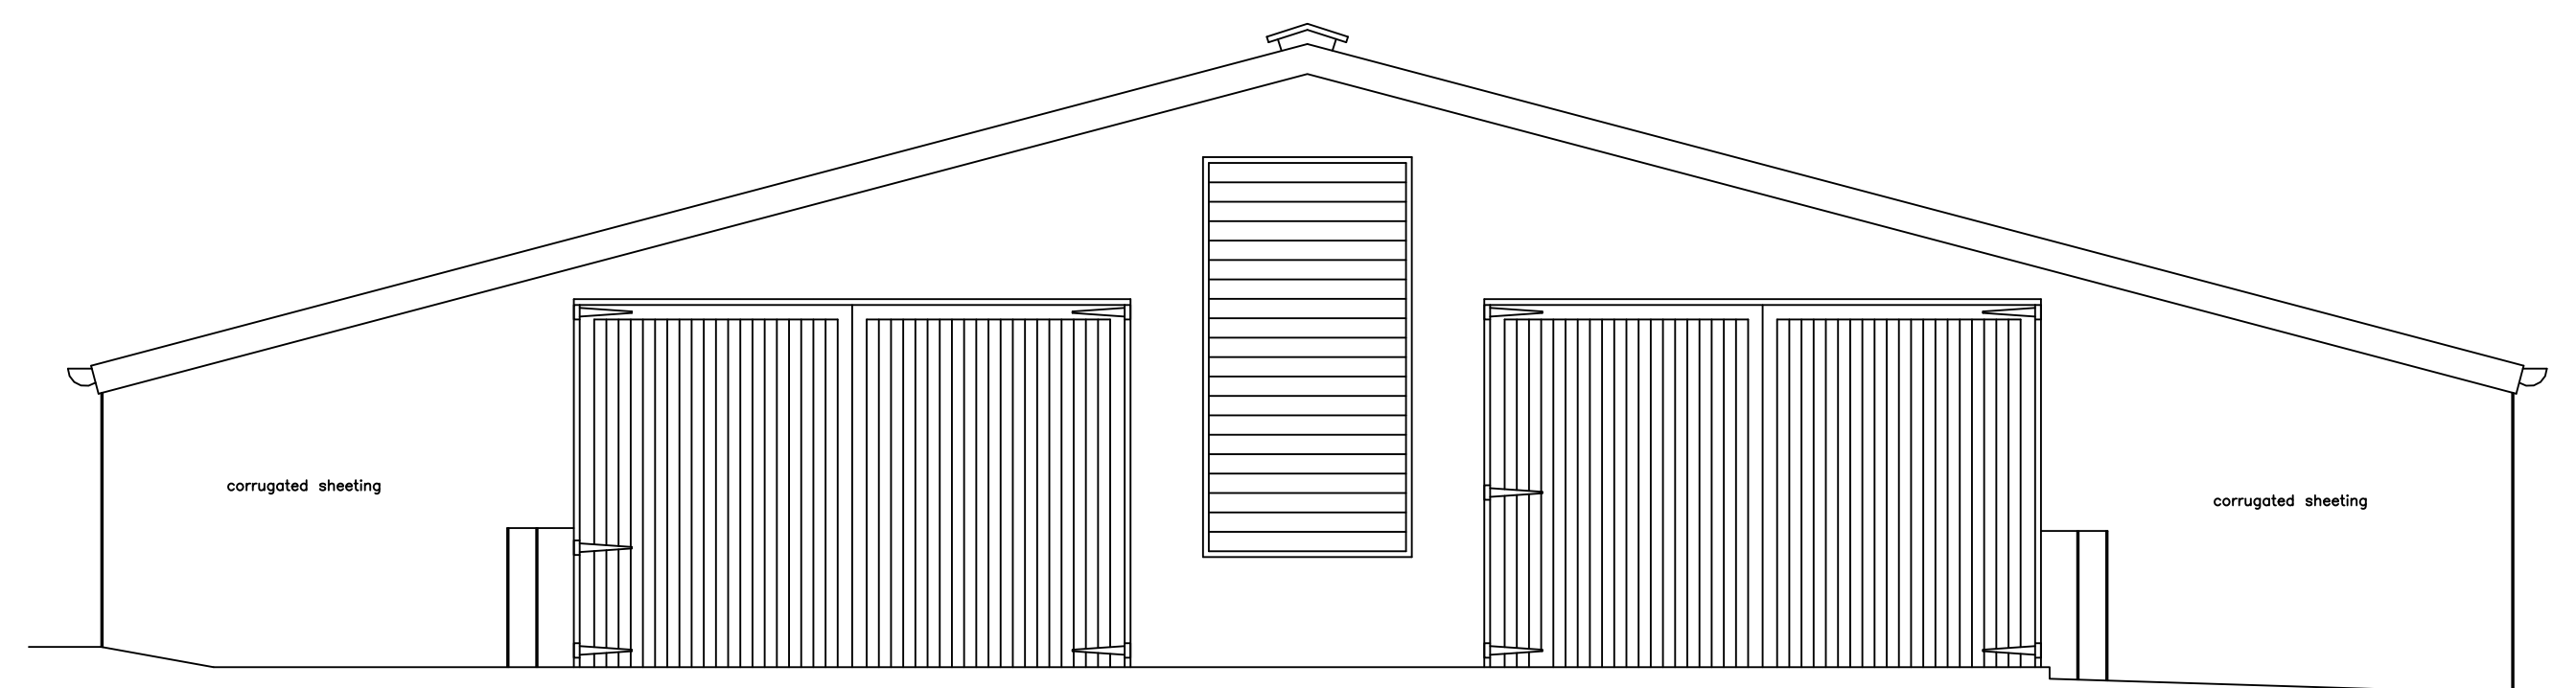NORTH ELEVATION




Datum 25.00m

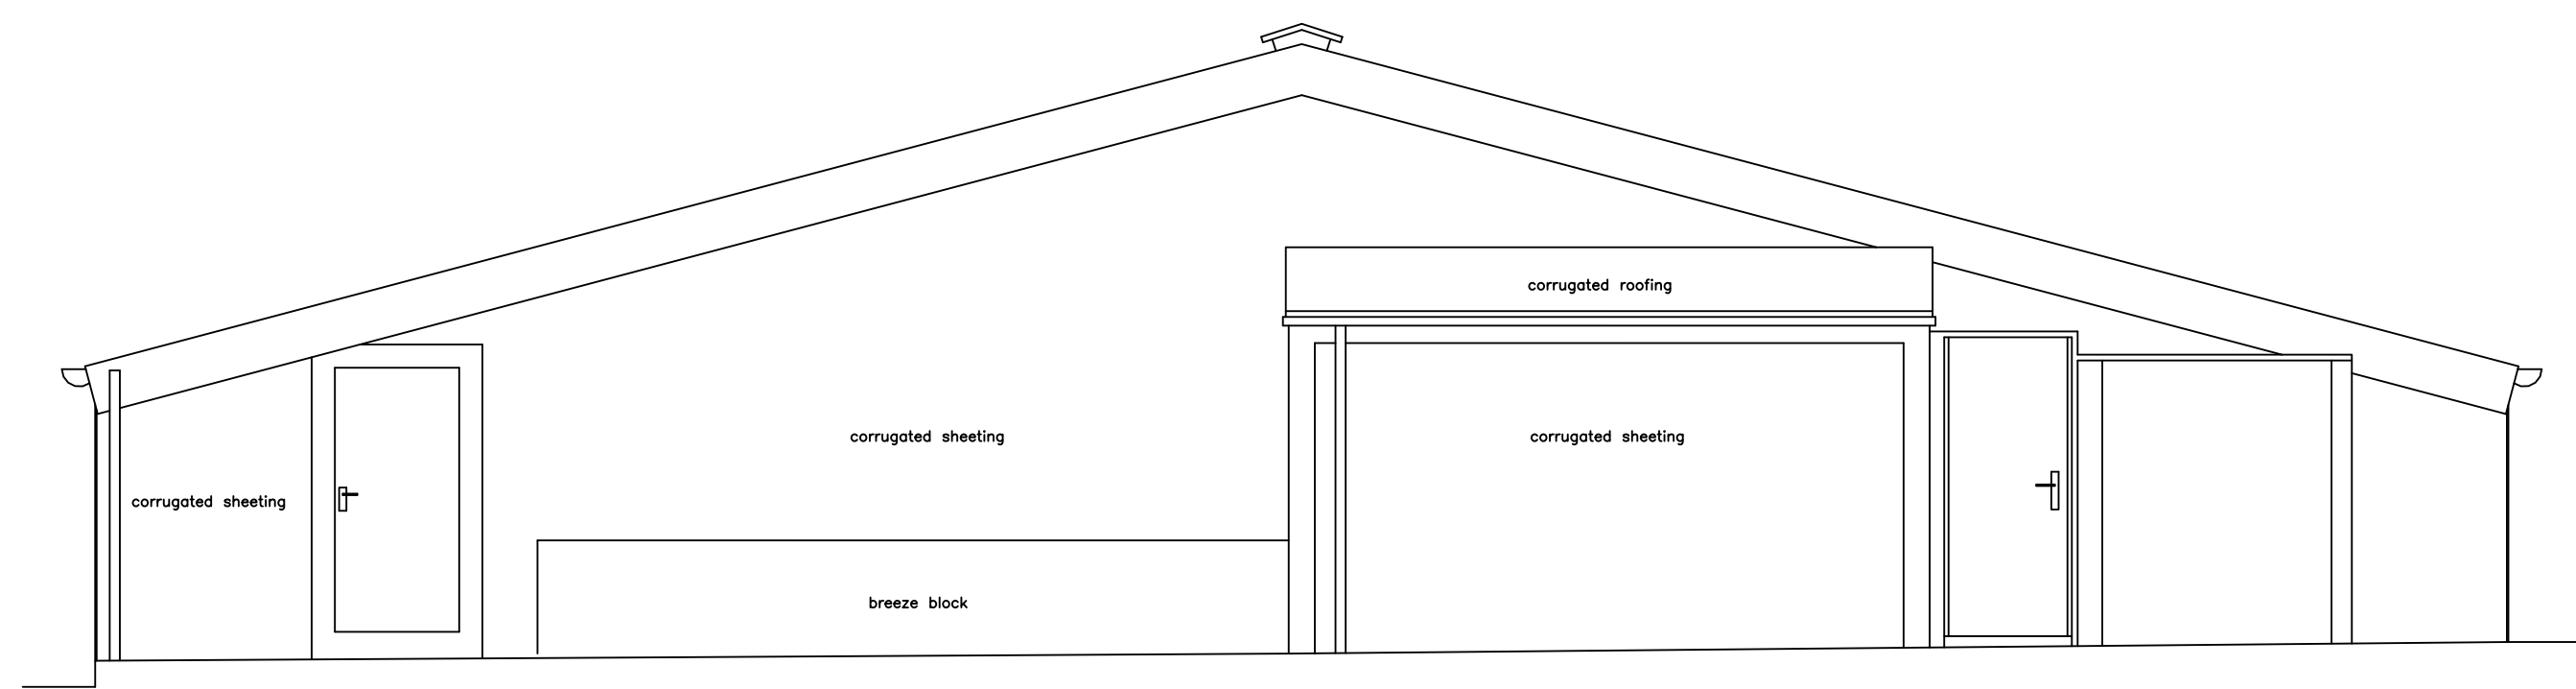EAST ELEVATION




Datum 25.50m

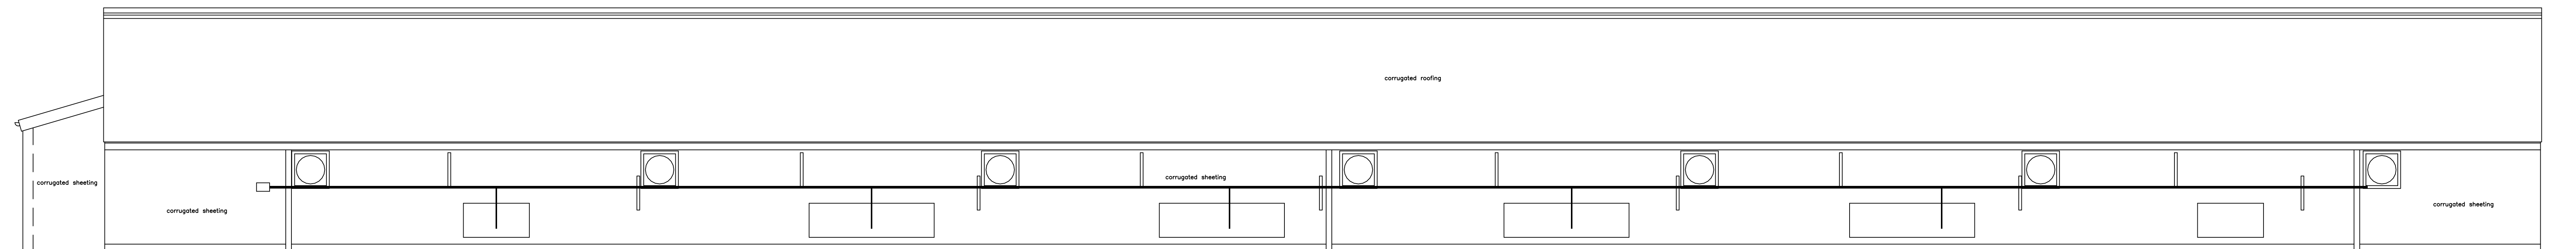WEST ELEVATION



Return 58.02m

 SOUTH ELEVATION



MIDLAND SURVEY LTD

HEAD OFFICE
Cromwell House, Westfield Road, Southorn, Warwickshire, CV47 0JH.
Tel: 01926 810511 Fax 01926 810512
E-Mail: mail@midlandsurvey.co.uk
www.midlandsurvey.co.uk

Client JSA ARCHITECTS

Project STOKES FARM, WOKINGHAM, RG40 5PR

Title	ELEVATIONS
-------	------------

Date	NOVEMBER 2020	Revisions
------	---------------	-----------

Scale 1:50000

Dwg No 37392/4

Surveyor J.M.P.

Checked D.C.J

TOPOGRAPHICAL (LAND) SURVEYORS / UTILITY SURVEYORS
BUILDING MEASUREMENT SURVEYORS / 3D LASER SCANNING



Accredited Contractor   ASSOCIATION

© Copyright Midland Survey Ltd. Reproduction of this information is prohibited without written authorisation from Midland Survey Ltd.