


P:\23-190 - St Anne's Drive, Wokingham (Antler)\Tech\Acad\Drawings\200 Series - Engineering\23-190-215 - 219 - Drainage Layout.dwg

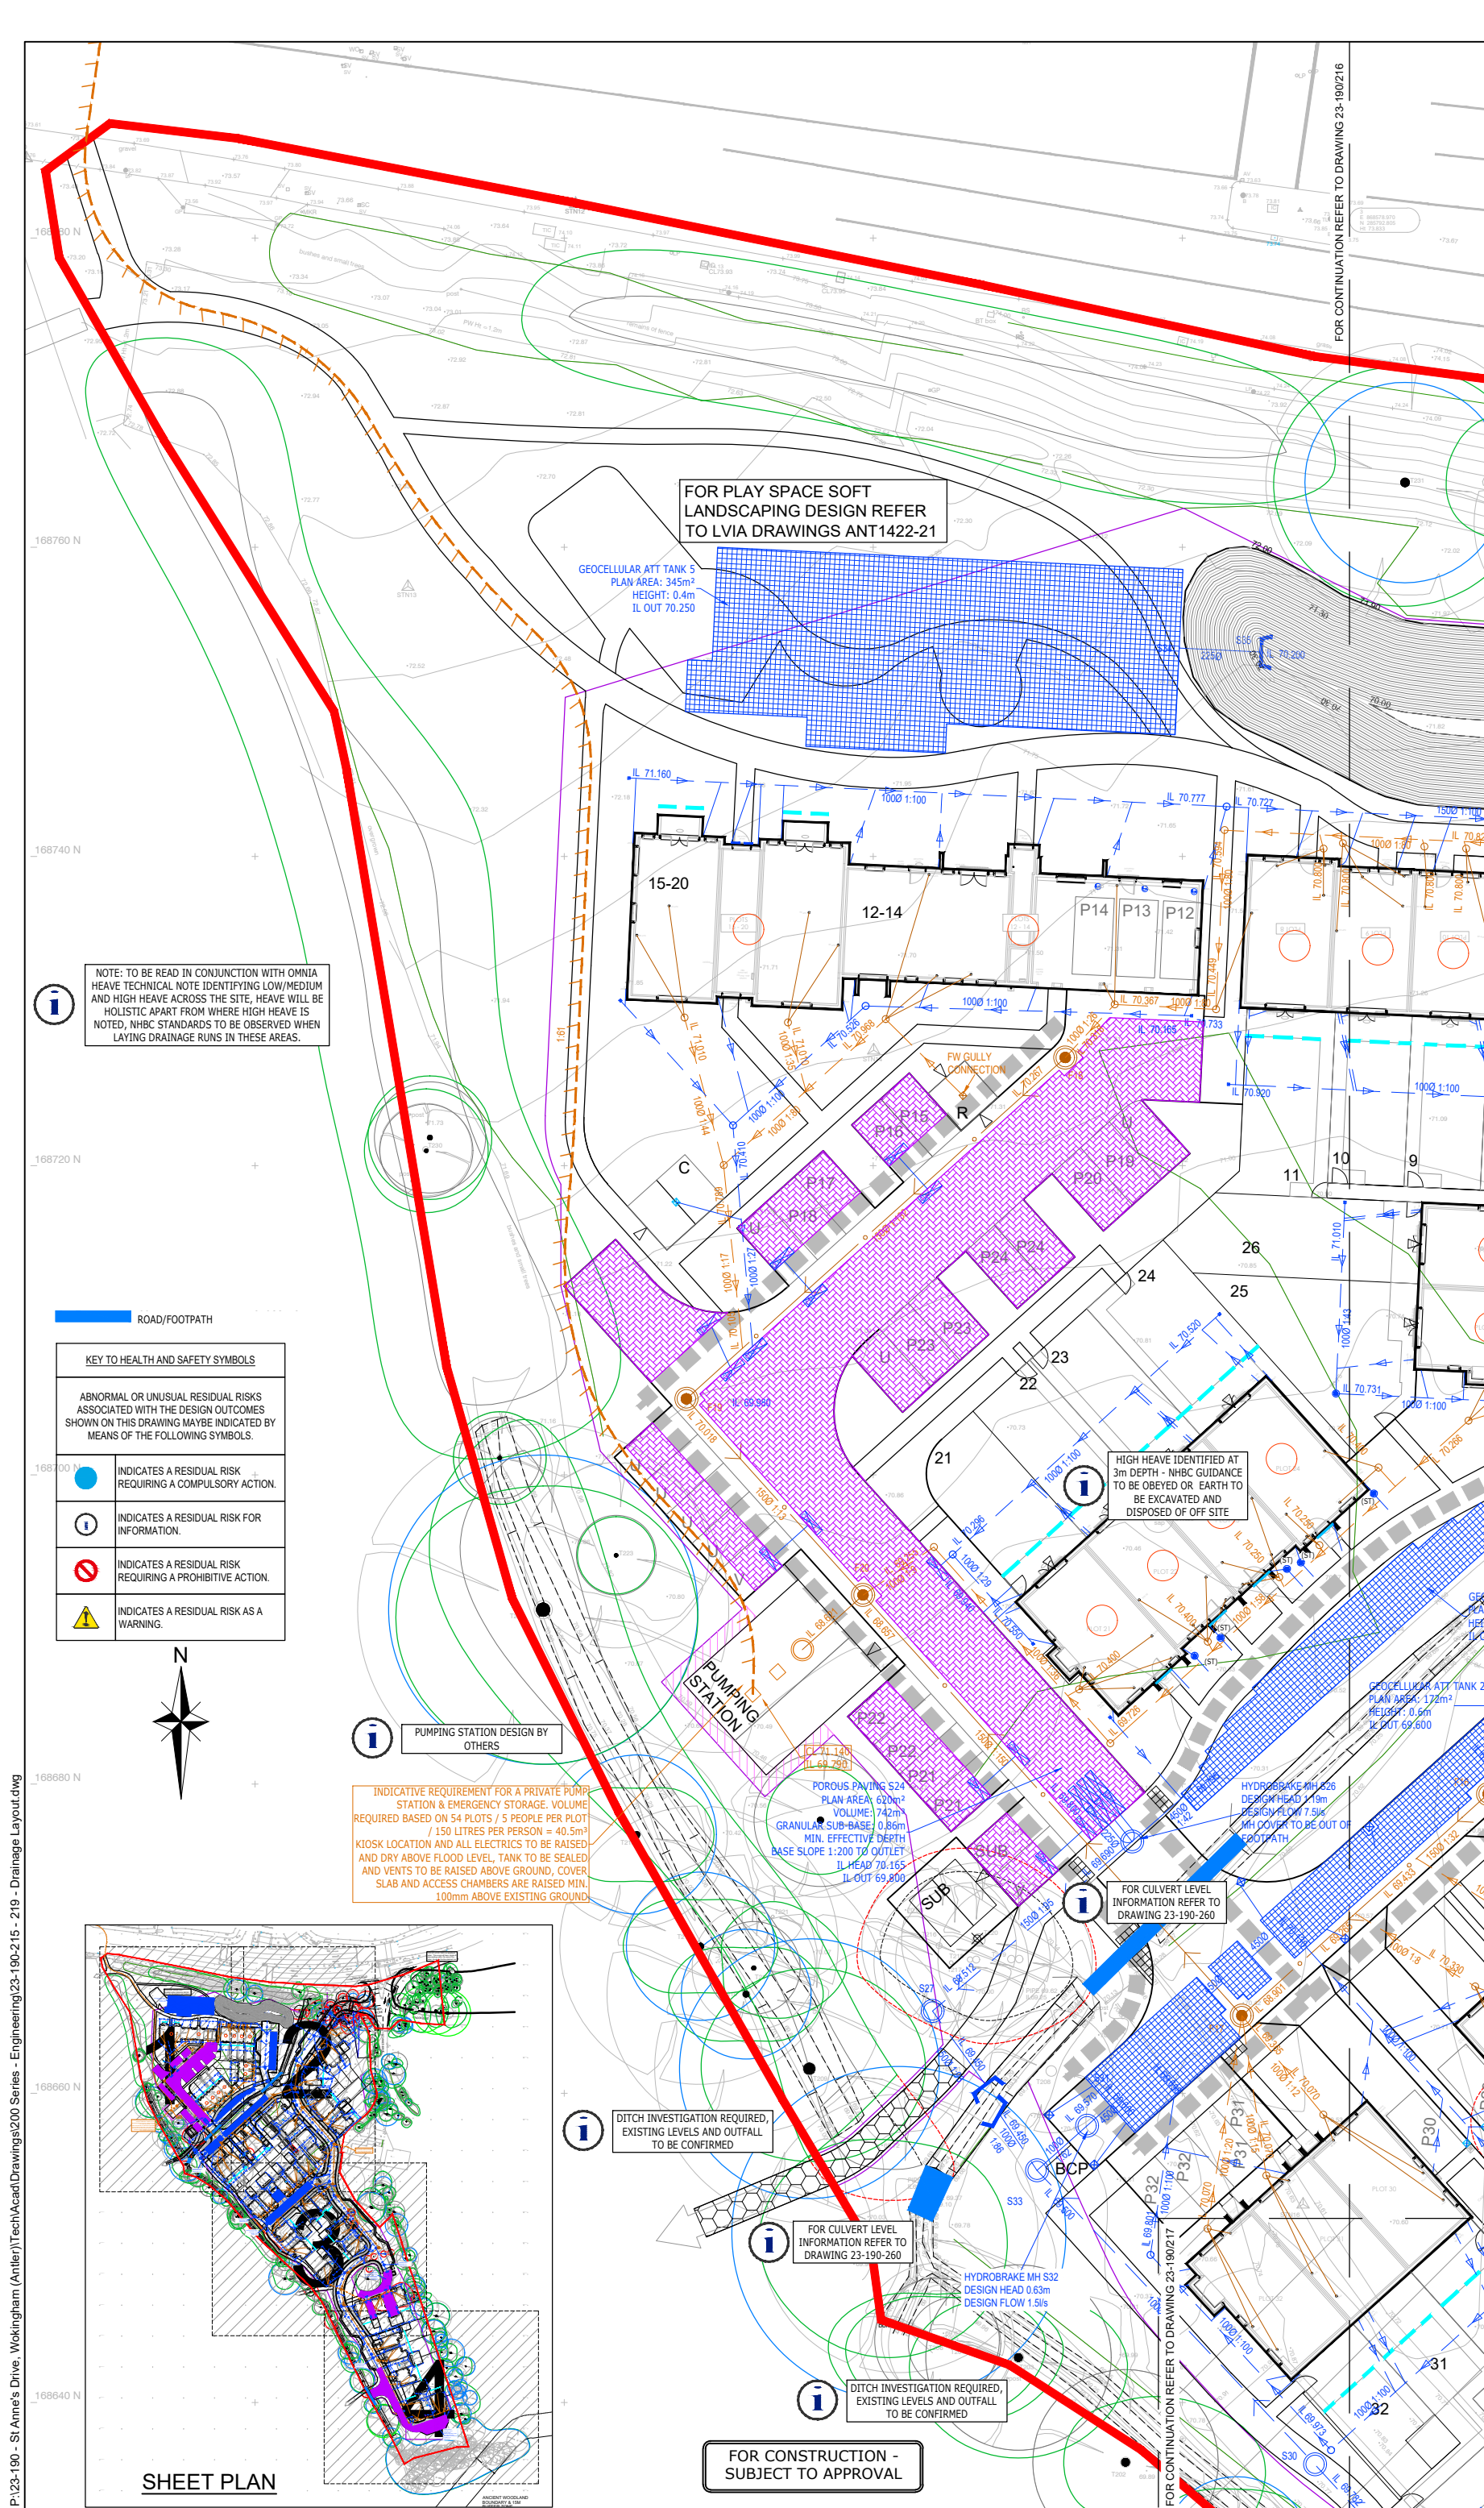

NOTE: TO BE READ IN CONJUNCTION WITH OMNIA HEAVE TECHNICAL NOTE IDENTIFYING LOW/MEDIUM AND HIGH HEAVE ACROSS THE SITE, HEAVE WILL BE HOLISTIC APART FROM WHERE HIGH HEAVE IS NOTED, NHBC STANDARDS TO BE OBSERVED WHEN LAYING DRAINAGE RUNS IN THESE AREAS.

FOR PLAY SPACE SOFT LANDSCAPING DESIGN REFER TO LVIA DRAWINGS ANT1422-21

GEOCELLULAR ATT TANK 5
PLAN AREA: 345m²
HEIGHT: 0.4m
IL OUT 70.250

HIGH HEAVE IDENTIFIED AT 3m DEPTH - NHBC GUIDANCE TO BE OBEYED OR EARTH TO BE EXCAVATED AND DISPOSED OF OFF SITE

INDICATIVE REQUIREMENT FOR A PRIVATE PUMP STATION & EMERGENCY STORAGE. VOLUME REQUIRED BASED ON 54 PLOTS / 5 PEOPLE PER PLOT / 150 LITRES PER PERSON = 40.5m³ KIOSK LOCATION AND ALL ELECTRICS TO BE RAISED AND DRY ABOVE FLOOD LEVEL. TANK TO BE SEALED AND VENTS TO BE RAISED ABOVE GROUND, COVER SLAB AND ACCESS CHAMBERS ARE RAISED MIN. 100mm ABOVE EXISTING GROUND

DITCH INVESTIGATION REQUIRED, EXISTING LEVELS AND OUTFALL TO BE CONFIRMED

FOR CULVERT LEVEL INFORMATION REFER TO DRAWING 23-190-260

DITCH INVESTIGATION REQUIRED, EXISTING LEVELS AND OUTFALL TO BE CONFIRMED

FOR CONSTRUCTION - SUBJECT TO APPROVAL

FOR CONTINUATION REFER TO DRAWING 23-190-216

FOR CONTINUATION REFER TO DRAWING 23-190-217

NOTES

- THIS DRAWING IS TO BE READ IN CONJUNCTION WITH ALL OTHER RELATED DRAWINGS ISSUED BY THE ARCHITECT AND ENGINEER.
- DO NOT SCALE FROM THIS DRAWING. WORK FROM FIGURED DIMENSIONS ONLY.
- EXISTING GROUND LEVELS (SHOWN TO AN ORDNANCE DATUM) ARE BASED ON "GROUNDSURVEYS LTD" TOPOGRAPHICAL SURVEY - JOB NO. 5965 DATED 2023. ODYSSEY ASSUMES NO RESPONSIBILITY ON THE LEVEL OF ACCURACY OF SURVEY INFORMATION PROVIDED.
- ALL DIMENSIONS SHOWN IN METERS UNLESS NOTED OTHERWISE.
- ALL DIMENSIONS, LEVELS AND SURVEY GRID CO-ORDINATES ARE TO BE CHECKED ONSITE AND THE ENGINEER NOTIFIED IMMEDIATELY OF ANY DISCREPANCIES PRIOR TO THE COMMENCEMENT OF THE WORKS.
- PRIVATE DRAINAGE WORKS TO BE CARRIED IN ACCORDANCE WITH NHBC AND/OR BUILDING REGULATIONS 2010 (2015 EDITION), SIGMA HOMES STANDARDS AND TO THE CURRENT BRITISH STANDARD BS EN 752.
- PRIVATE DRAINS TO BE CONSTRUCTED USING FLEXIBLY JOINTED VITRIFIED CLAY PIPES (HEPWORTH SUPERSLEVE OR SIMILAR APPROVED) OR UPVC BUILDING DRAINAGE SYSTEM PIPEWORK TO BS EN 1401, BEDDED AND BACKFILLED IN ACCORDANCE WITH THE MANUFACTURER'S INSTRUCTIONS AND THE SPECIFICATIONS LISTED ABOVE.
- SURFACE WATER FROM PRIVATE AREAS IS NOT TO BE DISCHARGED ONTO THE HIGHWAY, I.E. DRAINAGE CHANNELS SHOWN WILL INTERCEPT FLOWS FROM PRIVATE AREAS AND CONNECT INTO THE PRIVATE SYSTEM.
- PRIVATE INSPECTION CHAMBER SIZES ARE TO BE IN ACCORDANCE WITH THE BUILDING REGULATIONS PART H; TABLE 11 AND MANHOLE SIZES TABLE 12.
- ALL RWP'S TO HAVE RODDING ACCESS.
- ALL FOUL AND SURFACE WATER DRAINAGE PIPES WITHIN PRIVATE AREAS TO BE 100mm Ø UNLESS SPECIFIED OTHERWISE.
- FIRST SURFACE WATER INSPECTION CHAMBER TO BE 600mm DEEP UNLESS SPECIFIED OTHERWISE. FIRST FOUL SEWER INSPECTION CHAMBERS TO BE 750mm DEEP UNLESS SPECIFIED OTHERWISE.
- ALL DRAINAGE TESTING REQUIRED IS TO BE CARRIED OUT AT THE CONTRACTORS EXPENSE.
- DRAINS IN AREAS OF MADE GROUND TO BE CONSTRUCTED BY FIRST MAKING UP THE AREA TO APPROXIMATELY FINISHED LEVEL AND THEN EXCAVATE THROUGH THE FILL MATERIAL INTO UNDISTURBED GROUND. THE DRAIN TRENCH IS THEN TO BE BACKFILLED TO FORMATION LEVEL USING SUITABLE GRANULAR FILL MATERIAL WELL COMPACTED IN LAYERS NOT EXCEEDING 225 THICK.
- ALL CHAMBERS/MANHOLES IMMEDIATELY UPSTREAM OF PERMEABLE PAVING DIFFUSERS AND PIPES UPSTREAM OF ATTENUATION TANKS TO INCORPORATE SILT TRAPS.
- FOR PIPES WHERE MINIMUM COVER IN ACCORDANCE WITH BUILDING REGULATIONS PART H TABLES 8 TO 10 IS NOT MET CONCRETE SLAB / CONCRETE SURROUND PROTECTION MUST BE ADDED OR DUCTILE IRON PIPES USED INSTEAD.
- TREE PROTECTION PLAN MUST BE CONSULTED PRIOR TO DRAINAGE WORKS AND ANY POTENTIAL CLASHES REPORTED TO THE CLIENT / ENGINEER AND ARBORICULTURIST IMMEDIATELY.
- IF THERE IS ANY AMBIGUITY BETWEEN THE SPECIFICATION AND THE DRAWINGS, THE CONTRACTOR SHALL IMMEDIATELY INFORM THE ENGINEER.
- NO DEVIATION FROM THE DETAILS SHOWN ON THIS DRAWING IS PERMITTED WITHOUT PERMISSION FROM THE ENGINEER.
- CONTRACTOR TO LOCATE THE POSITION AND DEPTH OF ALL SERVICES BEFORE COMMENCING ANY WORKS.
- MH COVERS TO BE POSITIONED ¼ CARRIAGEWAY WIDTH OR OUT OF THE MAIN VEHICULAR WHEEL TRACKS AND OPPOSITE ROAD JUNCTIONS WHERE POSSIBLE.
- RECESSED MANHOLE COVERS TO BE USED WHERE LOCATED WITHIN BLOCKWORK.
- 100L WATER BUTTS TO BE PROVIDED TO ALL PRIVATE PLOTS TO ANTLER HOMES SPECIFICATION.
- IN COMPLIANCE WITH CDM 2015 ODYSSEY HAS FOLLOWED ITS DESIGN RISK MANAGEMENT PROCESS FOR HAZARD ELIMINATION AND RISK REDUCTION IN DEVELOPING THE ODYSSEY DESIGNS SHOWN ON THIS DRAWING. THERE ARE NO ABNORMAL OR UNUSUAL RESIDUAL RISKS ASSOCIATED WITH THE DESIGN, THERE ARE HOWEVER AREAS OF REQUIRED INFORMATION PENDING FURTHER INVESTIGATION. ANY OTHER RESIDUAL RISKS ARE THOSE THAT WOULD NORMALLY BE EXPECTED BY COMPETENT PERSONS OR CONTRACTORS ENGAGED ON WORK OF THIS NATURE OR TYPE.

LEGEND

- SITE BOUNDARY
- EXISTING PUBLIC FOUL WATER SEWER
- FOUL WATER HIGHWAY SEWER
- SURFACE WATER HIGHWAY SEWER
- FWMH - PRIVATE FOUL WATER MANHOLE (PCC RINGS)
- FW-TYPE3 - PRIVATE FOUL WATER MH - MIN 0.60m DIA
- FW-IC3 - PRIVATE FOUL WATER INSPECTION CHAMBER - MIN 0.45m DIA
- SWMH - PRIVATE SURFACE WATER MANHOLE (PCC RINGS)
- SW-IC3 - PRIVATE SURFACE WATER INSPECTION CHAMBER - MIN 0.45m DIA
- SILT TRAP
- ROAD GULLY
- YARD GULLY
- RODDING EYE
- DIFFUSER UNIT BETWEEN PIPED DRAINAGE AND PERMEABLE PAVING
- PRIVATE FOUL WATER DRAINAGE
- PRIVATE SURFACE WATER DRAINAGE
- FOUL WATER LATERAL
- PROPOSED PRIVATE CHANNEL BY ACO OR SIMILAR APPROVED
- PRIVATE SURFACE WATER FILTER DRAIN - PERFORATED PIPE LAID FLAT DISCHARGING TO GROUND NOT TO BE CONNECTED TO THE SW SYSTEM
- THRESHOLD SLOT DRAIN TO MANUFACTURERS SPECIFICATION
- FOUL WATER RISING MAIN
- PERMEABLE PAVING UNDER-DRAIN
- LINED POROUS PAVING WITH 600mm (OR AS NOTED) MIN. EFFECTIVE DEPTH
- ATTENUATION TANK (GEOCELLULAR UNITS)
- INDICATIVE SERVICE CORRIDOR - REFER TO SERVICES DRAWINGS FOR SERVICE LOCATIONS
- 1m PROTECTION ZONE AROUND PUMP STATION
- ROOTLOCK HEADWALL - TYPE TO BE AGREED WITHIN OWC
- CULVERT AND HEADWALL CROSSING ROAD/FOOTPATH

Rev	Amendments	Dm	Chk	App	Date
J	PLOTS 8-11 ROTATED	LG	JK	BAC	13.05.25
H	ISSUE FOR CONSTRUCTION	EW	LG	BAC	14.03.25
G	STORAGE TANK 1 SIZE REDUCED AND STORAGE TANK 2 SPLIT FOR SERVICES, MH POSITIONS AMENDED TO SUIT FOLLOWING ANTLER INSTRUCTION.	LG	SW	SW	20.02.25
F	LAYOUT UPDATED AS PER ANTLER HOMES COMMENTS DATED 22.10.2024.	LG	SW	SW	23.10.24

ODYSSEY

Unit 1 Pucknall Farm
Dones Lane
Romsey SO51 6QJ

Telephone: 01794 937980
Fax: 01265 301154
E: info@odysseyconsult.co.uk
W: www.odysseyconsult.co.uk

Job Title

**ST ANNE'S DRIVE
WOKINGHAM**

Drawing Title

**DRAINAGE LAYOUT
SHEET 1 OF 4**

Client

ANTLER HOMES

Scale	Date	Designed
1:200 @A1	JAN24	LG

Drawn	Checked	Approved
LG	SW	SW

Job No	Drawing No	Rev
23-190	23-190-215	J