


Rev:	Description:	By:	Date:
------	--------------	-----	-------



octopusenergy
services

Approved by:

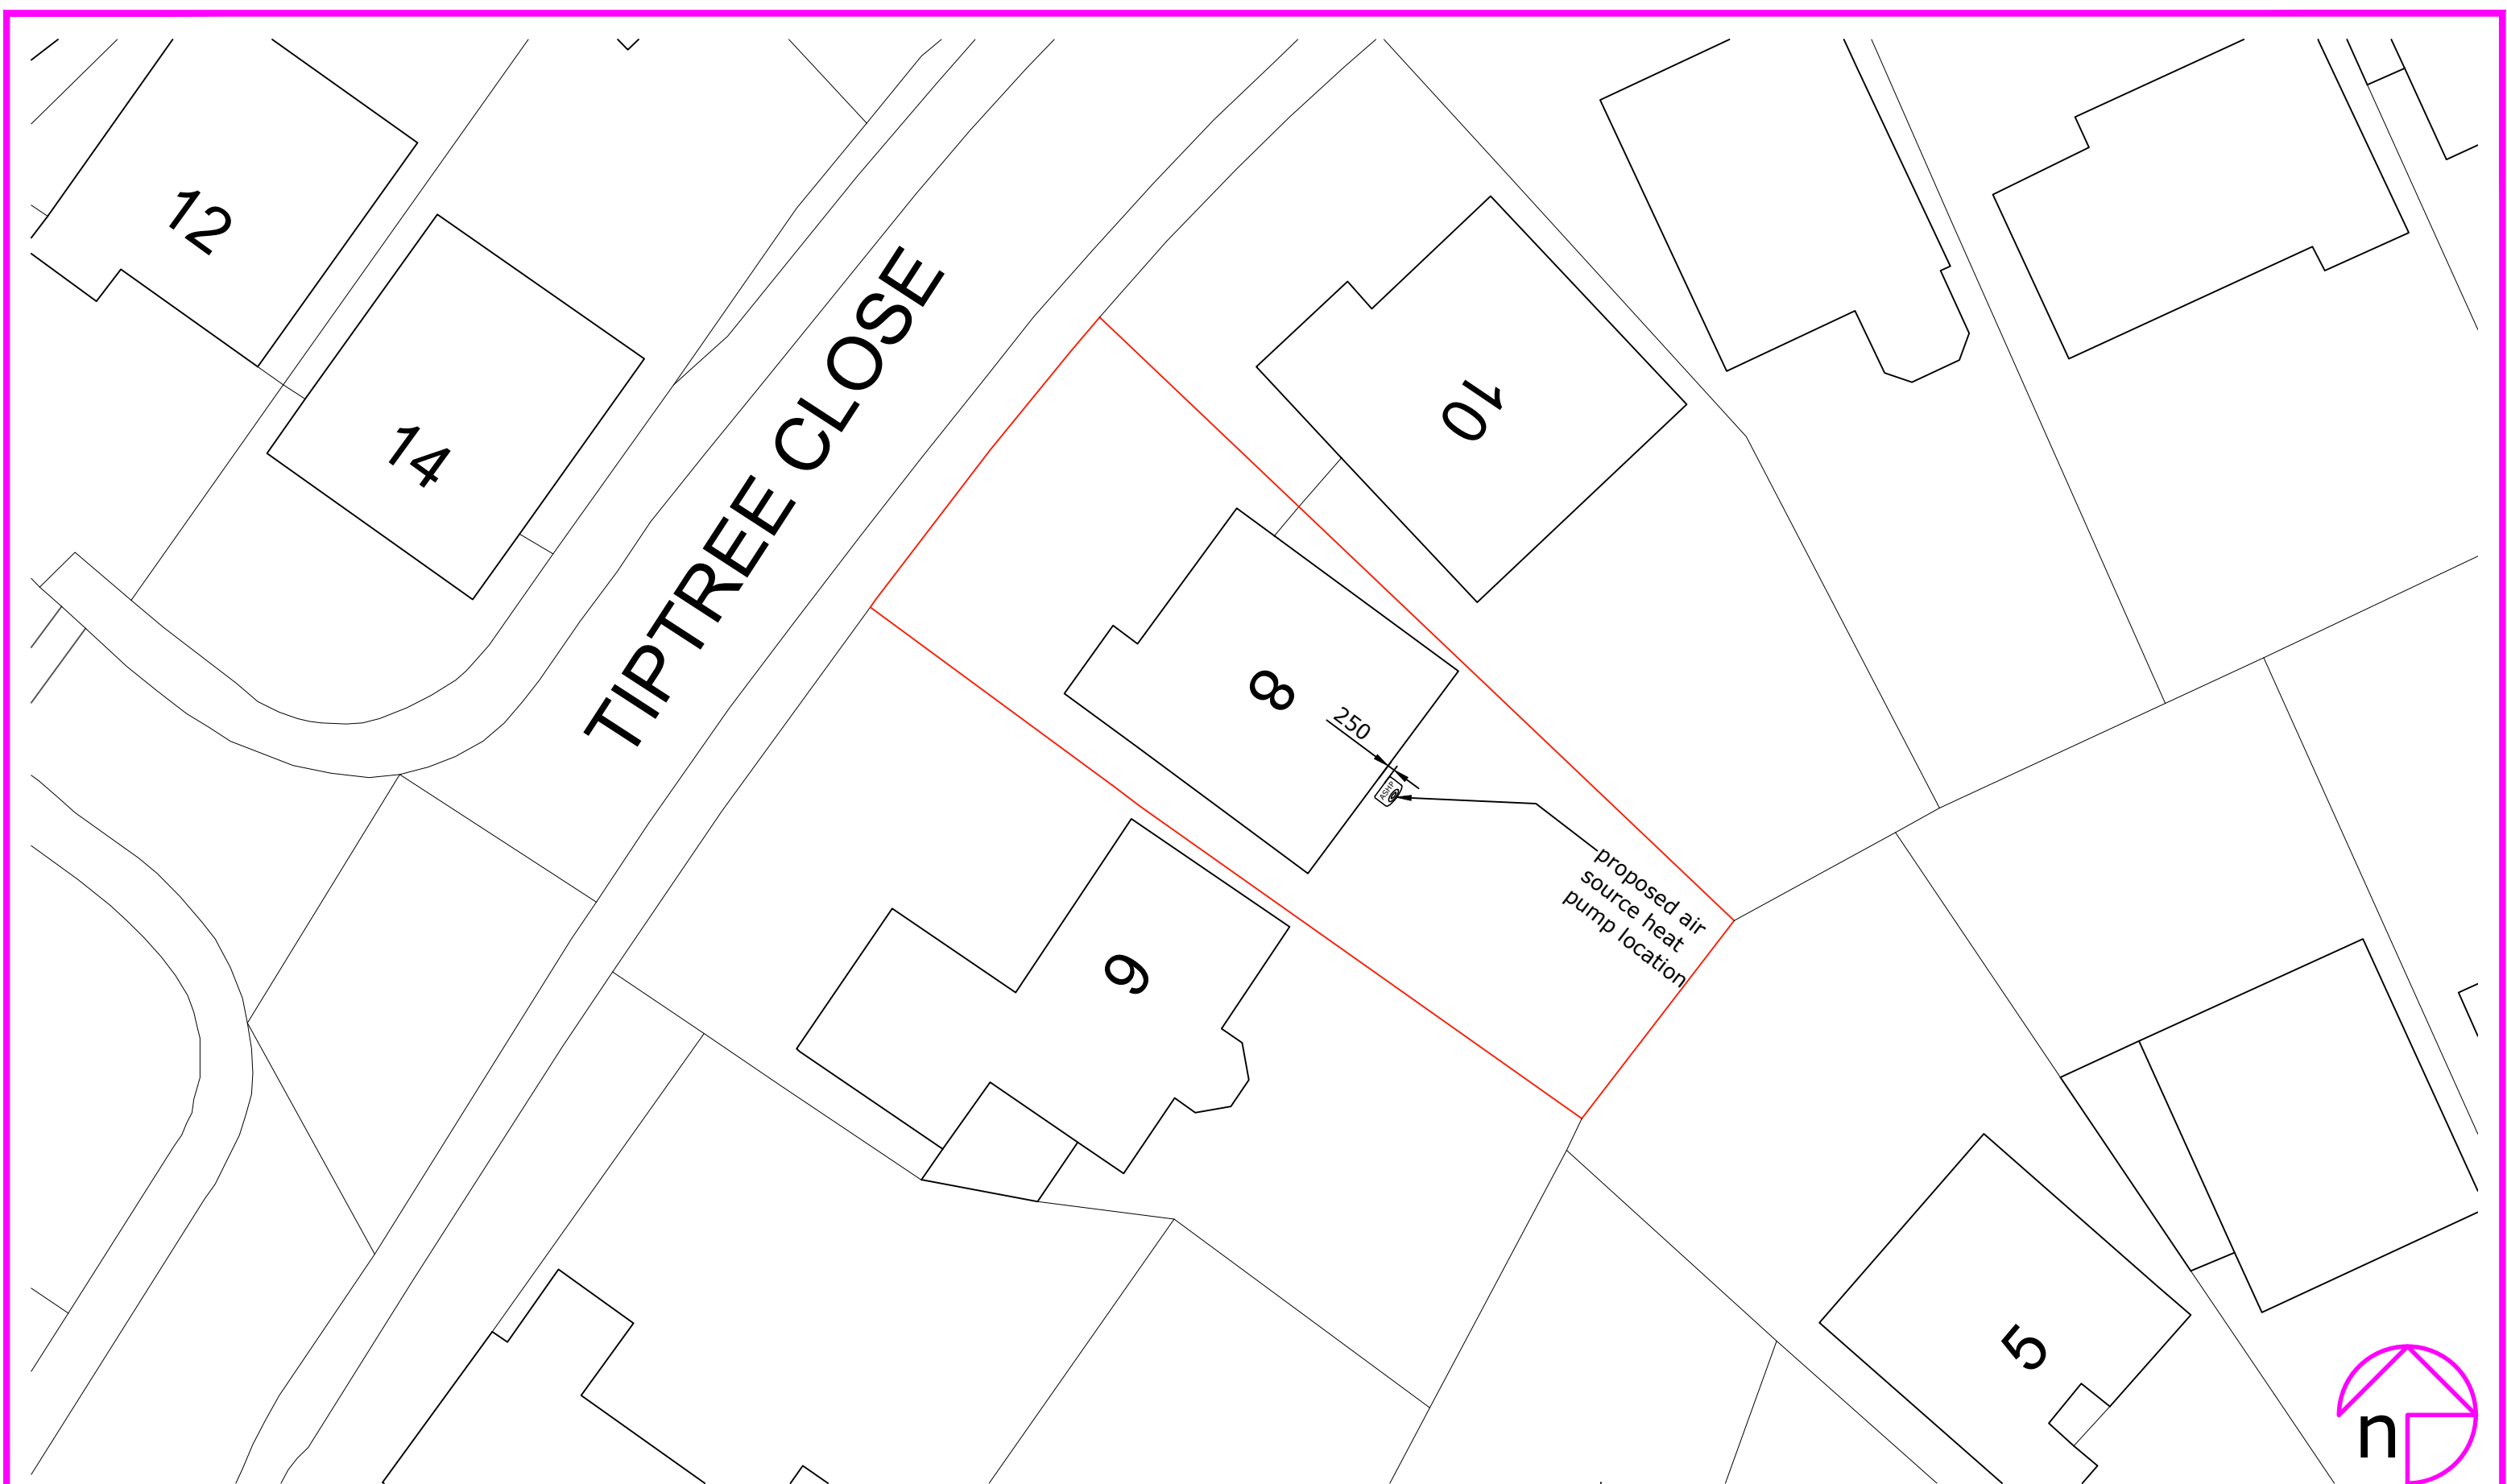

Client/Project:
Padmaja Gorthy
8 Tiptree Cl Lower Earley Earley
Reading RG6 4HS

Project status:
PLANNING (installation of air source heat pump)

Drawing title:
Site plan as proposed

Scale: 1:200	Paper Size: A3	Drawn: O Sage	Checked: Nathan Smith
Project ID: J-61D497D2	Drawing No: 02	Revision:	Date: 29.01.26