


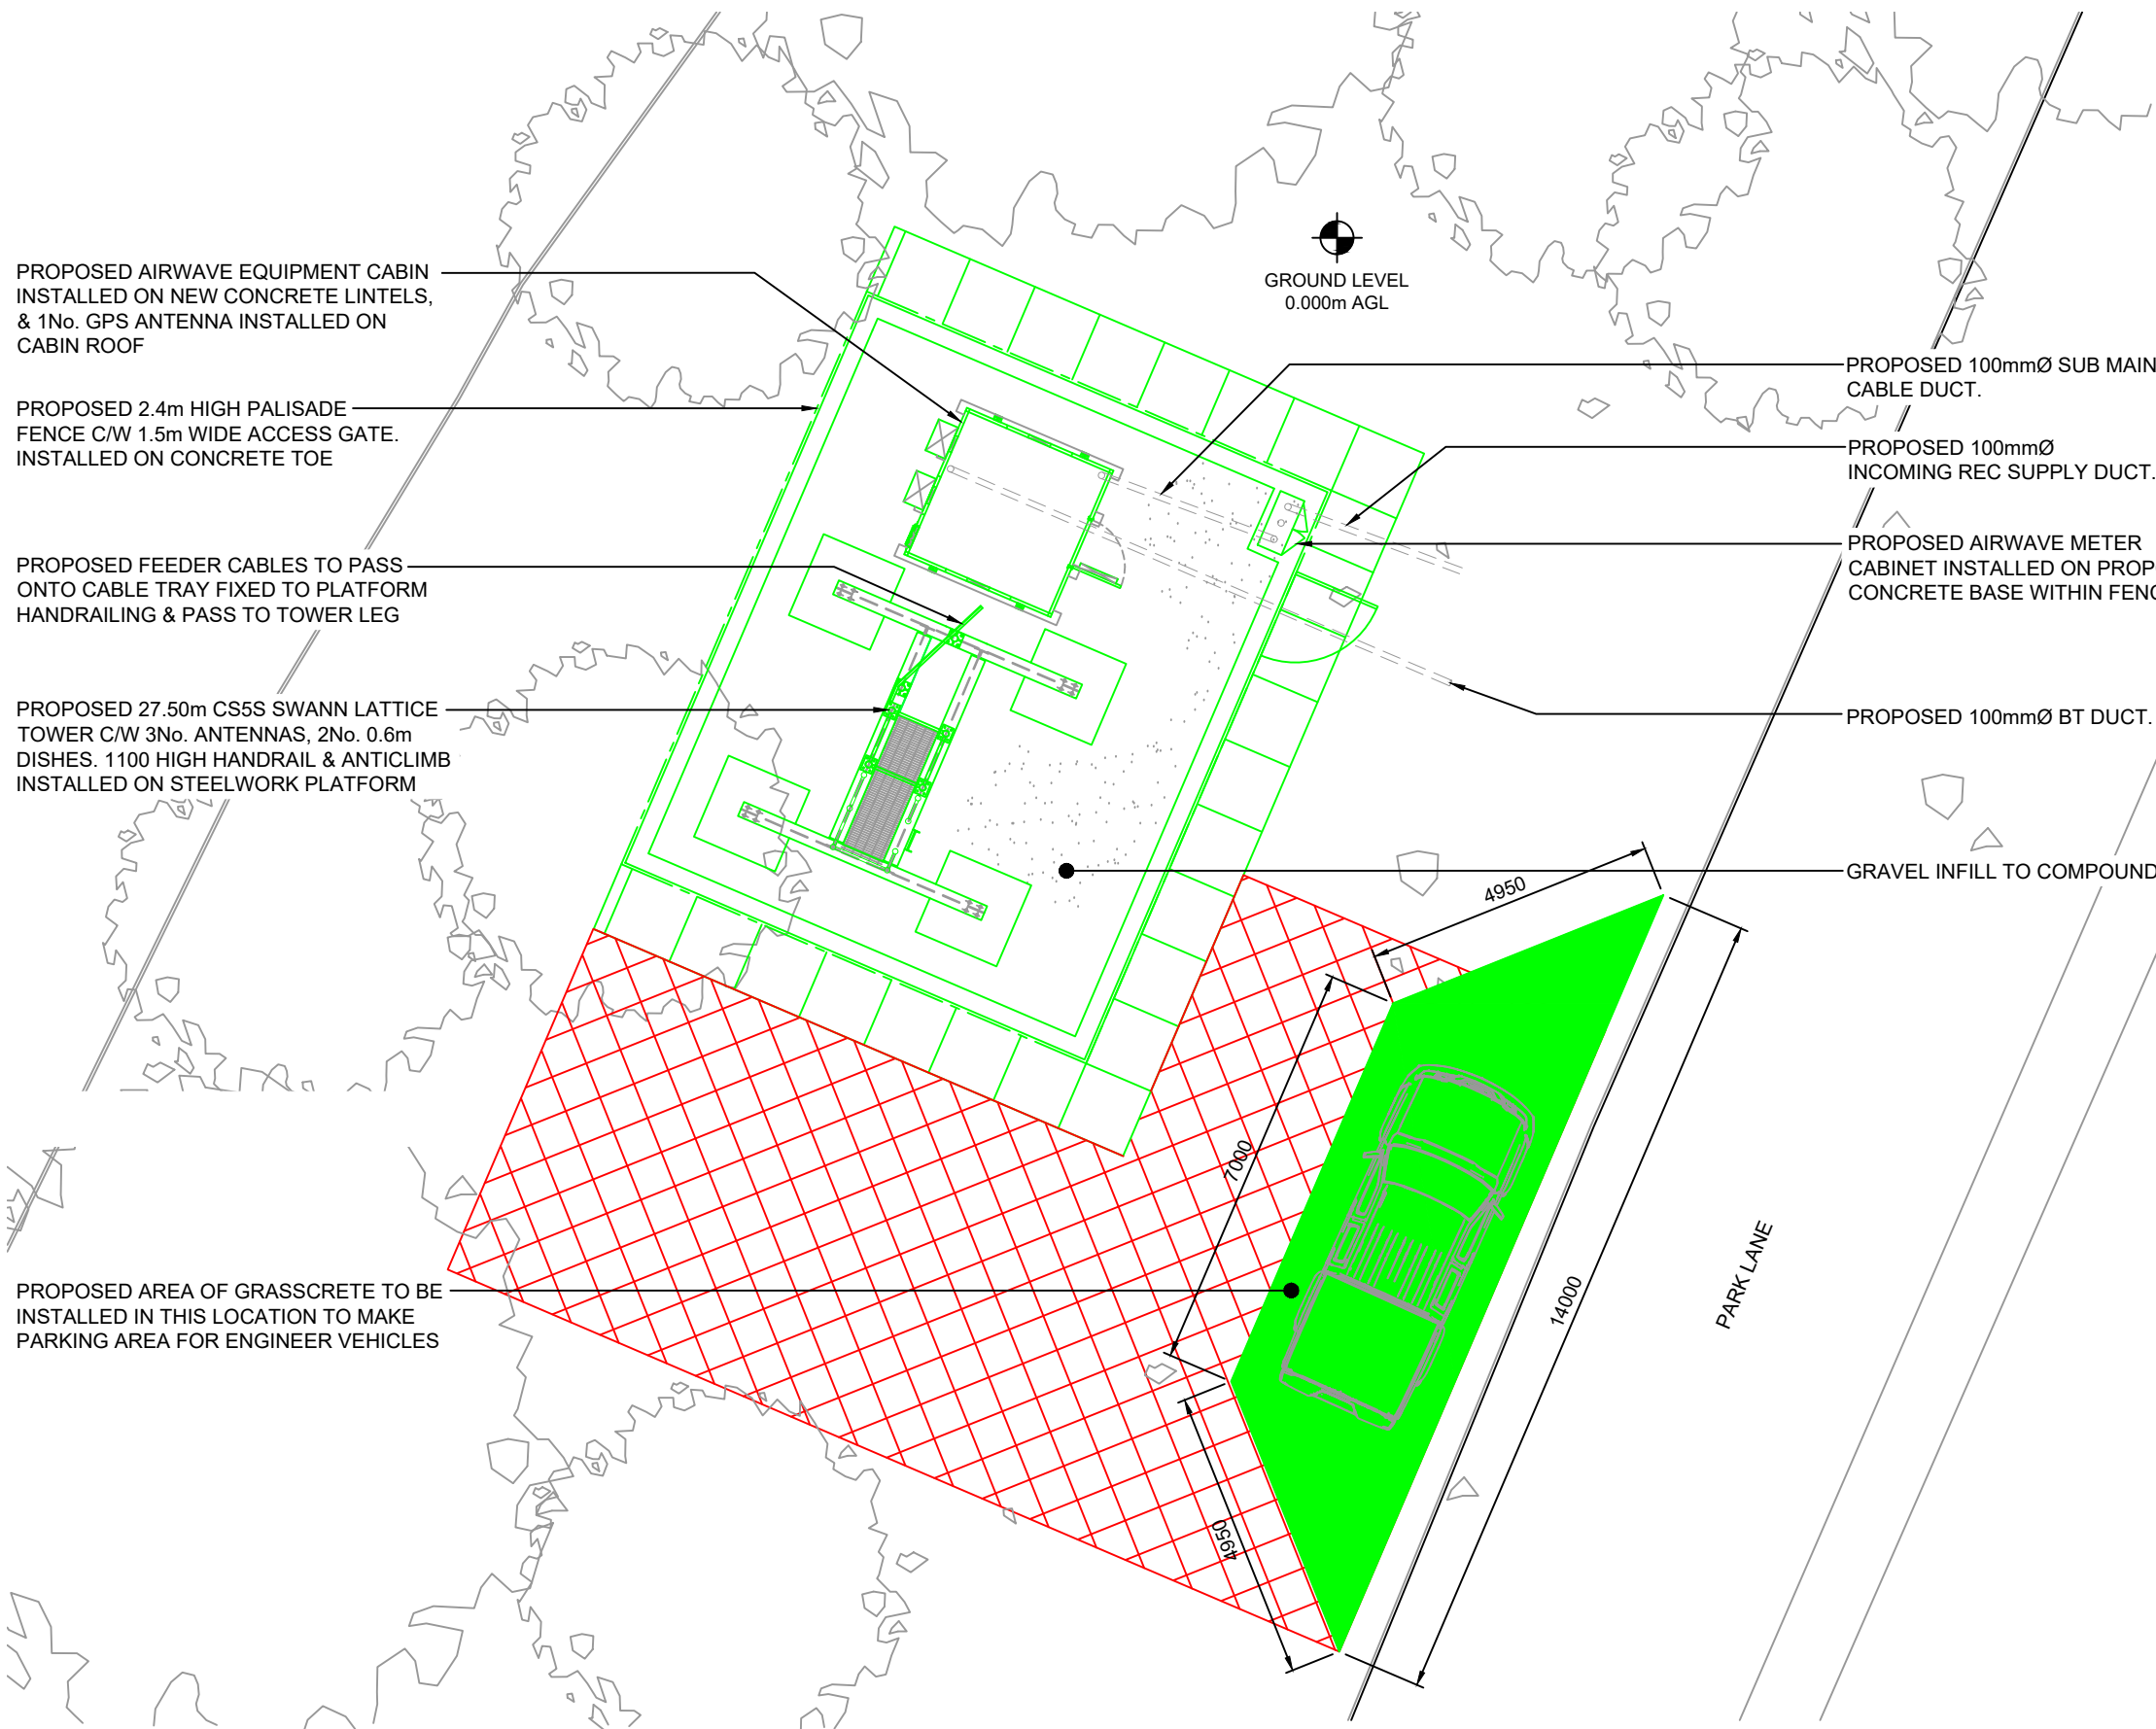

NOTE: ORIGINAL DRAWING SIZE A3

NOTES

1. This drawing to be read in conjunction with TVY181 Series drawings and standard Airwave drawings.
2. All dimensions are in mm unless otherwise stated.

B	10.09.25	REMOTE METER CABINET REMOVED	FM	DB
A	20.06.25	DETAILED DESIGN ISSUE	DB	AM
Rev	Date	Amendments	Drawn By	Approved By

**HEYROD COMMUNICATIONS LTD**

Thornley House,
Overens Street,
Oldham, OL4 1LA

Tel: 0161 6224160
Fax: 0161 6224161

**AIRWAVE**
a Motorola Solutions Company

Job Title
WEST COURT LAND, PARK LANE,
FINCHAMPSTEAD, ABORFIELD GREEN,
WOKINGHAM, RG40 4QF

Drawing Title
DETAILED DESIGN ISSUE
PROPOSED SITE PLAN
SHEET 02

Scale 1:125	Version V.1a	Approved by TH
Drawn by DB	Checked by AM	Date Approved 20.06.25
Date Drawn 20.06.25	Date Checked 20.06.25	

Drawing No. TVY181-DD-02

The design of this site is in accordance with the following design documentation:

Radio Base Station Design Guide & Specification - Issue Date 03.02.06	
Technical Guidance Notes - TGN 0092 to TGN 0124 inclusive.	