


ASTOR OUTDOOR WALL MOUNTED DOWNLIGHT
set 2m above FGL to restrict light emission
IP44 rated
220-240v
Class 1


Dimensions:
H11.8 x W8.6 x D10.5 cm

All light to be downlights only.


Symbol on plan

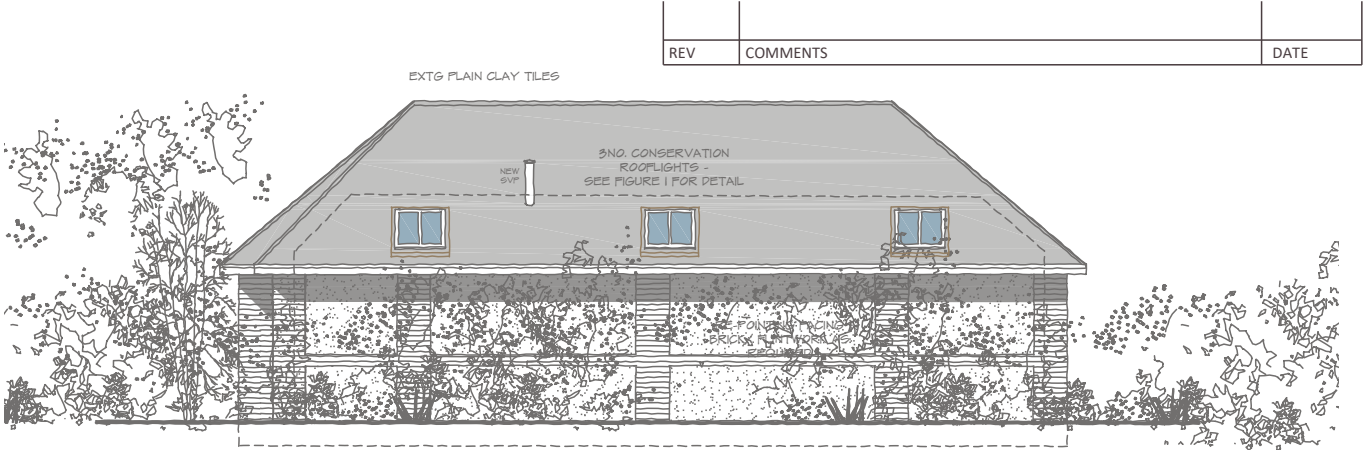


SOUTH ELEVATION

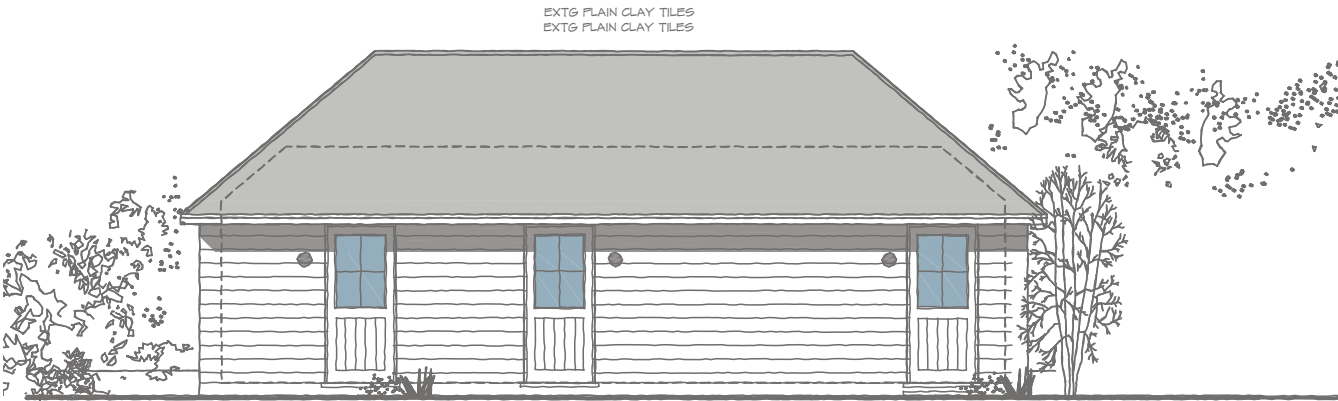


NORTH ELEVATION

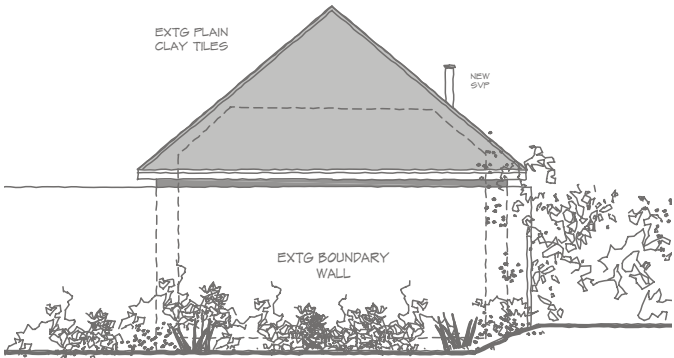

WEST ELEVATION

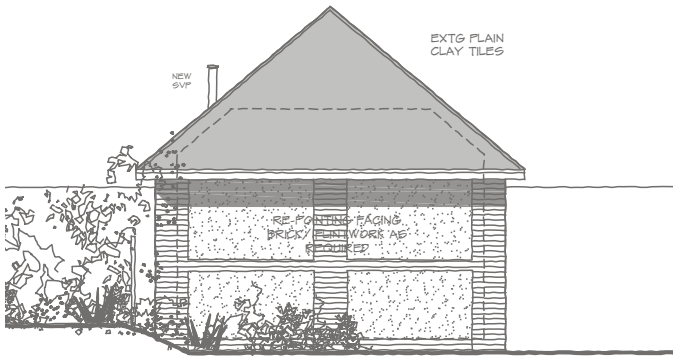

EAST ELEVATION

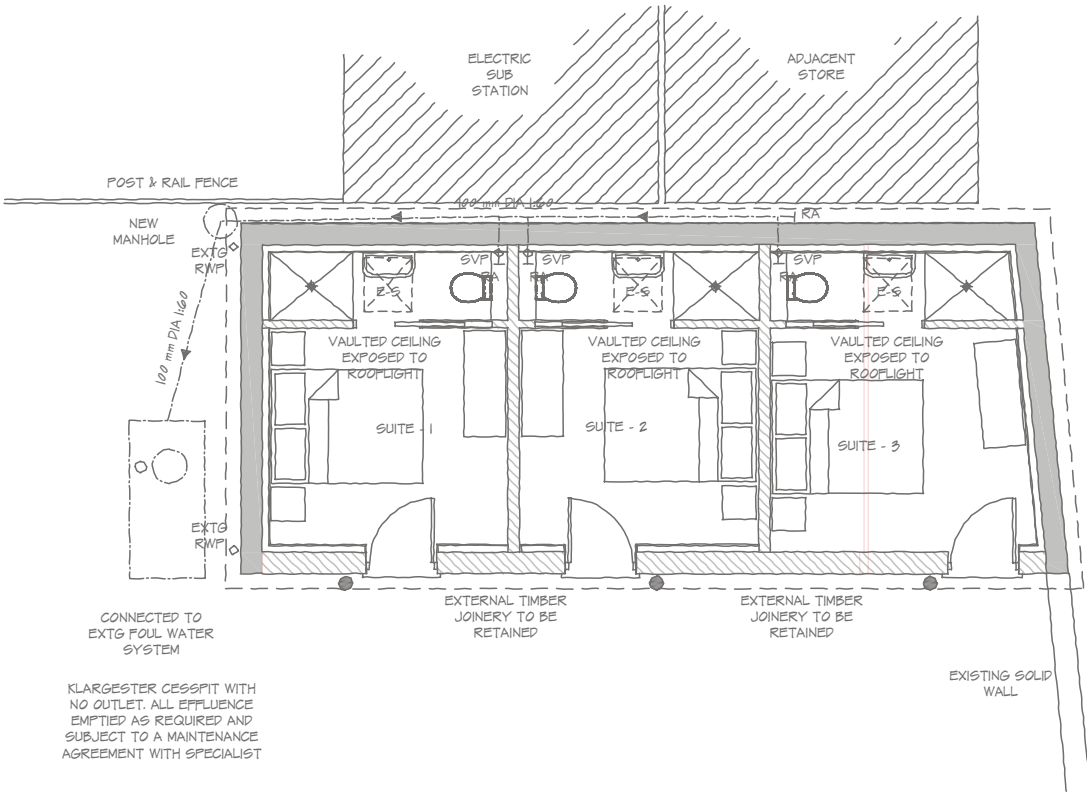

PROPOSED FLOOR PLAN

Twin Stage Gamma Cesspit

Kingspan Klargester Cesspit is a suitable capacity for 10 people. Complete with Standard Inlet Invert: 1000mm and Standard Outlet Invert: 1050mm

The Klargester Gamma Cesspit is manufactured from MDPE which makes it more robust than traditional GRP cesspits. The Klargester Gamma is ideal for installation where handling of the tank may be problematic.

MATERIALS:

- EXTG PLAIN CLAY TILES WITH BREATHER MEMBRANE (RE-ROOFED IN FEBRUARY 2023)
- FEATHERETCHED HORIZONTAL TIMBER BOARDING
- EXISTING FACING BRICKWORK/ FLINTWORK RE-POINTED AS REQUIRED
- TRADITIONAL TIMBER JOINERY
- EXTG SW PAINTED STABLE DOORS REPLACED WITH DOORS TO MATCH EXTG

1:100 scale Bar
This Drawing has been produced for printing onto A3 size paper,



www.starchitecture.co.uk studio@starchitecture.co.uk 0118 989 0808

CLIENT Mr C. Ballard

PROJECT Flower Pot, Public House,
Aston, Henley on Thames, RG9 3DG.

DRAWING Proposed Outbuilding

STATUS

SCALE 1:100 @A3 DRAWN dna CHECKED NO 3866/211 REV E

DATE Feb 2023

THIS DRAWING MUST NOT BE SCALED UNLESS ISSUED FOR PLANNING PURPOSES. ALL DIMENSIONS ARE TO BE VERIFIED PRIOR TO SETTING OUT, COMMENCING WORK, OR PRODUCTION OF FABRICATION DRAWINGS. REPORT ANY DISCREPANCIES TO THE SUPERVISING OFFICER IMMEDIATELY. ©