

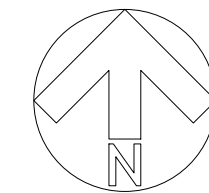


DRAWING FOR PLANNING PURPOSES ONLY.
NOT TO BE USED FOR CONSTRUCTION.

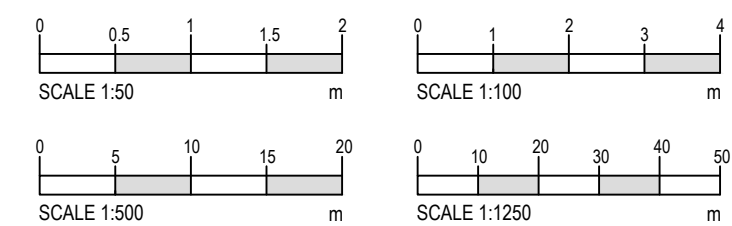

Abbreviations

AV	Air Valve	LP	Lamp Post
BL	Bollard	M	Meter
BM	Bench Mark	MH	Manhole Cover
BP	Boundary Point	MK	Marker
BT	BT Cover	MS	Milestone
CATV	Cable Television Cover	RG	Ridge Level
CAB	Cabinet	RS	Road Sign
CL	Cover Level	rwp	Rain Water Pipe
EP	Electric Power Pole	SC	Stop Cock
EV	Eaves Level	Str	Strainer
FH	Fire Hydrant	SV	Stop Valve
FL	Floor Level	svp	Soil Vent Pipe
FP	Fence Post	TH	Threshold Level
GP	Gully	TL	Traffic Light
GP	Gate Post	TP	Telephone Pole
GV	Gas Valve	UTL	Unable To Lift
IC	Inspection Chamber	VP	Vent Pipe
IL	Invert Level	WM	Water Meter
KO	Kerb Outlet	WO	Wash Out

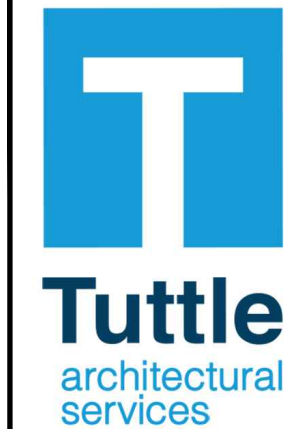

Ground Floor
6 Pelhams Court
Marlborough
Wiltshire SN8 2AG

T. 01672 518 278
E. info@tuttlearchserv.co.uk
F. facebook.com/tuttlearchserv
W. tuttlearchserv.co.uk

JOB TITLE:
Proposed Single Storey Extension & Internal Alterations @ The Paddocks, Lodge Road, Whistley Green, Berkshire, RG10 0EG

For Henrietta Thorn Interior Design

DRAWING TITLE:
Proposed Topographical Site Plan with Ground Floor Plan

JOB NO:
1658

DRAWING NO:
1658 - The Paddocks - Proposed - 11

REV:
-

REVISION DESCRIPTIONS:

SCALE: 1:200	DATE: Oct 25	DRAWN BY: BJ	PAPER SIZE: A1
------------------------	------------------------	------------------------	--------------------------