LIGHTING PLAN KEY

1 2 Heritage Lights

4 5

8 9

10 11

12 13

14




3 7 PIR Security Light

15




6 Porch Light

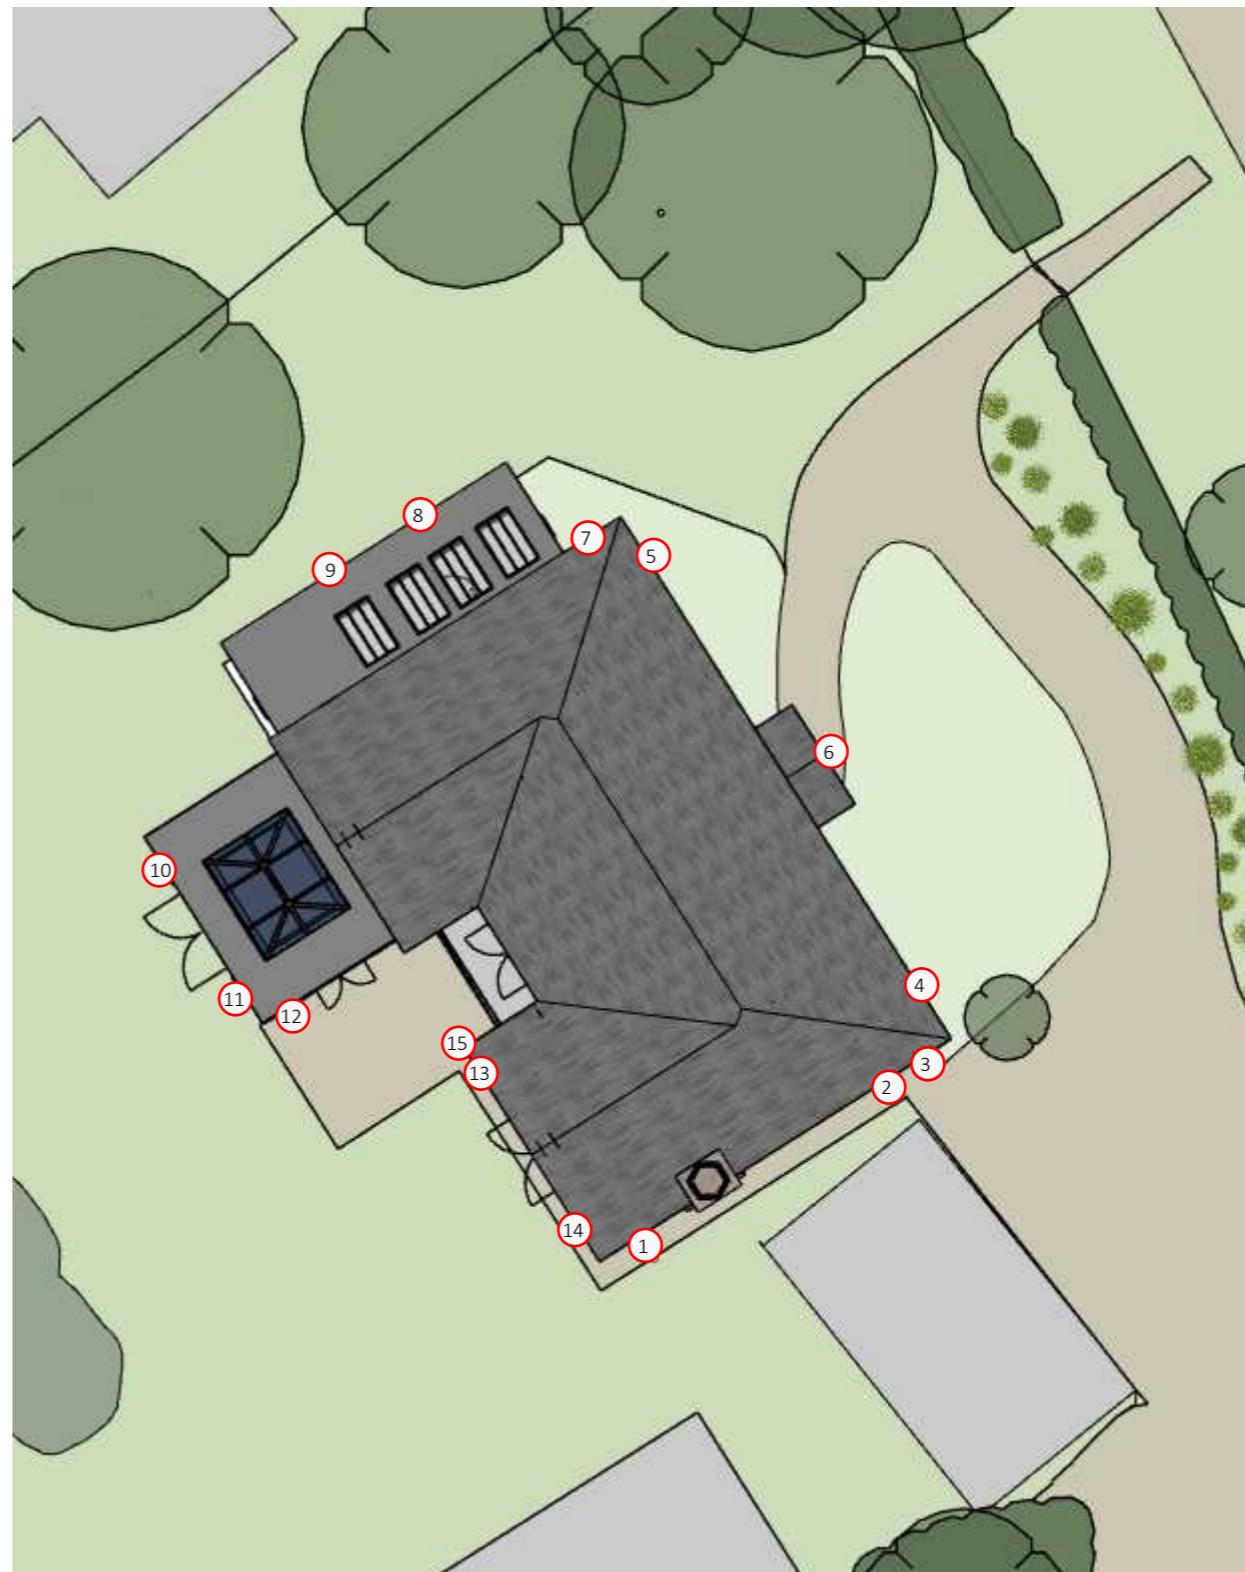LIGHTING PLAN

Existing  
Scale 1:200

Ordnance Survey, ©Crown Copyright 2021. All rights reserved. Licence number 100019980

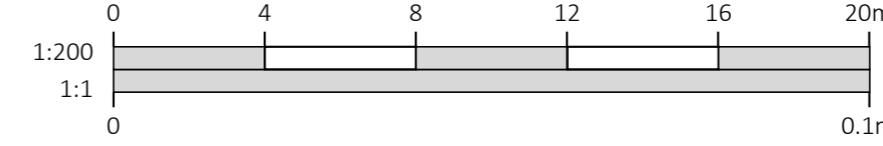

|   |                   |          |    |
|---|-------------------|----------|----|
| A | Amended Plans     | 26.01.26 | JL |
| - | Preliminary issue | 20.11.25 | JL |

## DRAWINGS PRODUCED BY

T.J. Crump Oakwrights Ltd  
The Lakes, Swainshill,  
Hereford, HR4 7PU

+44 (0)1432 353353  
enquiries@oakwrights.co.uk

© This drawing, its contents, and all information contained therein is protected by Copyright. It may be used once only for its intended purpose under a contract with T.J. Crump Oakwrights Ltd, but not for any other use or purpose. This drawing is for Planning purposes and does not constitute a construction issue drawing. All setting out dimensions and levels are indicative and are subject to detailed site survey and site conditions. The Client and their agent are responsible for ensuring that Building Control and construction drawings are carried out following Planning approval. Scaling from this drawing is for Local Planning Authority information only.

CLIENT  
Mr And Mrs Hart

SITE ADDRESS  
Hatchgate End,  
Hatchgate Lane,  
RG10 8NE

PROJECT  
Proposed Dwelling

DEPARTMENT  
ARCHITECTURE

**PROPOSED LIGHTING PLAN**

SCALE  
1:200 @A3

DATE DRAWN  
20.11.25

DATE ISSUED  
26.01.26

DRAWN  
JAC/JL

CHECKED

ISSUE STATUS  
PLANNING

DRG. NO.  
2748.1.2- HAR-20

REV.  
A